
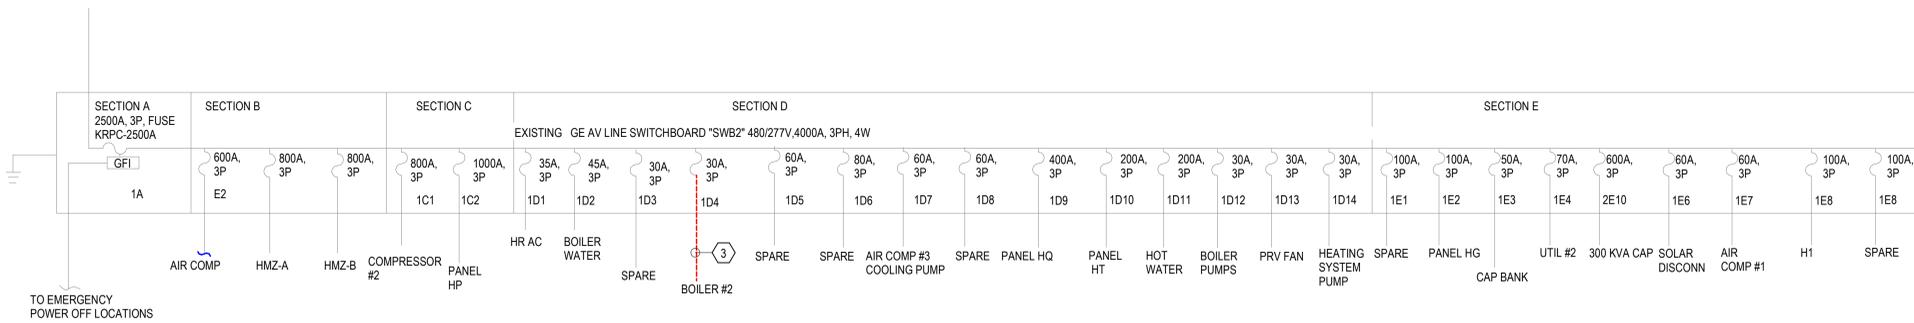


GENERAL NOTES:

A. FIELD VERIFY ALL ELECTRICAL EQUIPMENT PRIOR TO BID.

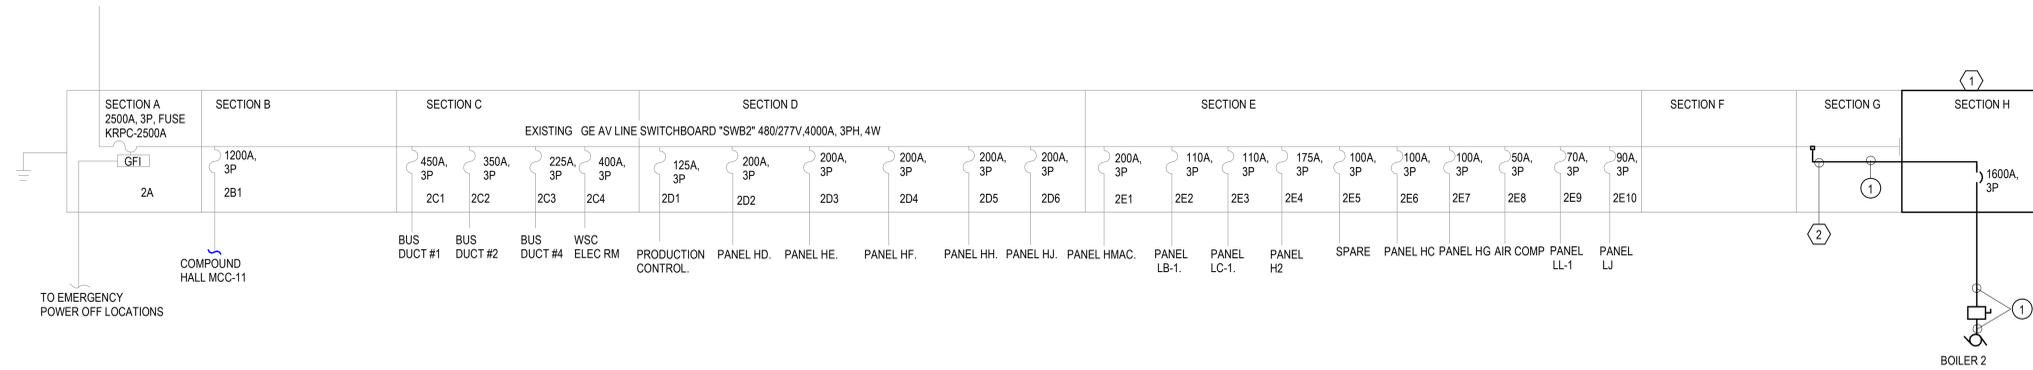

KEYED NOTES:

- ① NEW SWITCHBOARD SECTION H. FIELD VERIFY LOCATION AND COMPATIBILITY. REPORT ANY INCOMPATIBILITY ISSUES TO AE FIRM.
- ② PROVIDE COMPATIBLE LUGS TO TAP ON TO EXISTING GE AV LINE SWITCHBOARD. ROUTE TAP CABLE TO THE BOTTOM PART OF THE GEAR. SIZE TAP CABLE AS INDICATED IN THE DRAWINGS.
- ③ DEMOLISH FEEDER BACK TO SWITCHBOARD.

FEEDER SCHEDULE					
NUMBER	SETS	PHASE CONDUCTORS (PER SET)	NEUTRAL CONDUCTORS (PER SET)	GROUND CONDUCTORS (PER SET)	CONDUIT SIZE (PER SET)
①	4	3#600	-	#4/0	4"

ALL CONDUCTORS SHALL BE COPPER.

L'Oreal USA Products
NLR - BOILER REPLACEMENT
 11500 Maybelline Rd
 North Little Rock, AR 72117

Design Phase
CONSTRUCTION DOCUMENTS

Revisions	No.	Date	Description

Stamp

Notes

- CROMWELL ARCHITECTS ENGINEERS, INC. ALL RIGHTS RESERVED
- THIS SHEET DESIGNED FOR COLOR PRINTING. CRITICAL INFORMATION MAY BE LOST WITH BLACK AND WHITE PRINTING.

Project Number: 2025-024
 Issue Date: 04-11-2025
 Sheet Title: ELECTRICAL SINGLE-LINE DIAGRAM

Sheet Number

E-601