

Design Phase
CONSTRUCTION DOCUMENTS

Revisions

No.	Date	Description

Stamp


Notes
 1. CROMWELL ARCHITECTS/ENGINEERS, INC. ALL RIGHTS RESERVED
 2. THIS SHEET DESIGNED FOR COLOR PRINTING. CRITICAL INFORMATION MAY BE LOST WITH BLACK AND WHITE PRINTING.

Project Number 2025-024
 Issue Date 04-11-2025
 Sheet Title


MECHANICAL SECTIONS

Sheet Number


M-301

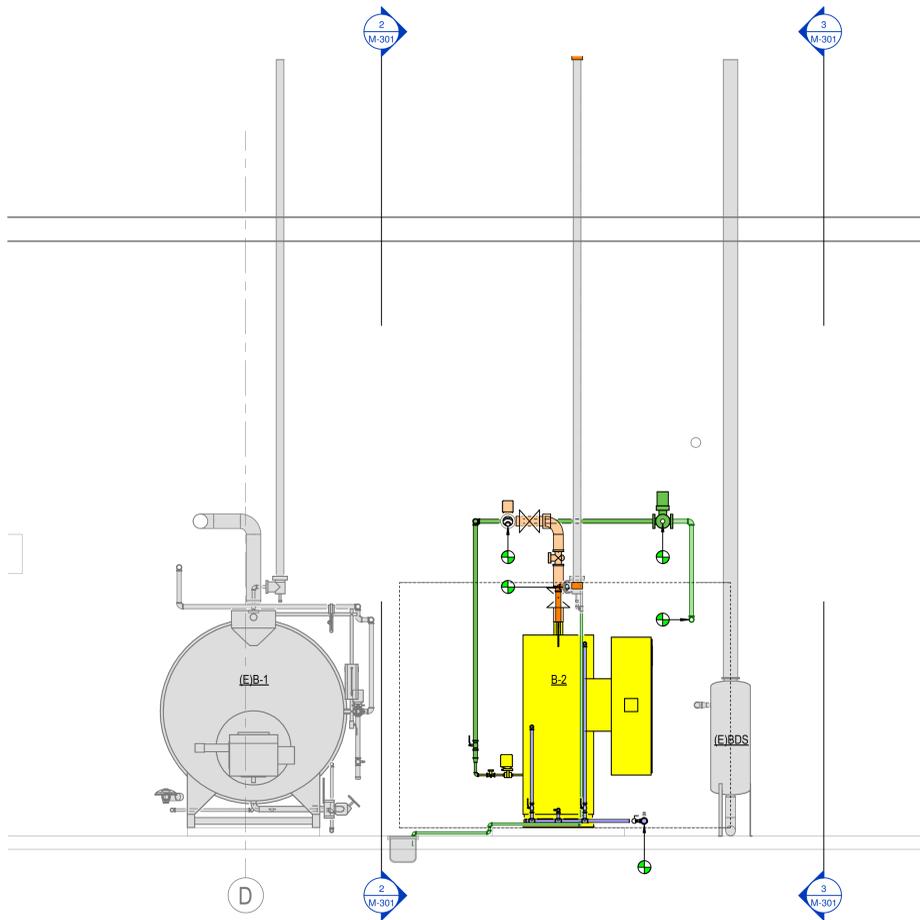


1 MECHANICAL SECTION - WEST VIEW
 3/8" = 1'-0"

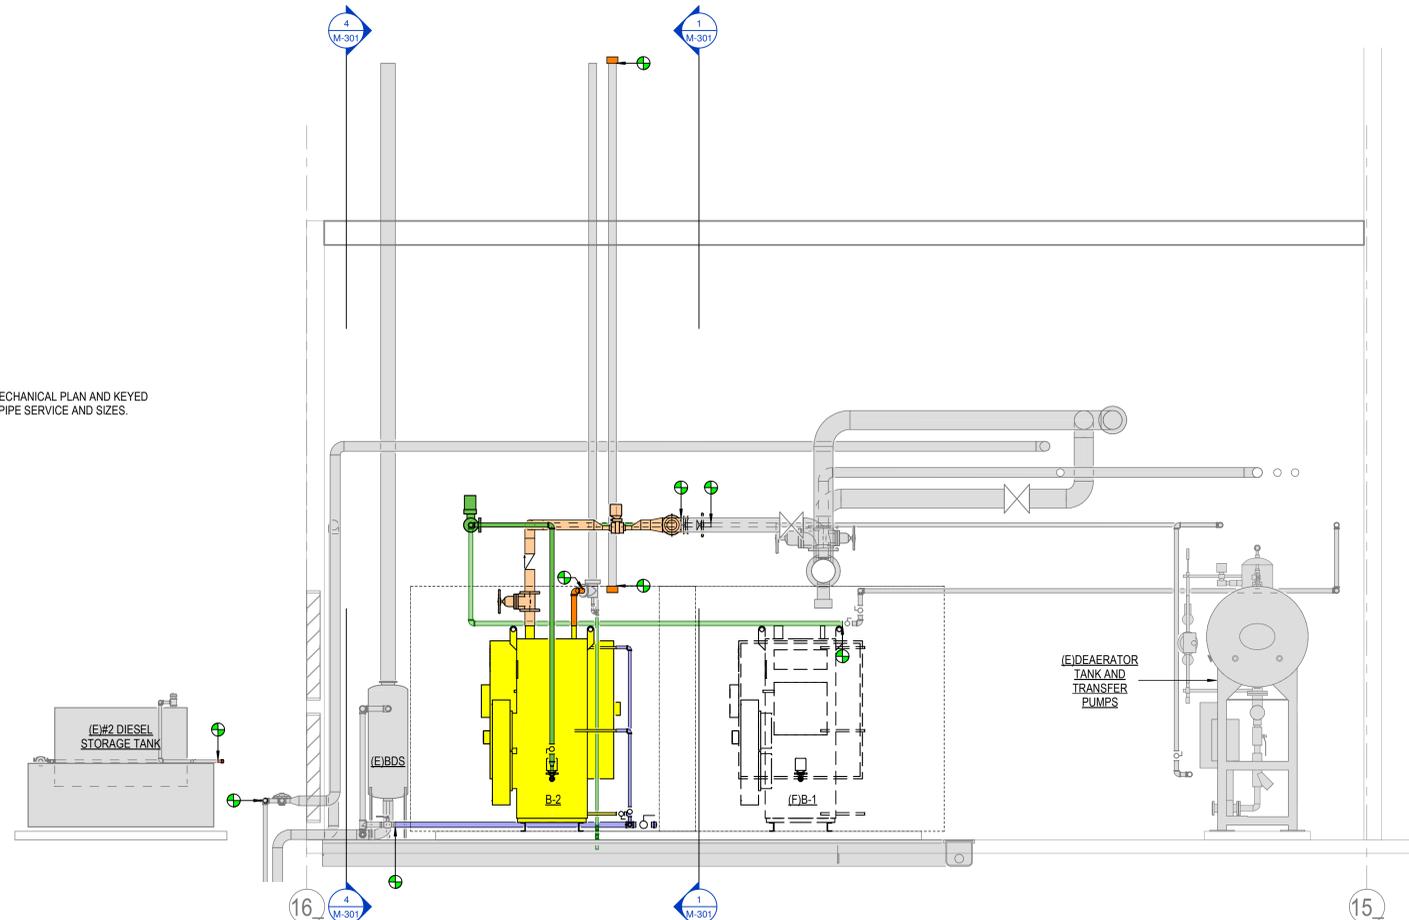

2 MECHANICAL SECTION - NORTH VIEW
 3/8" = 1'-0"

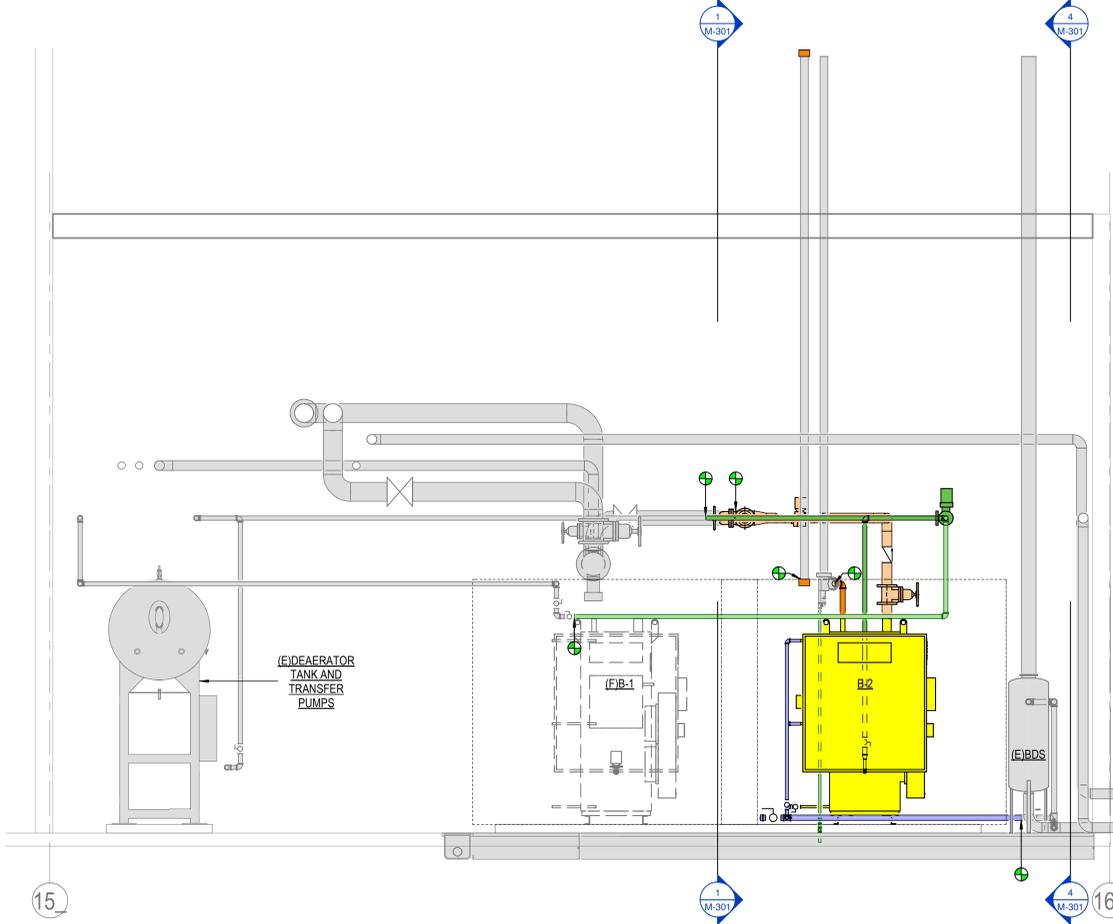

3 MECHANICAL SECTION - SOUTH VIEW
 3/8" = 1'-0"

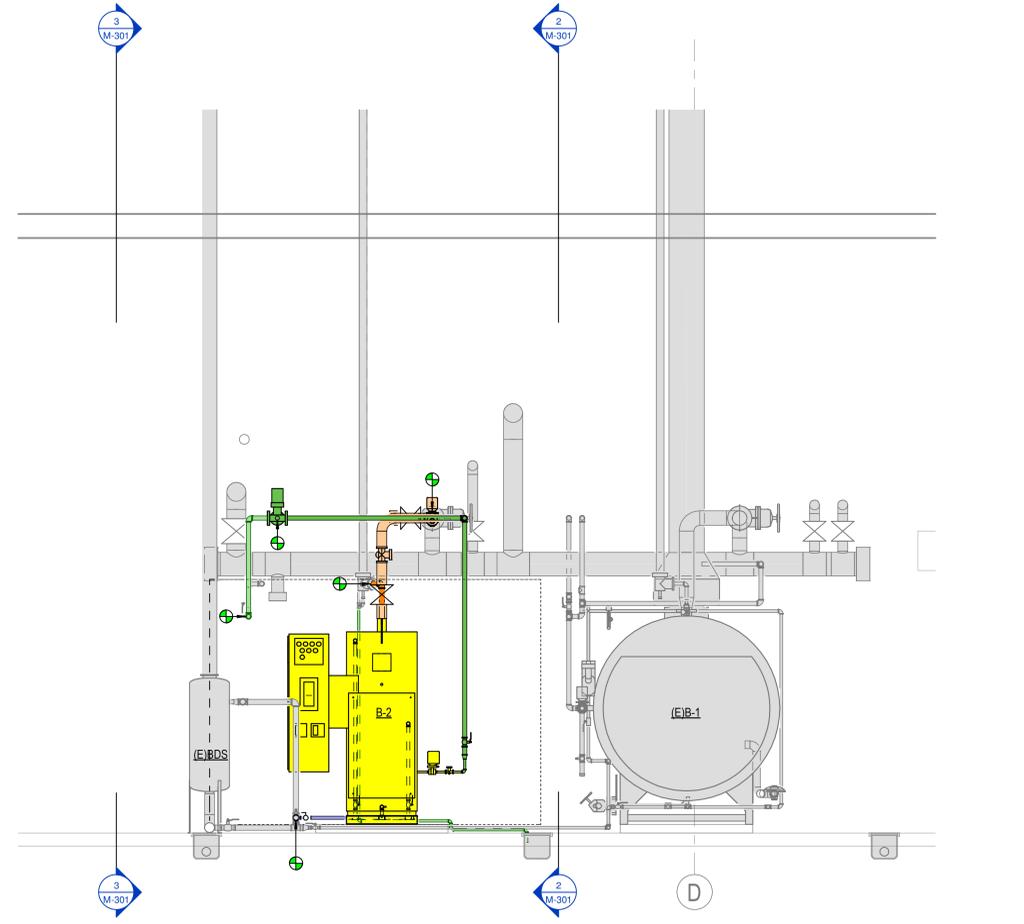

4 MECHANICAL SECTION - EAST VIEW
 3/8" = 1'-0"

GENERAL NOTES:
 1. REFER TO MECHANICAL PLAN AND KEYED NOTES FOR PIPE SERVICE AND SIZES.