

Project

**L'Oreal USA Products
 NLR - BOILER REPLACEMENT**
 11500 Maybelline Rd
 North Little Rock, AR 72117

Design Phase

**CONSTRUCTION
 DOCUMENTS**

Revisions

No.	Date	Description

Stamp



- Notes
1. CROMWELL ARCHITECTS ENGINEERS, INC. ALL RIGHTS RESERVED
 2. THIS SHEET DESIGNED FOR COLOR PRINTING. CRITICAL INFORMATION MAY BE LOST WITH BLACK AND WHITE PRINTING.

Project Number **2025-024**


Issue Date **04-11-2025**

Sheet Title


**MECHANICAL ISOMETRIC
 VIEWS**

Sheet Number

M-901

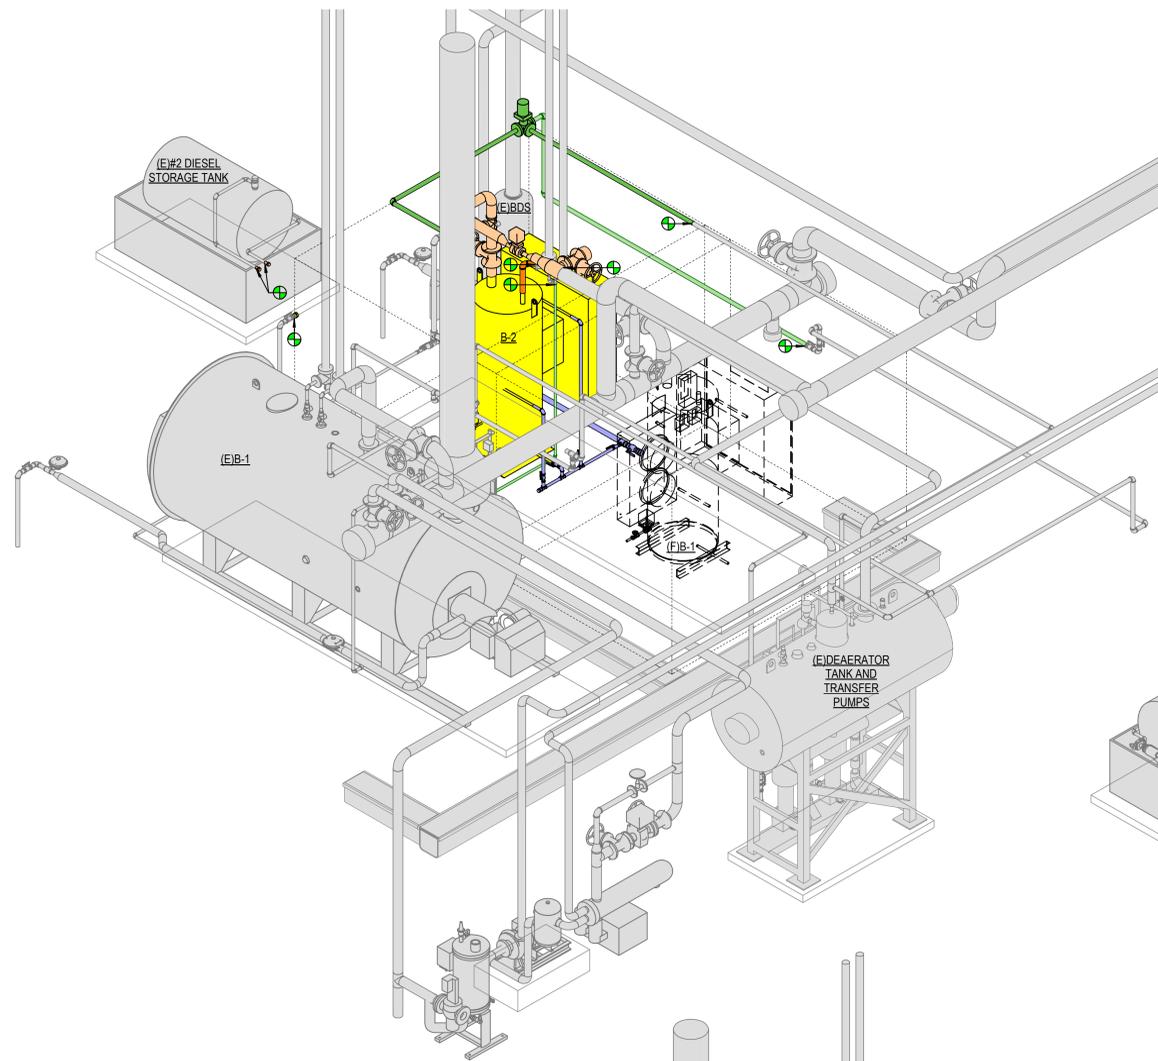


1 MECHANICAL ISOMETRIC - NORTHWEST VIEW
 NOT TO SCALE

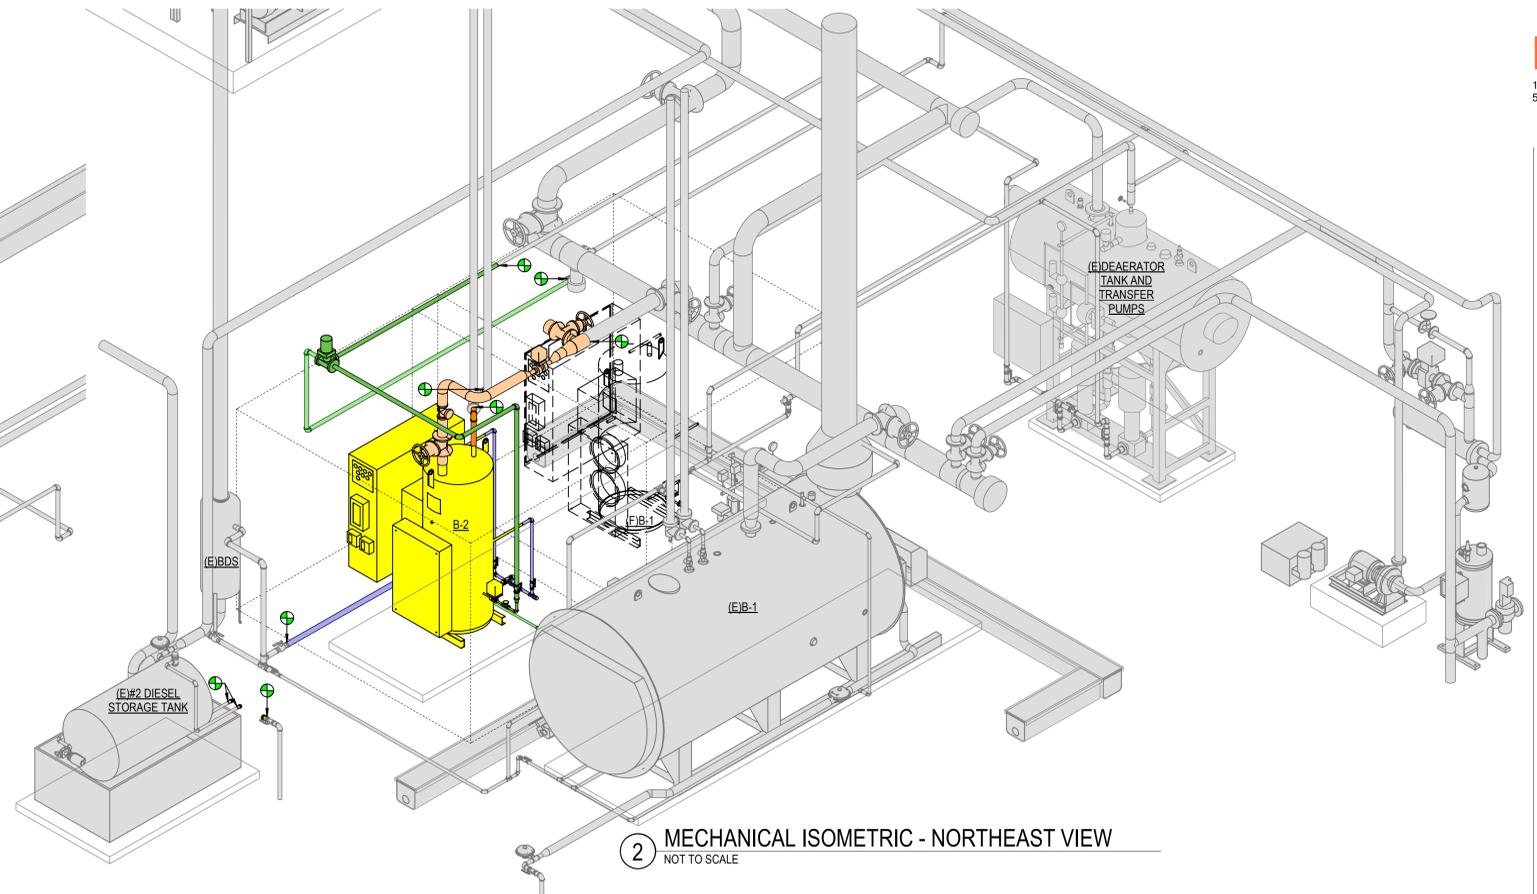


2 MECHANICAL ISOMETRIC - NORTHEAST VIEW
 NOT TO SCALE

- GENERAL NOTES:
1. REFER TO MECHANICAL PLAN AND KEYED NOTES FOR PIPE SERVICE AND SIZES.

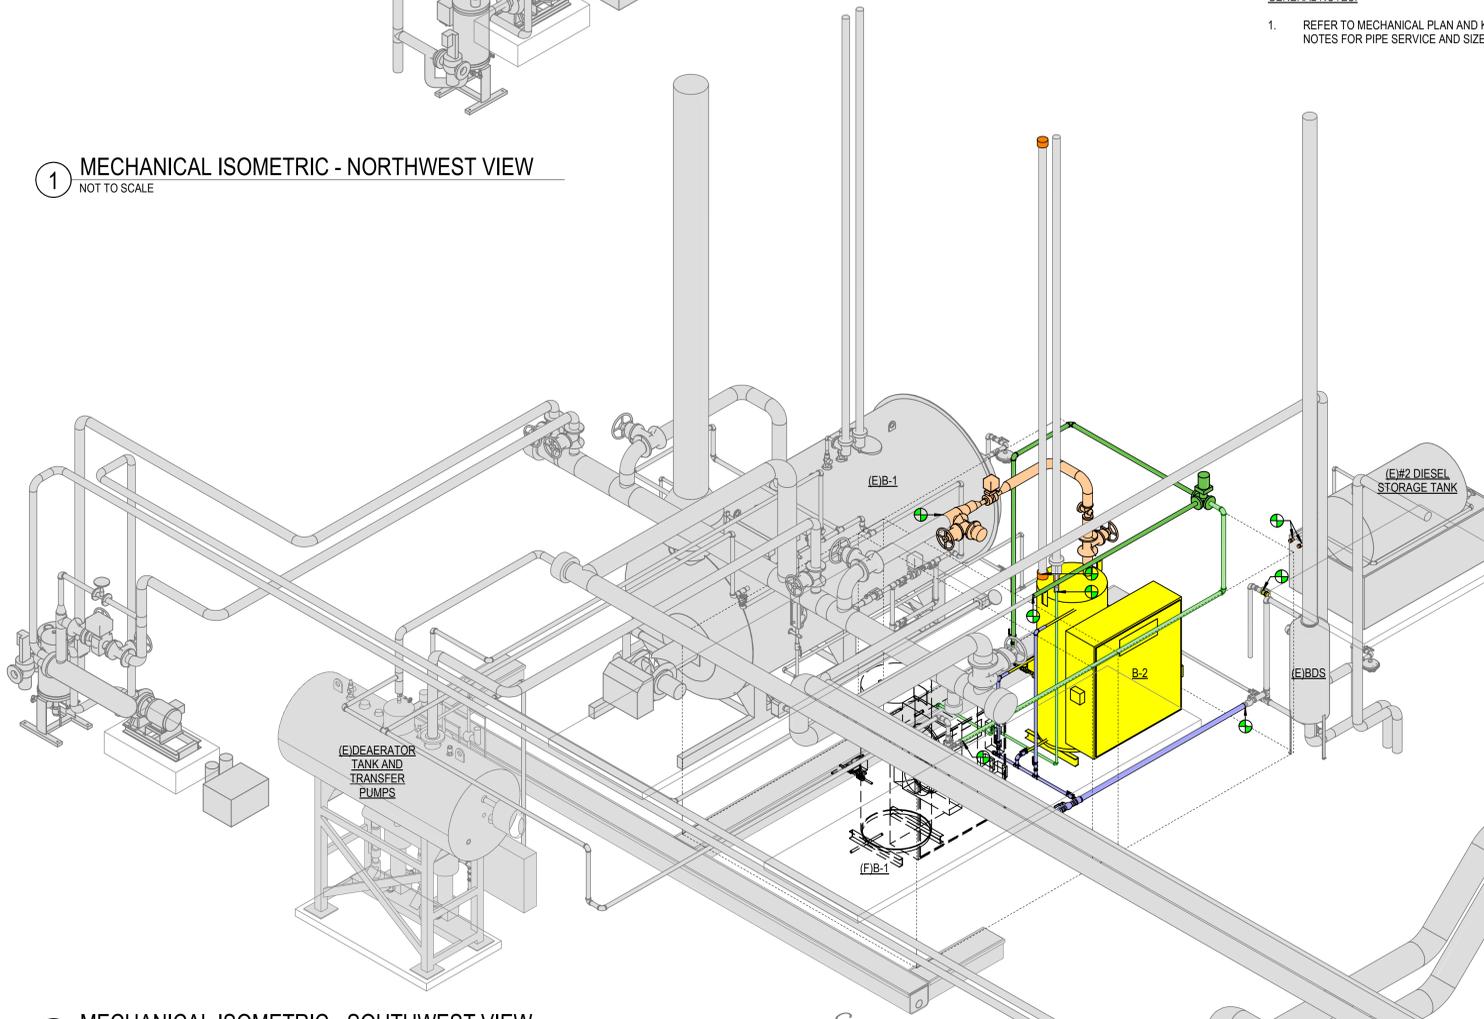

3 MECHANICAL ISOMETRIC - SOUTHWEST VIEW
 NOT TO SCALE

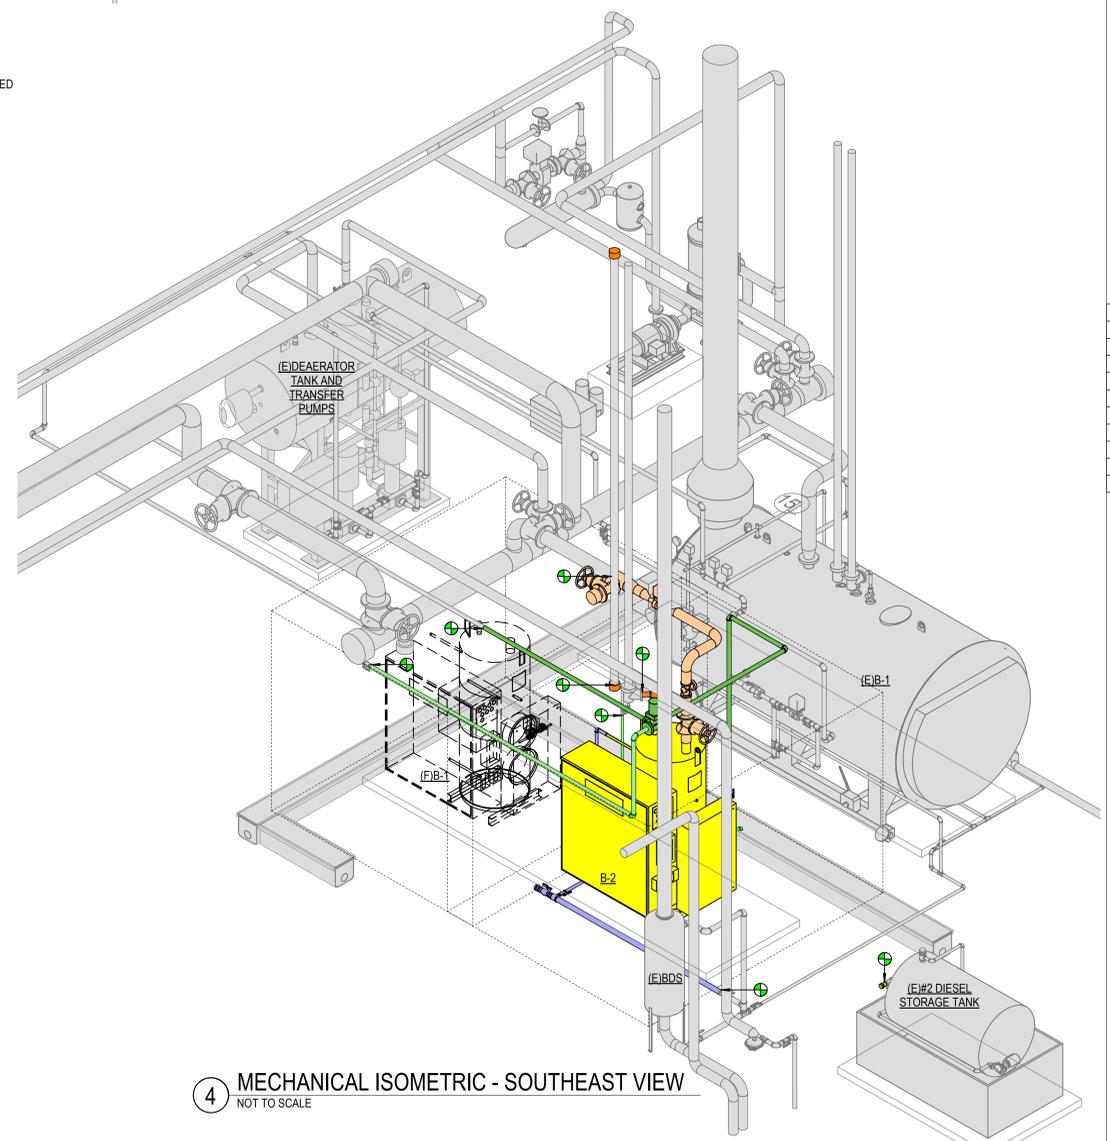

4 MECHANICAL ISOMETRIC - SOUTHEAST VIEW
 NOT TO SCALE