


DIVISION OF BUILDING AUTHORITY

1 CAPITAL MALL,
LITTLE ROCK, AR
72201

PROJECT NAME _____

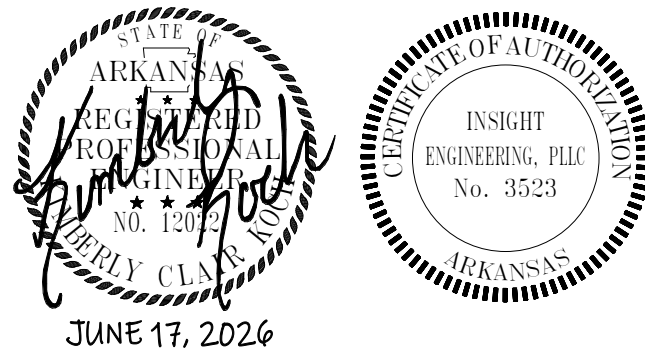

SEAL _____

REVISIONS _____

[illegible]


SHEET _____
NAME _____
DATE _____ JUNE 17, 2026

PROJECT NUMBER 175825

SHEET NUMBER _____

1. ALL PIPING IN FINISHED ROOMS OR SPACES SHALL BE CONCEALED IN A FURRED CHASE OR ABOVE A HANGD SUSPENDED CEILING.
2. ACCESS PANELS IN HARD SUSPENDED CEILINGS ARE REQUIRED FOR ALL VALVES, TRAPS, CLEANOUTS, CONTROLS, ETC. COORDINATE LOCATION OF PANELS WITH MECHANICAL INSTALLATION AND DEMONSTRATE ACCESS TO EQUIPMENT SERVED.
3. ALL PIPE ROUTING AND CONSTRUCTION SHOWN ON THE DRAWINGS IS DIAGRAMATIC IN NATURE AND MAY NOT BE SHOWN IN EXACT LOCATION WITH ALL DIMENSIONS. DIMENSIONS ARE REQUIRED FOR A COMPLETE AND OPERATING SYSTEM. CONTRACTOR SHALL COORDINATE ROUTING OF ALL PIPING PER TYPICAL CONSTRUCTION PRACTICE IN THE MOST EFFICIENT WAY POSSIBLE WHILE ADHERING AS CLOSELY TO THE DRAWINGS AS POSSIBLE. CONTRACTOR IS RESPONSIBLE FOR COORDINATING ALL INSTALLATION WITH EXISTING MECHANICAL SYSTEMS. FIELD CONDITIONS, SUCH AS OVERTIGHTS REQUIRING NEEDED DUE TO OBSTRUCTIONS OR INTERFERENCE SHALL BE PROVIDED AT AN ADDITIONAL COST.
4. ALL WORK SHALL BE PERFORMED IN A NEAT AND WORKMANLIKE MANNER WITH STANDARD OF CARE FOR PROFESSIONAL. ALL LABOR, MATERIAL, TOOLS, PERMITS, INSURANCES, TESTING, CERTIFICATION, ETC. REQUIRED FOR A COMPLETE AND SATISFACTORY INSTALLATION TO BE PROVIDED BY CONTRACTOR. CONTRACTOR SHALL PROVIDE AT NO ADDITIONAL COST INCLUDING INCLUDING INSURANCE NOT SHOWN WHEN REQUIRED FOR TYPICAL COMPLETION OF WORK.
5. DRAWINGS NOT BEARING THE STAMP OR SEAL AND SIGNATURE OF A REGISTERED PROFESSIONAL ENGINEER SHALL NOT BE USED FOR CONSTRUCTION. CONTRACTOR SHALL BE RESPONSIBLE FOR OBTAINING ALL NECESSARY PERMITS. CONTRACTOR SHALL BE RESPONSIBLE FOR ENSURING THAT ALL DRAWINGS AND SPECIFICATIONS BEING USED FOR BIDDING AND CONSTRUCTION PURPOSES ARE OF THE LATEST REVISION AVAILABLE AND THAT ALL ADDENDUM DOCUMENTS HAVE BEEN INCORPORATED EITHER BY REFERENCE OR BY ATTACHMENT TO THE CONTRACT. CONTRACTOR SHALL BE RESPONSIBLE FOR OBTAINING ALL NECESSARY PERMITS.
6. THE PLUMBING CONTRACTOR SHALL FURNISH AND INSTALL NEW PRODUCTS OF ESTABLISHED AND REPUTABLE MANUFACTURERS. NO EQUIPMENT SUBSTITUTIONS SHALL BE MADE THAT WOULD LEAVE INADEQUATE OPERATION OR SERVICE SPACE. EQUIPMENT SHALL BE INSTALLED IN ACCORDANCE WITH THE MANUFACTURER'S RECOMMENDATIONS AND IN ACCORDANCE WITH AN ARRANGEMENT THAT WILL GIVE THE GREATEST PRACTICAL LEASE OF OPERATION AND SERVICE TO THE OWNER.
7. ALL WORK SHALL BE NOT INSTALLED IN ACCORDANCE WITH THE REQUIREMENTS OF ALL APPLICABLE CODES AND REGULATIONS INCLUDING BUT NOT LIMITED TO NATIONAL, CITY, STATE, AND LOCAL ORDINANCES. ALL PLUMBING MATERIALS, INSTALLATION METHODS, AND SYSTEMS SHALL BE IN ACCORDANCE WITH THE REQUIREMENTS OF ALL APPLICABLE CODES AND REGULATIONS. CONTRACTOR SHALL PROVIDE ALL MATERIALS AND LABOR NECESSARY TO COMPLY WITH THESE RULES, REGULATIONS, AND ORDINANCES. THESE CODES REPRESENT THE MINIMUM ACCEPTABLE REQUIREMENTS; THEREFORE, WHERE DRAWINGS AND/OR SPECIFICATIONS CONTRADICT MATERIALS OR CONSTRUCTION MORE STRINGENT THAN CODE REQUIREMENTS, THE DRAWINGS AND SPECIFICATIONS SHALL GOVERN.
8. IT IS THE RESPONSIBILITY OF THE PLUMBING CONTRACTOR TO PAY FOR ALL NECESSARY PERMITS AND APPROVALS FOR THIS INSTALLATION.
9. ALL DOMESTIC WATER PIPING SHALL CONFORM TO THE REQUIREMENTS OF THE ANSI SFAF CODE AND BE FREE FROM ALL DEFECTS AND BE PROPERLY TESTED.
10. STERILIZE THE ENTIRE WATER DISTRIBUTION SYSTEM PER THE REQUIREMENTS OF THE LOCAL AUTHORITY HAVING JURISDICTION.
11. DOMESTIC WATER SYSTEMS, SLEAVE, SLOPE AND WENT SYSTEM SHALL BE TESTED PER LOCAL AUTHORITY HAVING JURISDICTION TEST AND OBTAIN APPROVAL ON ALL LEAKS AND WENT SYSTEM FROM ADMINISTRATIVE AUTHORITY. HAVING JURISDICTION PRIOR TO COVERING WORK.
12. PLUMBING CONTRACTOR SHALL PROVIDE INITIAL START UP OF ALL SYSTEMS INCLUDED IN THE PLUMBING WORK.
13. ALL EXPOSED PIPING BELOW VALVARIETY'S DESIGNATED AS HANDICAPPED SHALL BE TOTALLY INSULATED.
14. ALL NON-DRAINAGE PIPING SHALL BE RUN/LEVEL AND GENERALLY FREE OF TRAPS AND UNNECESSARY BENDS, ARRANGED TO CONFORM TO THE BUILDING REQUIREMENTS AND TO SUIT THE NECESSITIES OF CLEARANCES FOR OTHER MECHANICAL WORK. PROVIDE DRAINAGE FOR ALL PIPING. PROVIDE DRAINAGE FOR ALL PIPING. PROVIDE DRAINAGE FOR ALL PIPING. PROVIDE DRAINAGE FOR ALL PIPING.
15. ALL EQUIPMENT, PIPING, ETC. SHALL BE SUPPORTED AS DETAILED AND/or SPECIFIED; PROVIDE ADDITIONAL SUPPORTS AS REQUIRED TO PROVIDE A VIBRATION/FREE, RIGID INSTALLATION.
16. PENETRATIONS OF WALLS OR FLOORS FOR THE PASSAGE OF PIPING OR OTHER EQUIPMENT SHALL BE PROPERLY SEALED AFTER INSTALLATION OF ITEMS AND EQUIPMENT.
17. PROVIDE UNIONS OR FLANGES AT PIPING CONNECTIONS TO EQUIPMENT TO ALLOW DISASSEMBLY FOR MAINTENANCE. ARRANGE PIPING TO ALLOW FULL PIPING SPACE FOR EQUIPMENT REMOVAL.
18. PROVIDE ESCUTCHEONS FOR EXPOSED PIPING PENETRATIONS INTO FINISHED ROOMS.
19. PIPING, LEAK PROTECTION APPARATUS, OR OTHER EQUIPMENT FOREIGN TO ELECTRICAL SWITCHGEAR, PANELBOARDS, DISTRIBUTION BOARDS, OR MOTOR CONTROL CENTERS SHALL NOT BE INSTALLED WITH THE REQUIRED SPACE FOR WORKING SPACE. PROVIDE ADEQUATE CLEARANCE FOR THE ELECTRICAL EQUIPMENT, EXTENDING IN FRONT OF AND BEYOND TO STRUCTURAL CEILING WITH A WIDTH AND DEPTH OF THE ELECTRICAL EQUIPMENT IN ACCORDANCE WITH NEC-110.26.
20. A WATER-HAMMER ARRESTOR SHALL BE INSTALLED WHERE QUICK-CLOSING VALVES ARE UTILIZED. WATER-HAMMER ARRESTORS SHALL BE INSTALLED IN ACCORDANCE WITH THE MANUFACTURER'S SPECIFICATIONS. WATER-HAMMER ARRESTORS SHALL CONFORM TO ASSE 1010.

SYMBOL	DESCRIPTION	SYMBOL	DESCRIPTION
	EXISTING FIXTURE / EQUIPMENT TO REMAIN.		BALL VALVE
	EXISTING FIXTURE / EQUIPMENT TO BE REMOVED.		GATE VALVE
	NEW FIXTURE / EQUIPMENT.		CHECK VALVE
	EXISTING PIPING TO REMAIN.	P-1	PLUMBING FIXTURE / EQUIPMENT DESIGNATION
	EXISTING PIPING TO BE REMOVED.	FD	FLOOR DRAIN
	NEW PIPING	RD	ROOF DRAIN
	SANITARY SEWER (SS)	ORD	OVERFLOW ROOF DRAIN
	VENT (V)	SD	STORM DRAIN
	COLD WATER (CW)	VTRU	VENT THRU ROOF
	HOT WATER (HW)	CO	CLEANOUT PLUG
	HOT WATER RETURN (HWR)	FOO	FLOOR CLEANOUT
	STORM DRAIN	WCO	WALL CLEANOUT
	OVERFLOW STORM DRAIN	COTG	CLEANOUT TO GRADE
		DCOTG	DOUBLE CLEANOUT TO GRADE
			RISER DESIGNATION
			CONNECT TO EXISTING.
			POINT OF DEMOLITION.
			REVISION DELTA

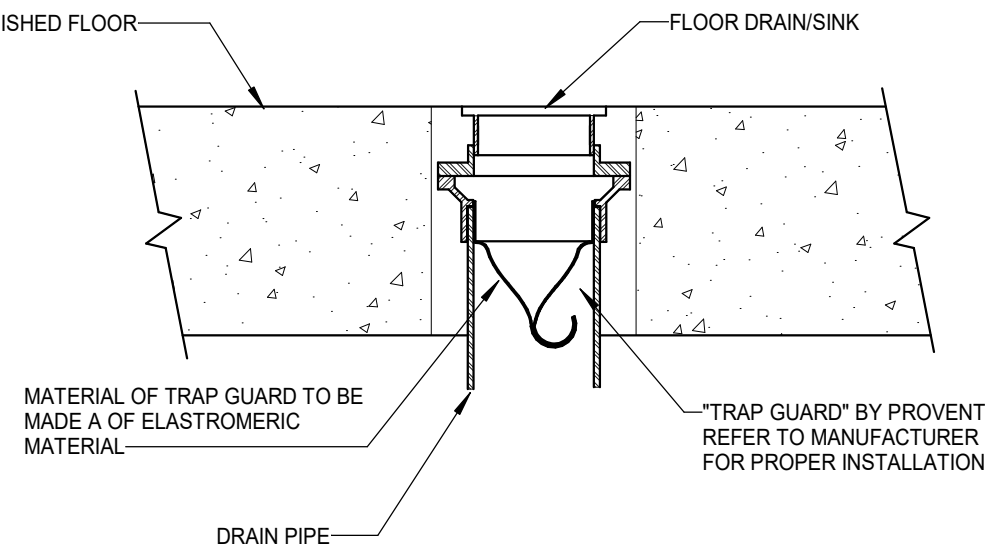

DESIGNATION	FIXTURE	DESCRIPTION	SIZE	PIPE CONNECTION SIZE		
				COLD WATER	HOT WATER	TRAP
FD-1	FLOOR DRAIN	ZURN ZN-415-J5" WITH CAST IRON BODY AND RECESSED RIM NICKEL BRONZE STRAINER	AS NOTED	-	-	-

MANUFACTURER AND MODEL NUMBERS LISTED ARE BASIS OF DESIGN, APPROVED EQUALS ARE ALLOWED UNLESS OTHERWISE NOTED

B4 TRAP-GUARD DETAIL
NOT TO SCALE:



DIVISION OF
BUILDING
AUTHORITY

1 CAPITAL MALL,
LITTLE ROCK, AR
72201

PROJECT NAME _____



SEAL _____

REVISIONS _____

[illegible]

LEVEL 4 - PLUMBING
DEMOLITION


SHEET _____

DATE JUNE 17, 2021

PROJECT NUMBER 17582

PD101

SHEET NUMBER _____

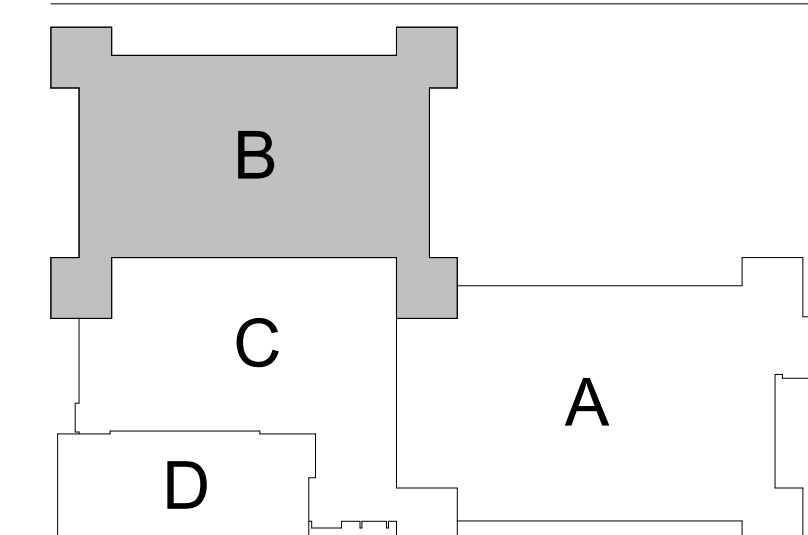



DEMOLITION KEYED NOTES

- | | |
|---|--|
| 1 | EXISTING FIXTURE TO REMAIN. |
| 2 | REMOVE EXISTING FIXTURE AND ASSOCIATED PIPING. CAP |

REFER TO SHEETS PD201
PL202 FOR DEMOLITION
PLUMBING WORK IN THIS
MECHANICAL ROOM

A1 LEVEL 4 - AREA B - PLUMBING DEMOLITION
1/8" = 1'-0"

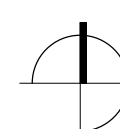

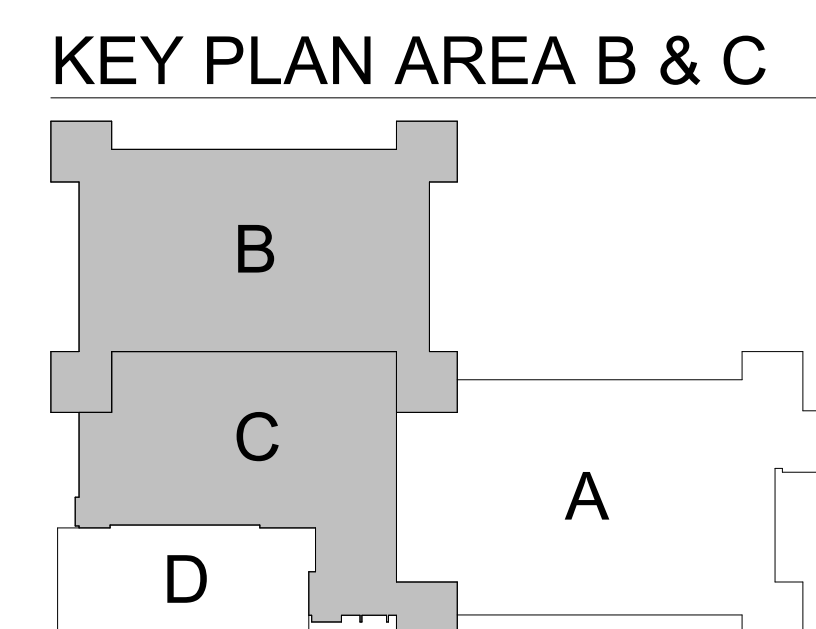

DEMOLITION KEYED NOTES	
1	2" SANITARY SEWER (SS) AND 2" VENT (V) LOCATED BELOW FLOOR AND SUBSTRUCTURE.
2	EXISTING SANITARY SEWER (SS) AND VENT (V) RISER PIPING.
3	2" SANITARY SEWER (SS) AND 2" VENT (V) LOCATED BELOW FLOOR AND SUBSTRUCTURE TO BE REMOVED.
4	EXISTING FLOOR DRAIN TO BE REMOVED.
5	EXISTING FLOOR DRAIN TO REMAIN IN PLACE.

TAGGART
ARCHITECTS

600 Main Street, Suite 300
North Little Rock, AR 72114
Phone: 501-758-7443
Fax: 501-753-7309
www.taggarch.com



DBA PROJECT
6152602
100% CD's

DIVISION OF
BUILDING
AUTHORITY

4TH FLOOR MAC BUILDING MODULE "B" and "C" RENOVATION

1 CAPITAL MALL,
LITTLE ROCK, AR
72201

PROJECT NAME _____



SEAI _____

REVISIONS _____

[illegible]

MECHANICAL ROOM -
AREA-B & AREA C -
PLUMBING DEMOLITION

SHEET NAME _____

DATE JUNE 17, 202

PROJECT NUMBER 1758

PD201

SHEET NUMBER _____



DBA PROJECT
6152602
100% CD's

DIVISION OF
BUILDING
AUTHORITY

4TH FLOOR MAC BUILDING MODULE "B" and "C" RENOVATION

1 CAPITAL MALL,
LITTLE ROCK, AR
72201

PROJECT NAME _____



SFAI _____

REVISIONS _____

[illegible]

LEVEL 4 - PLUMBING RENOVATION


SHEET _____

DATE JUNE 17, 2021

PROJECT NUMBER 17582

PL101

SHEET NUMBER _____

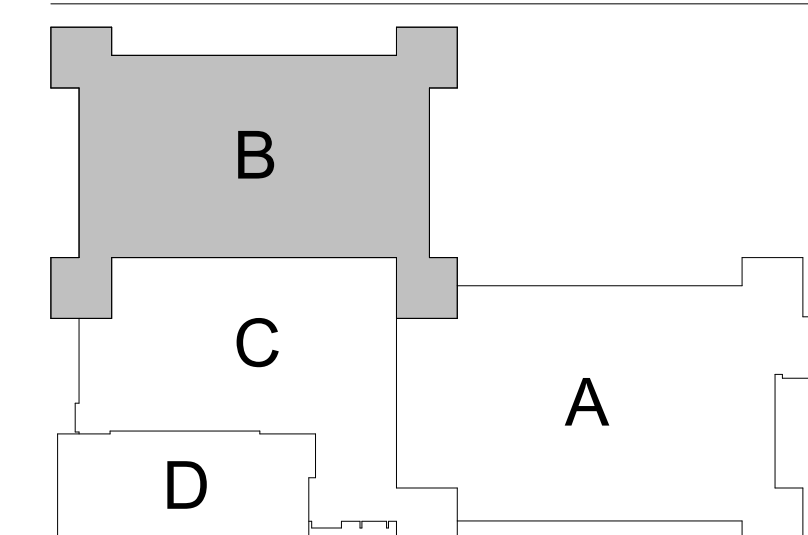

REFER TO SHEETS PL201 &
PL202 FOR RENOVATION
PLUMBING WORK IN THIS
MECHANICAL ROOM

A1 LEVEL 4 - AREA B - SANITARY SEWER RENOVATION
1/8" = 1'-0"

$1/8'' = 1'-0''$

KEYED NOTES	
1	2" SANITARY SEWER (SS) AND 2" VENT (V) LOCATED BELOW FLOOR AND SUBSTRUCTURE.
2	EXISTING SANITARY SEWER (SS) AND VENT (V) RISER PIPING.



500 Main Street, Suite 300
North Little Rock, AR 72114
Phone: 501-758-7443
Fax: 501-753-7309
www.taggarch.com




DBA PROJECT
6152602
100% CD's

DIVISION OF BUILDING AUTHORITY

4TH FLOOR MAC BUILDING MODULE "B" and "C" RENOVATION

1 CAPITAL MALL,
LITTLE ROCK, AR
72201

PROJECT NAME _____

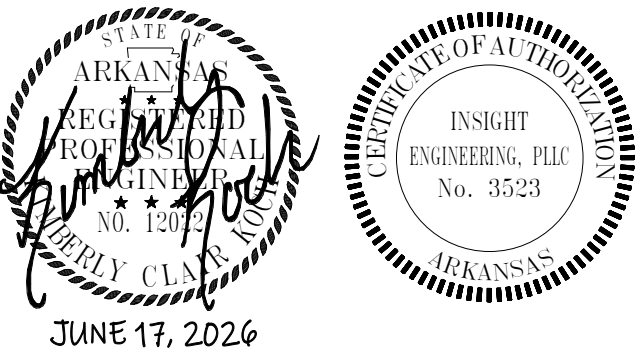

SEAL _____

REVISIONS _____

[illegible]


MECHANICAL ROOM - AREA-B & AREA-C - PLUMBING


SHEET _____

DATE JUNE 17, 2026PROJECT NUMBER 175825


PL201

SHEET NUMBER _____

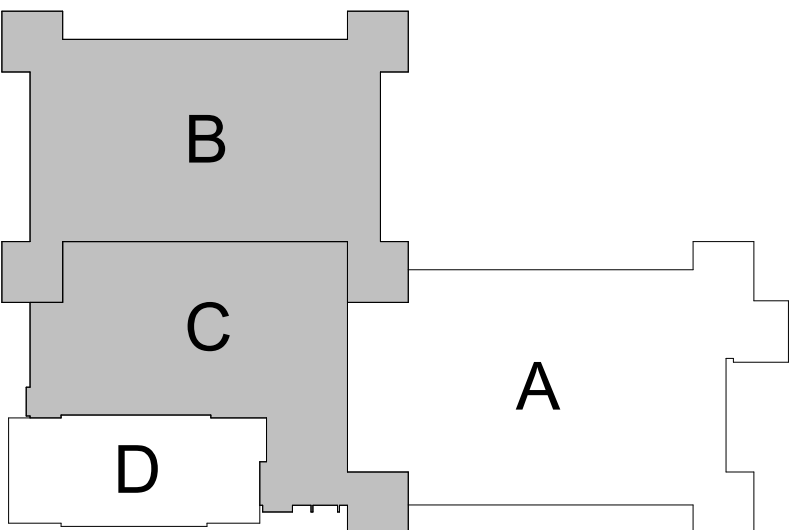


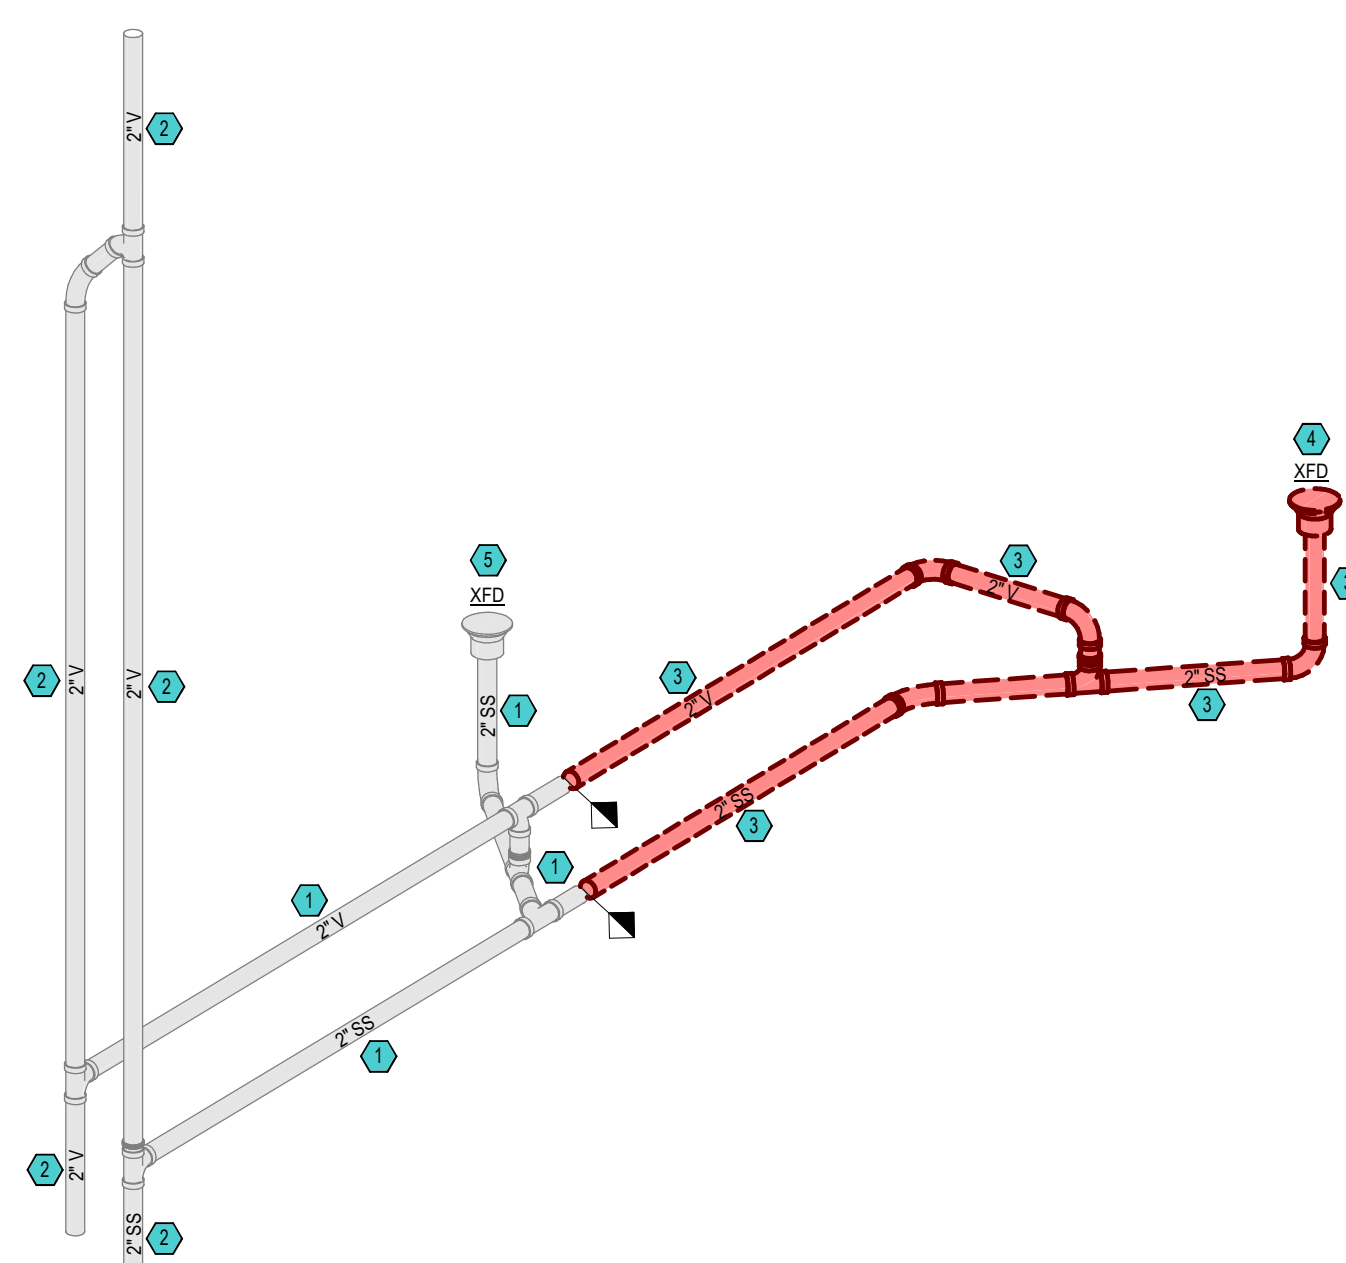


C1 3D - MECHANICAL ROOM - AREA-B - PLUMBING DEMOLITION
NOT TO SCALE:

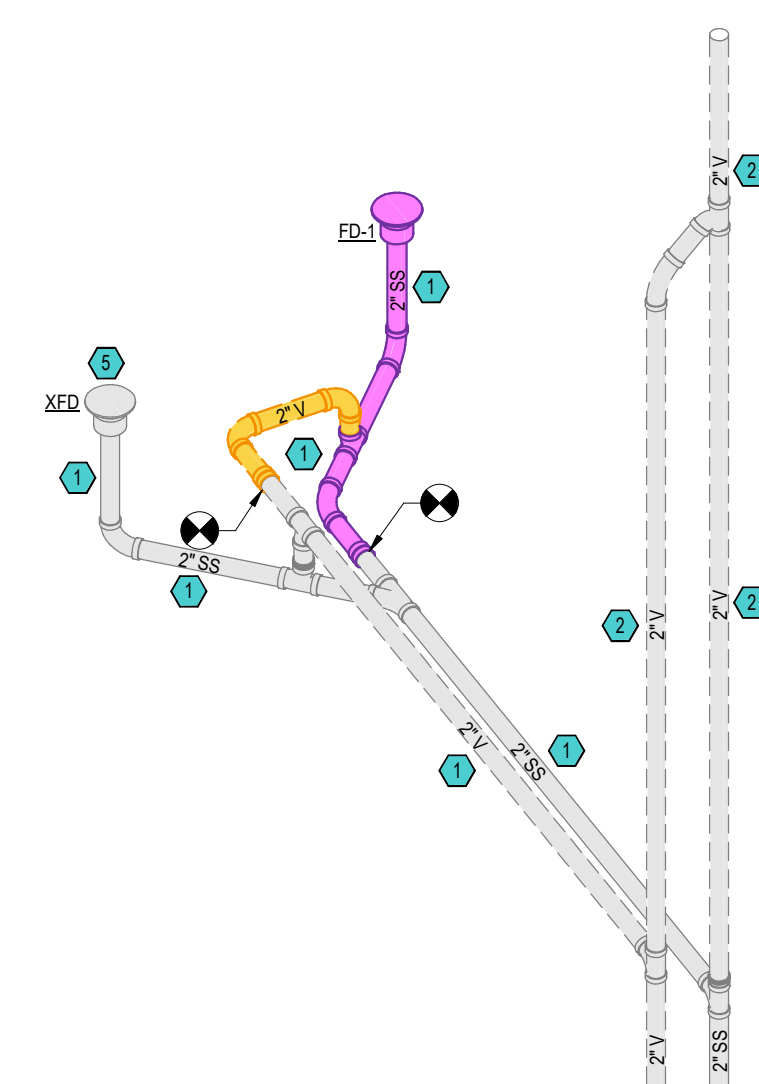

C4 3D - MECHANICAL ROOM - AREA-B - PLUMBING
NOT TO SCALE:

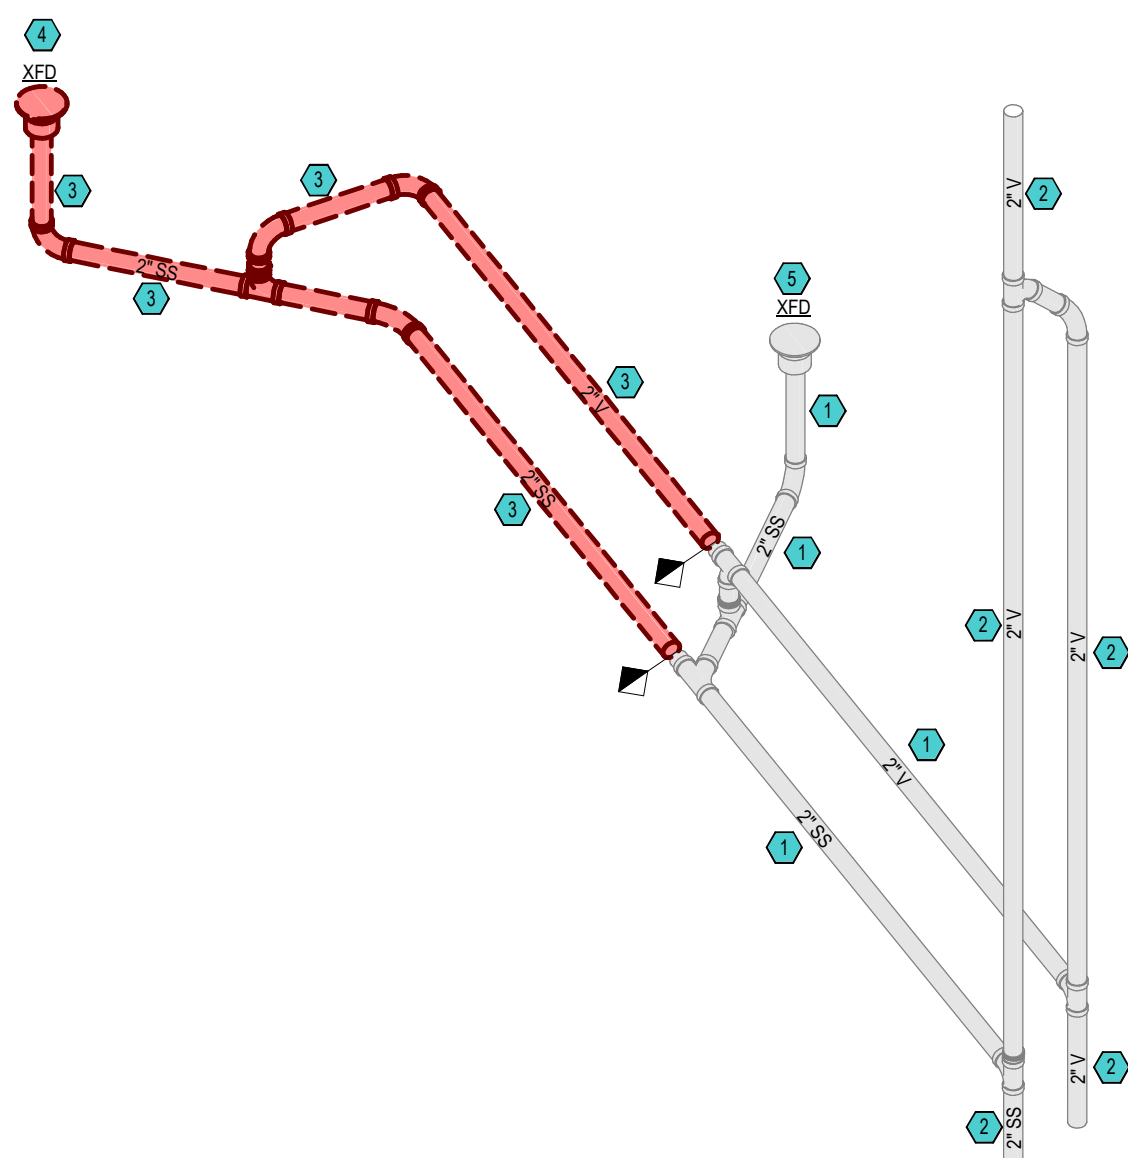

A1 3D - MECHANICAL ROOM - AREA-C - PLUMBING DEMOLITION
NOT TO SCALE:

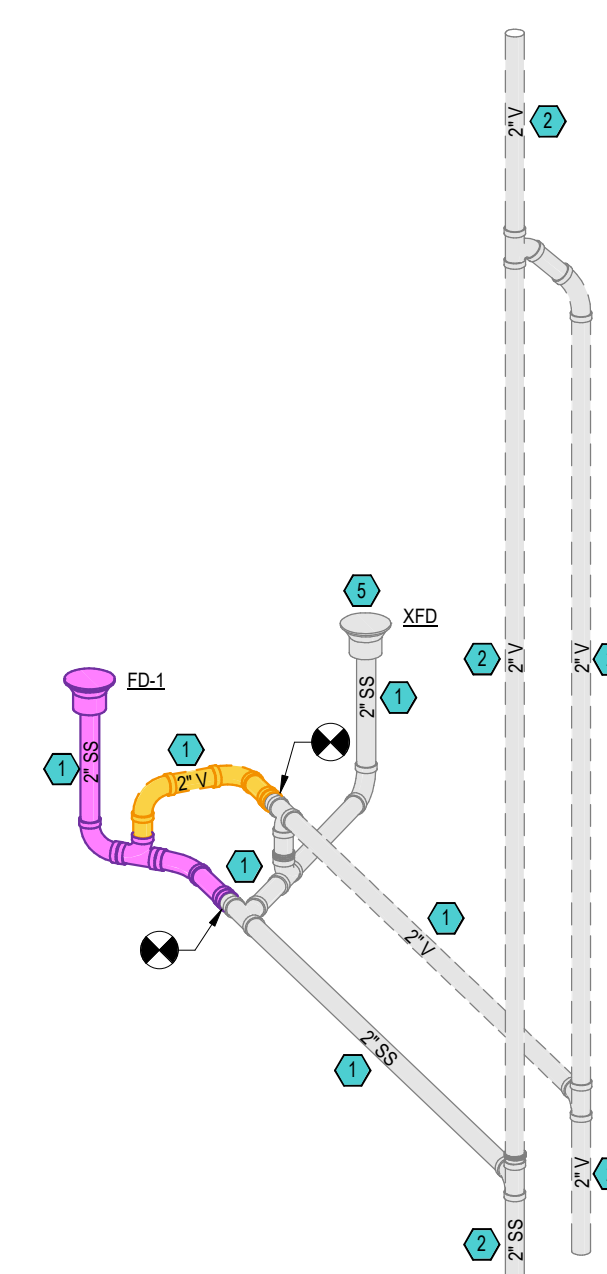

A4 3D - MECHANICAL ROOM - AREA-C - PLUMBING
NOT TO SCALE:

KEYED NOTES	
1	2" SANITARY SEWER (SS) AND 2" VENT (V) LOCATED BELOW FLOOR AND SUBSTRUCTURE.
2	EXISTING SANITARY SEWER (SS) AND VENT (V) RISER PIPING.
3	2" SANITARY SEWER (SS) AND 2" VENT (V) LOCATED BELOW FLOOR AND SUBSTRUCTURE TO BE REMOVED.
4	EXISTING FLOOR DRAIN TO BE REMOVED.
5	EXISTING FLOOR DRAIN TO REMAIN IN PLACE.

TAGGART
ARCHITECTS

600 Main Street, Suite 300
North Little Rock, AR 72114
Phone: 501-758-7443
Fax: 501-753-7309
www.taggarch.com




DBA PROJECT
6152602
100% CD's

DIVISION OF
BUILDING
AUTHORITY

4TH FLOOR MAC BUILDING MODULE "B" and "C" RENOVATION

1 CAPITAL MALL,
LITTLE ROCK, AR
72201

PROJECT NAME _____

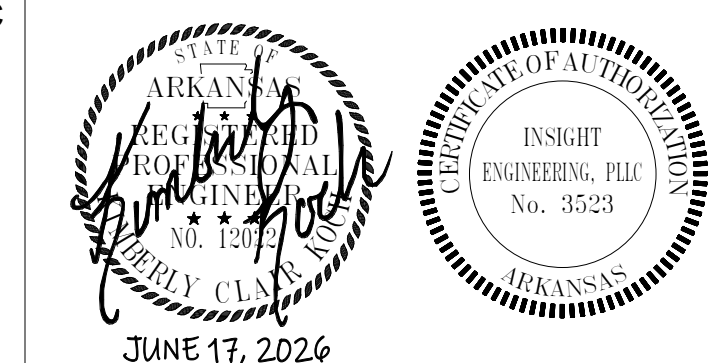

SEAL _____

REVISIONS _____

[illegible]

3D VIEWS MECHANICAL ROOM - AREA-B & AREA C - PLUMBING

SHEET _____
NAME _____
DATE _____ JUNE 17, 2026

PROJECT NUMBER 175825

PL202

SHEET NUMBER _____