



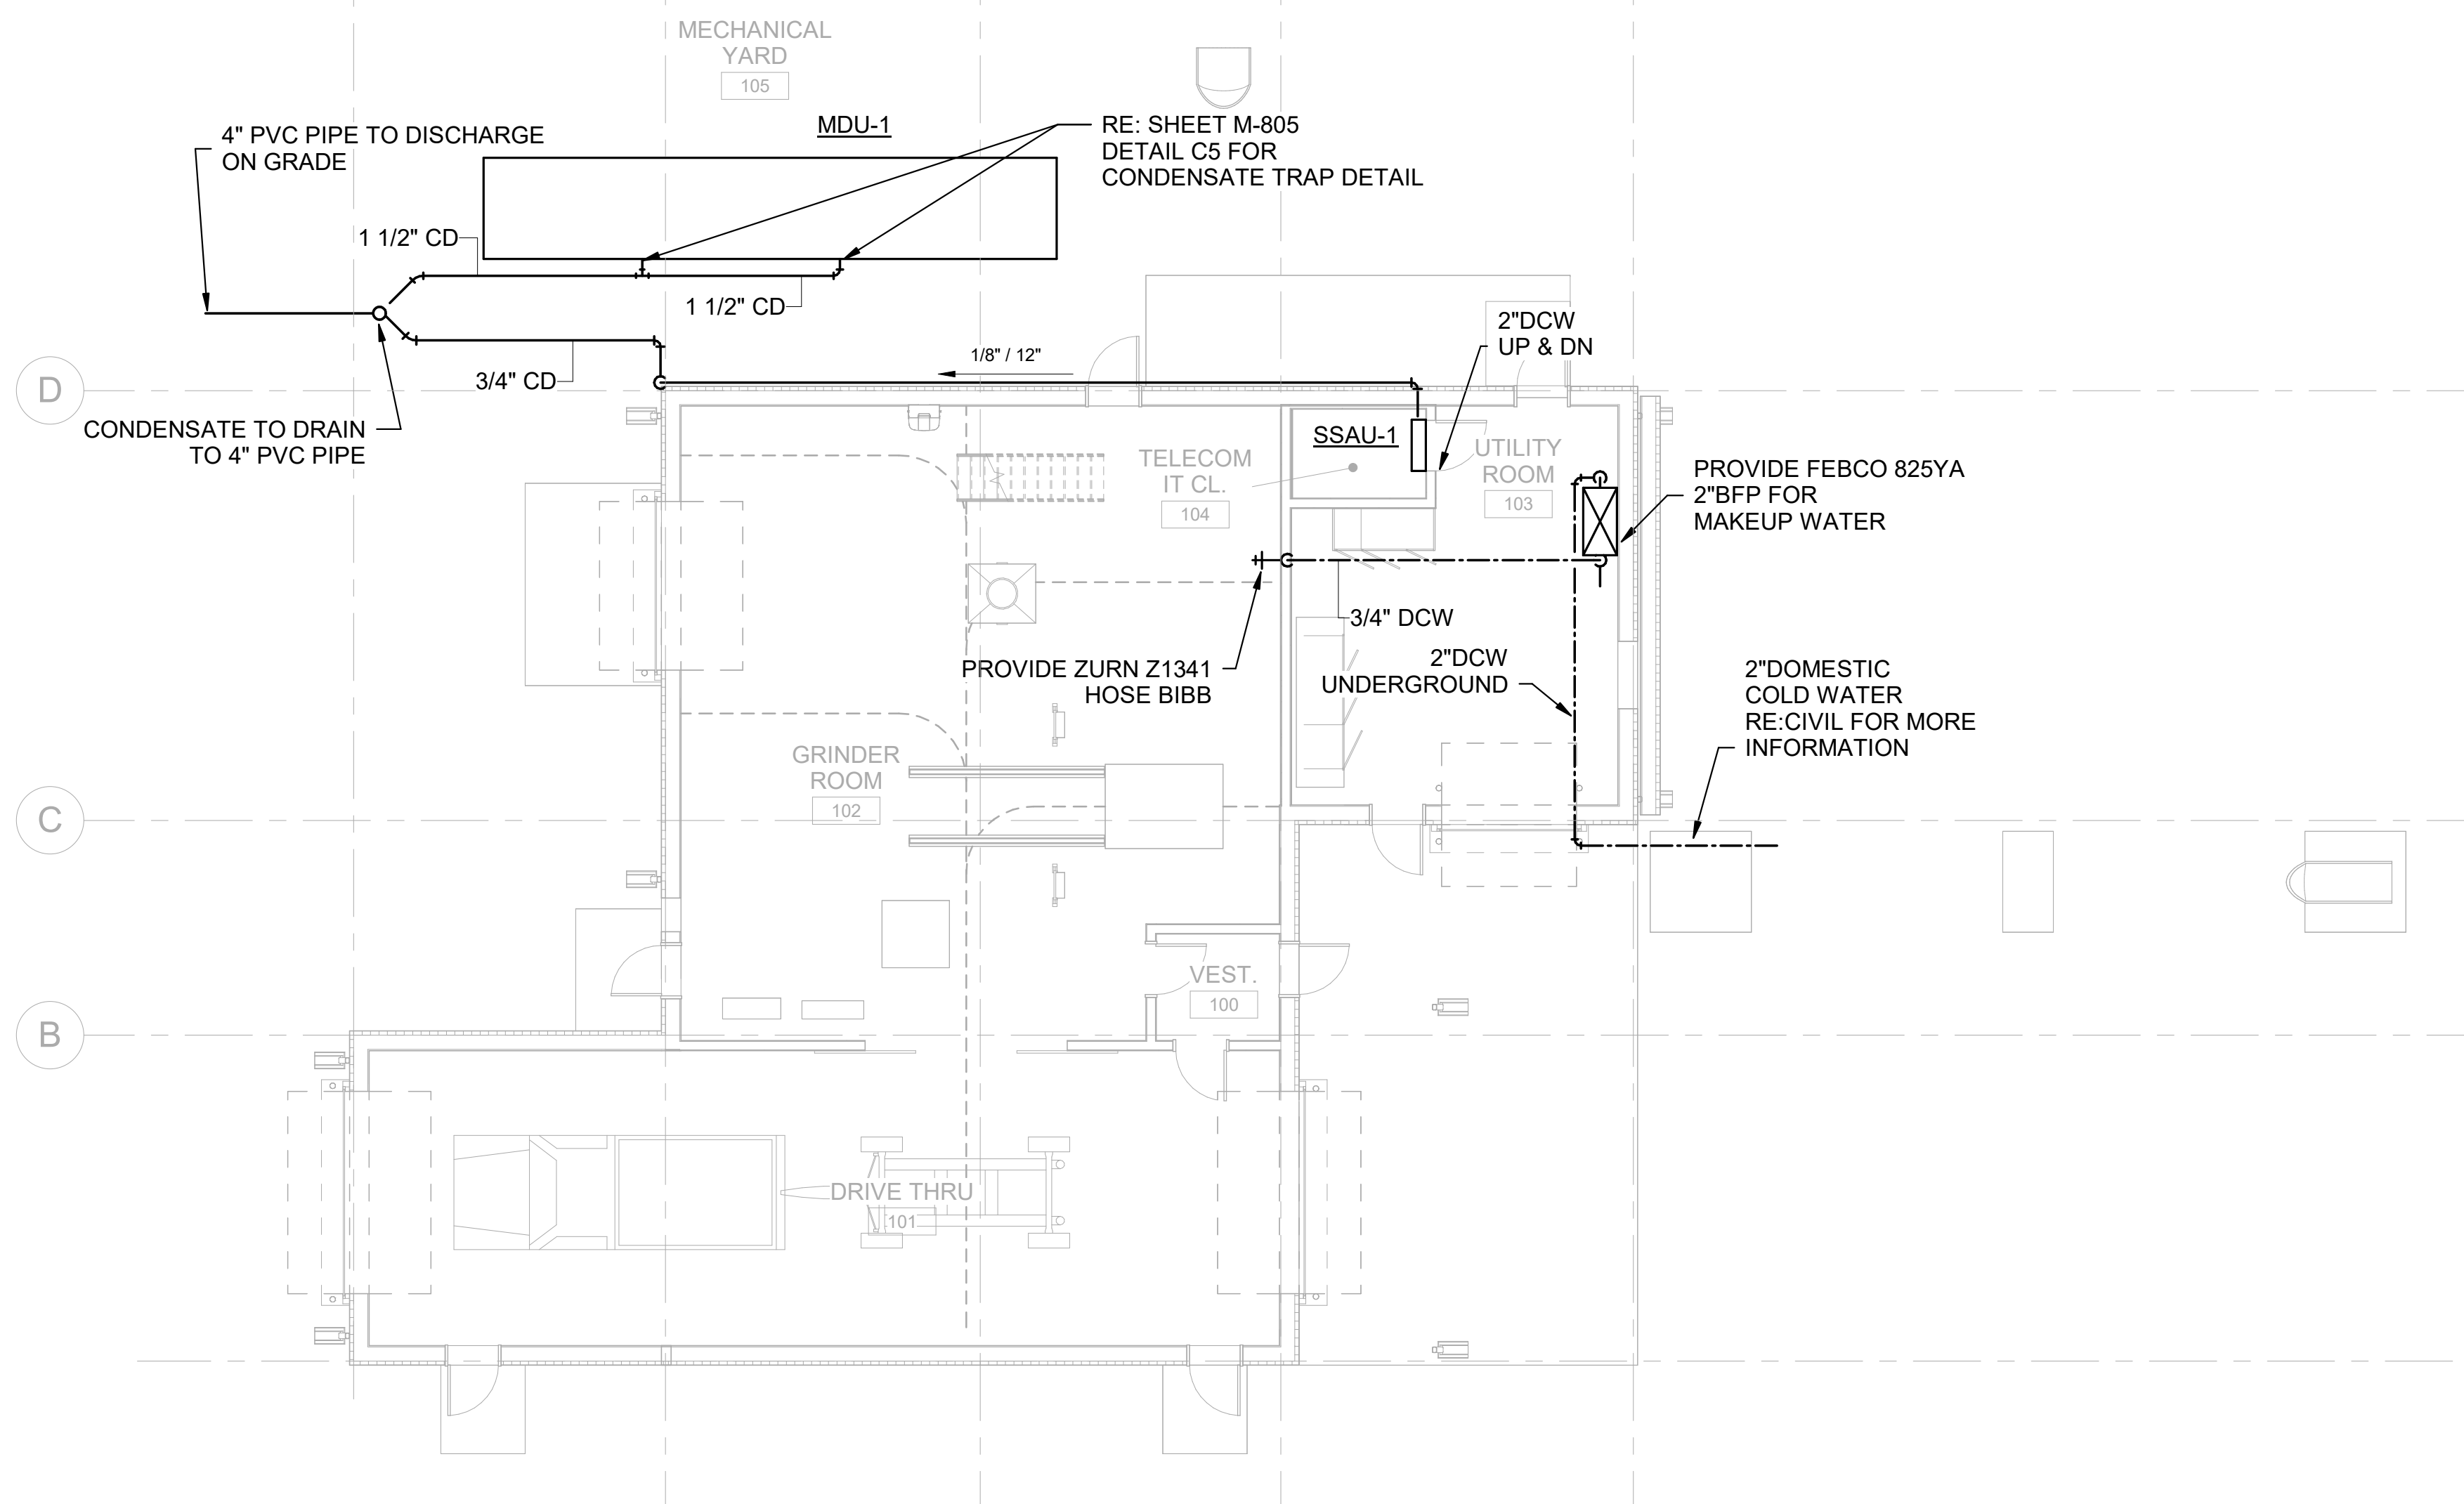

GROUND FLOOR PLAN

SCALE 1/8" = 1'-0"

GRAPHIC SCALE

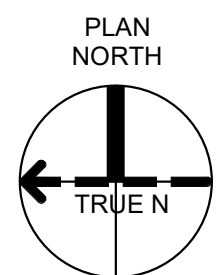

	Grinder Camden OSD Calhoun County, Arkansas Aerojet Rocketdyne
PLUMBING GORUND FLOOR PLAN	
SHEET NO P-100	
SCALE	1/8" = 1'-0"
DATE	09/18/2024
PROJ	D3754502
DWG	CMDR-052, Grinder_P-100

REUSE OF DOCUMENTS: THIS DOCUMENT, AND THE IDEAS AND DESIGNS INCORPORATED HEREIN, AS AN INSTRUMENT OF PROFESSIONAL SERVICE, IS THE PROPERTY OF JACOBS AND IS NOT TO BE USED IN WHOLE OR IN PART FOR ANY OTHER PROJECT WITHOUT THE WRITTEN AUTHORIZATION OF JACOBS.

© Jacobs Solutions 2023. ALL RIGHTS RESERVED.

9/16/2024 11:15:52 AM P-100 Autodesk Docs://US_D3754500_FED_Aerojet Rockeldyne/D37545N0_CMDN_OSD_Grinder_PLUM.rvt