

CROMWELL

1300 East 6th Street Little Rock, AR 72202

501.372.2900

99

BUIL

Design Phase

Stamp

BUIL

乙

CONSTRUCTION

DOCUMENTS

CROMWELL

ARCHITECTS/

ENGINEERS

1. CROMWELL ARCHITECTS ENGINEERS, INC.

2. THIS SHEET DESIGNED FOR COLOR PRINTING.
CRITICAL INFORMATION MAY BE LOST WITH

MECHANICAL DETAILS

ALL RIGHTS RESERVED

Project Number -

Issue Date

Sheet Title

Sheet Number

BLACK AND WHITE PRINTING.

07-31-2024


2024-045

07-31-2024

Date Description


DUPLEX CONDENSATE PUMP
NOT TO SCALE

2 BLOW DOWN SEPARATOR
NOT TO SCALE

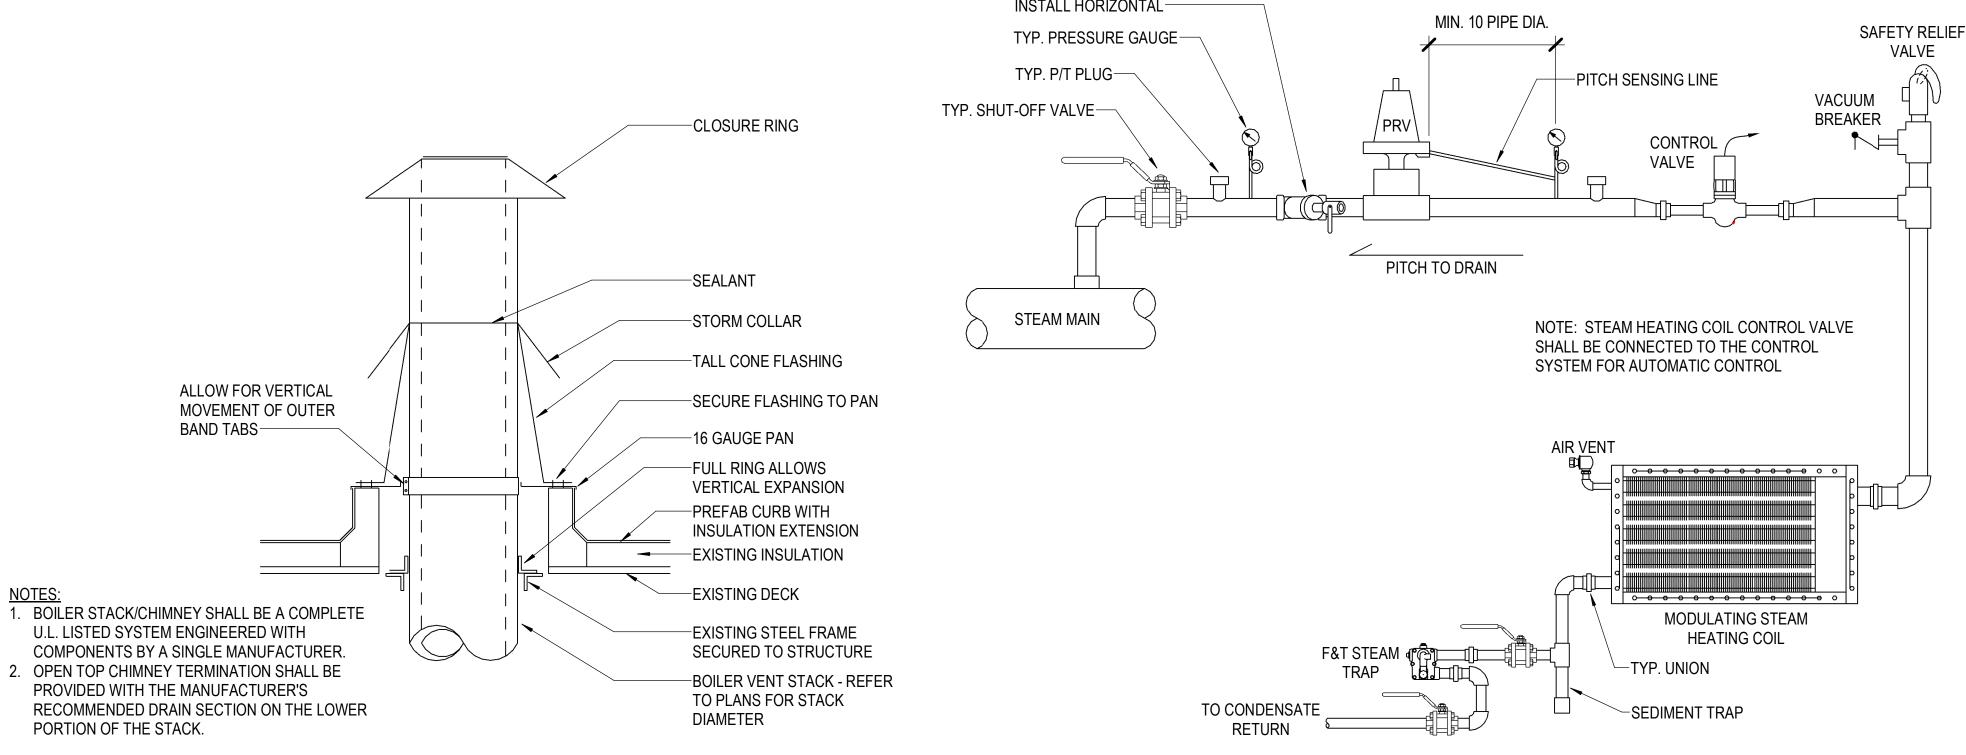

STRAINER W/ BLOWDOWN VALVE -

STEAM HEATING COIL

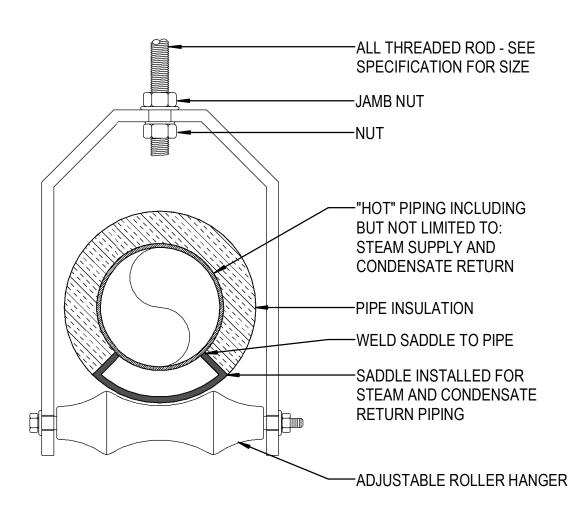

ROLLER PIPE HANGER DETAIL

BOILER FLUE