


COPYRIGHT AND NOTES: THE COPYRIGHT FOR THIS PROJECT IS VESTED IN THE ARCHITECT. VERIFY ALL DIMENSIONS AND LEVELS ON SITE. DISCREPANCIES TO BE REPORTED IMMEDIATELY TO THE ARCHITECT. DRAWINGS TO BE READ IN CONJUNCTION WITH THE SPECIFICATION. DO NOT SCALE OFF DRAWINGS.

PARTIAL WAREHOUSE HVAC PLAN 0 8' 16' 32' SCALE: 1/16" = 1'-0"

M201	M202	M203	M204
M205	M206	M207	M208
KEY PLAN			

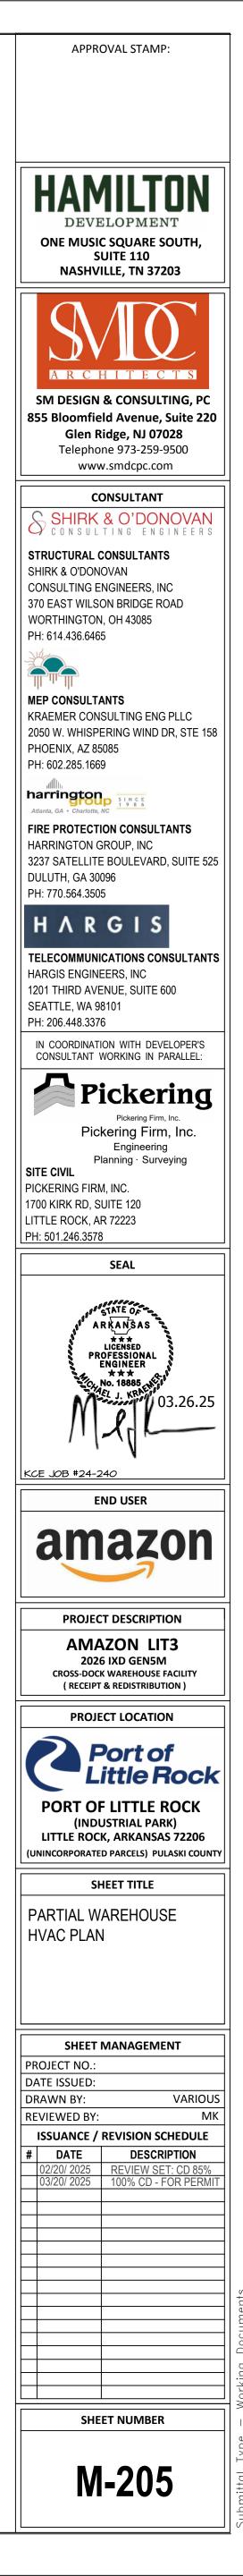

M204

M208