


As indicated 6/16/2026 10:39:24 AM Autodesk Docs/296-031 - ARCare Clinic- For Smith, AR/ARCC MEP.rvt

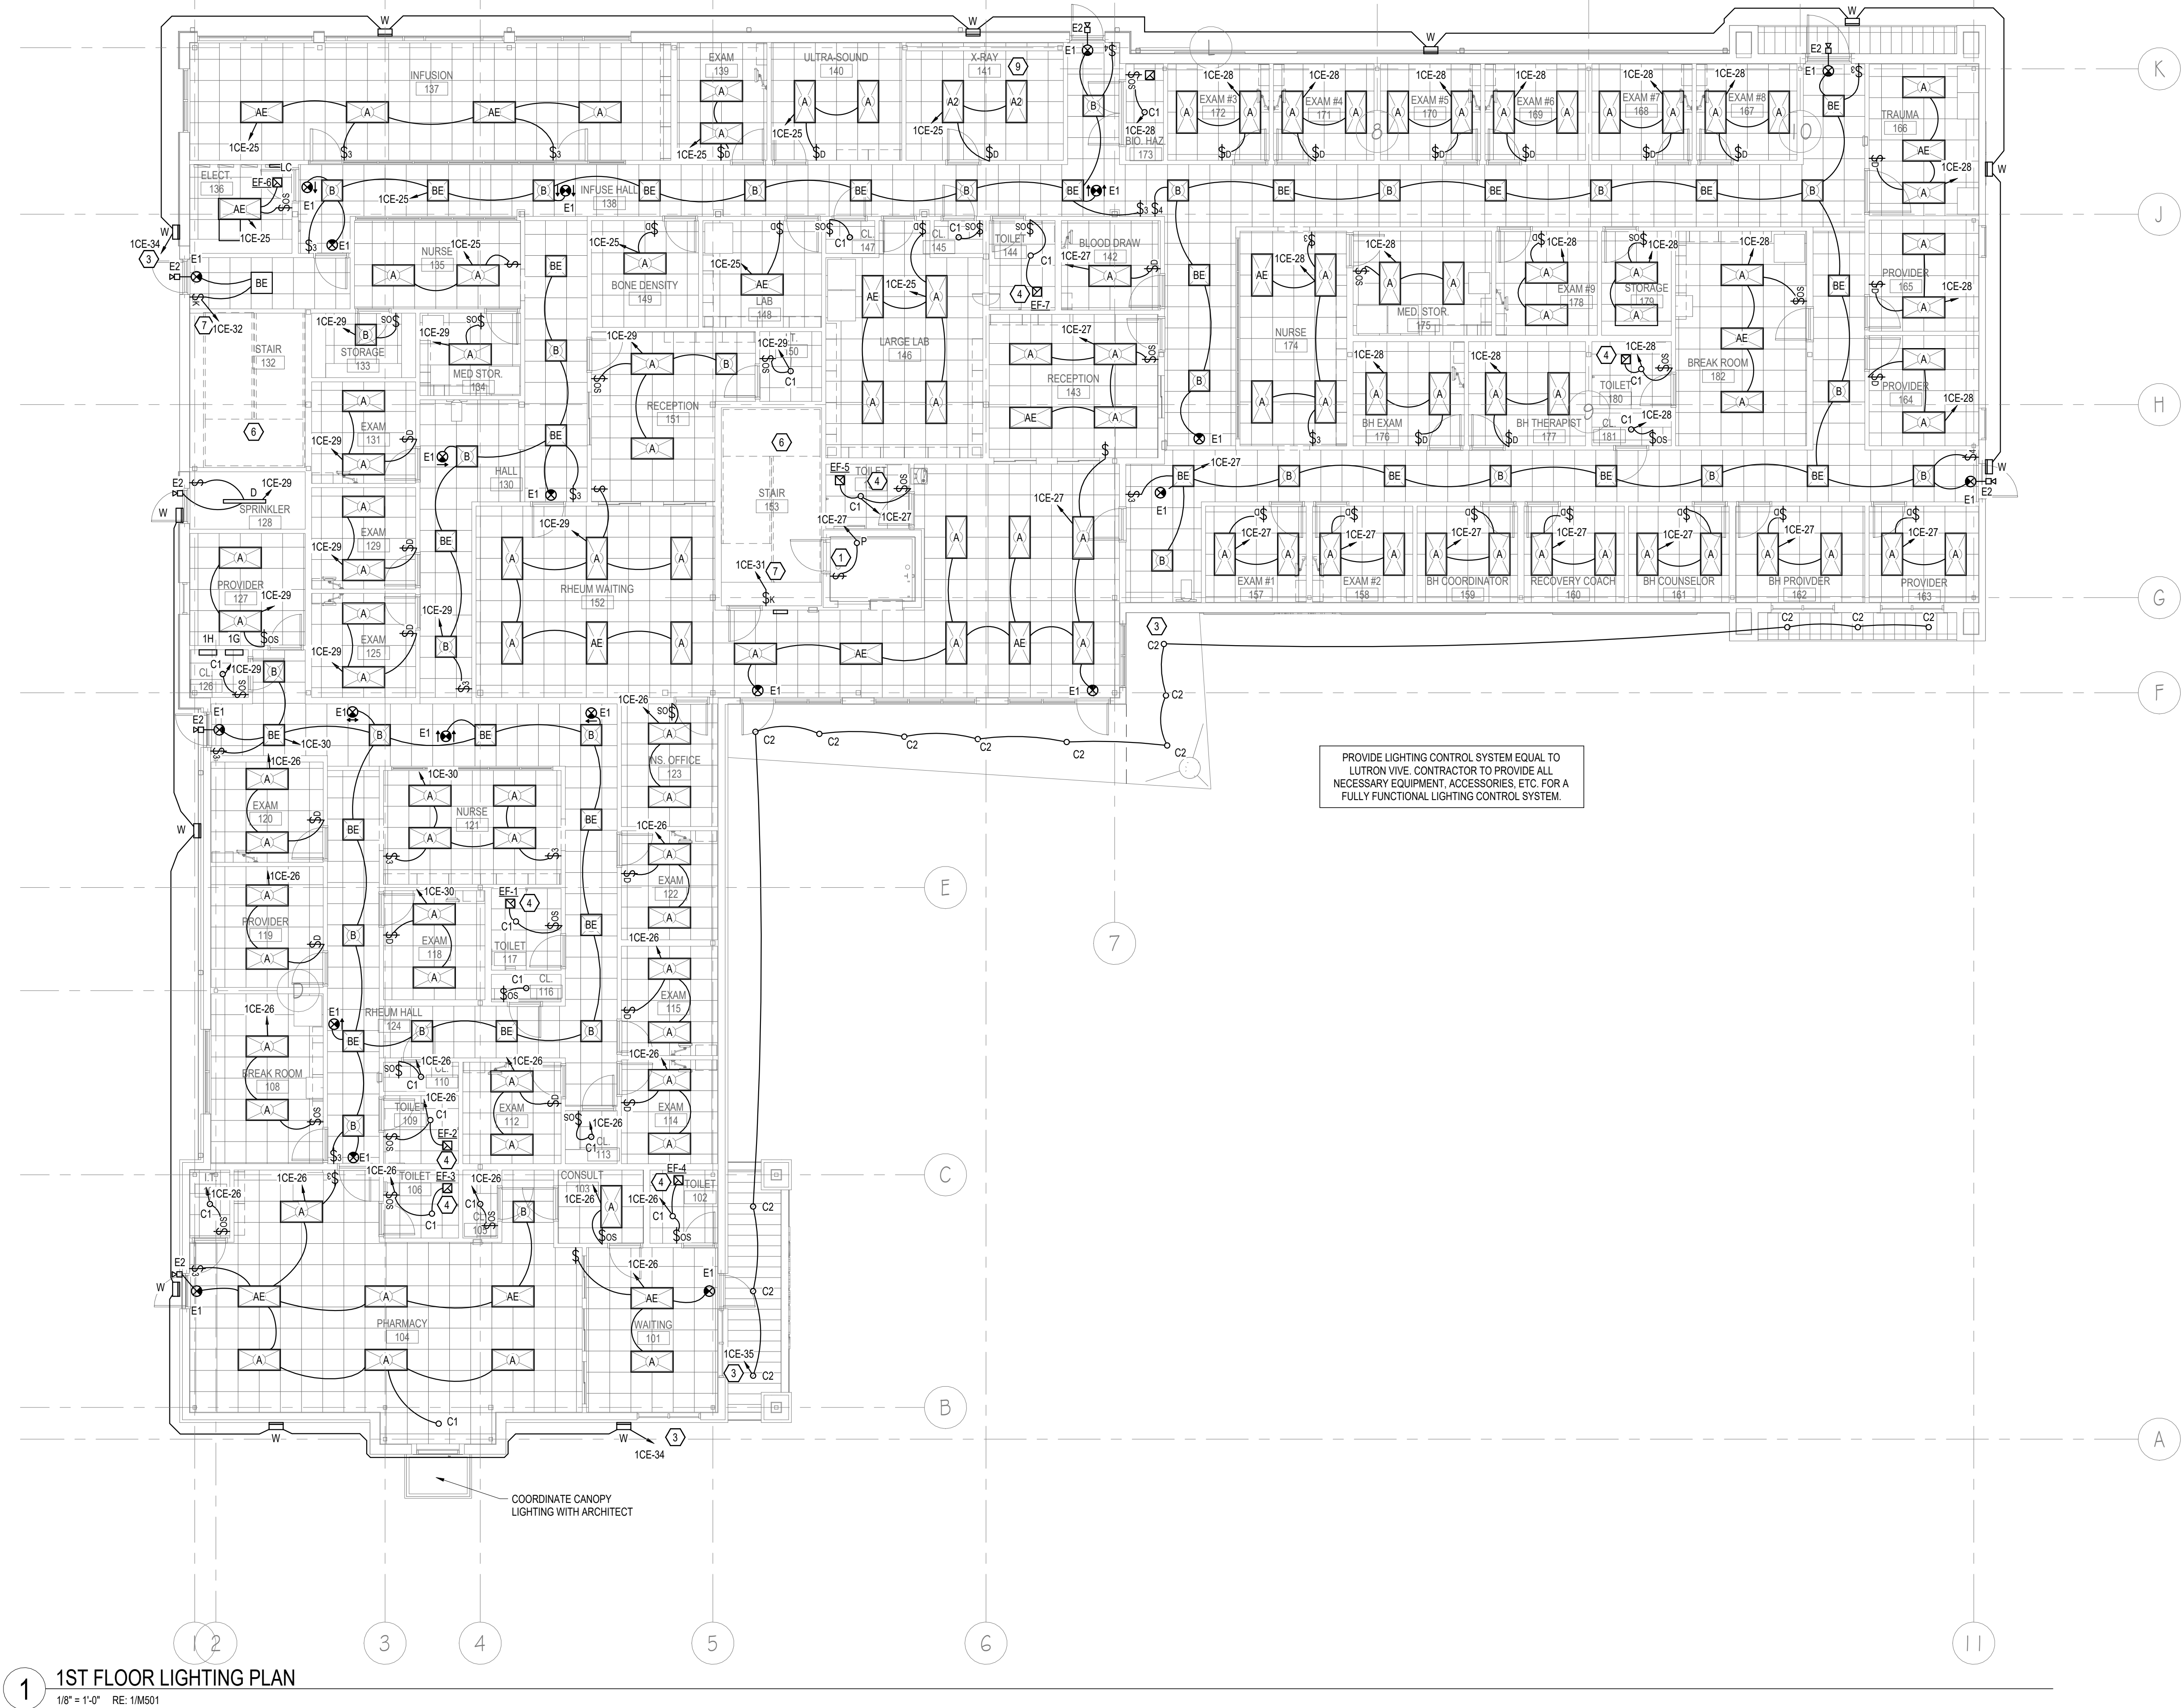

KEYED LIGHTING NOTES

- LOCATE SWITCH FOR ELEVATOR PIT LIGHTING NEAR LADDER.
- INSTALL LIGHT FIXTURE AT TOP OF ELEVATOR SHAFT. LOCATE SWITCH PER ELEVATOR MANUFACTURER REQUIREMENTS.
- SEE EXTERIOR LIGHTING DETAIL FOR LIGHTING POWER AND CONTROL. LIGHTING SHALL ENERGIZE WITH PHOTOCELL/TIME CLOCK FOR DUSK TO DAWN OPERATION.
- EXHAUST FAN TO BE ENERGIZED WITH LIGHTING CIRCUIT THIS ROOM. PROVIDE ALL NECESSARY RELAYS AND CONTRACTORS. COORDINATE WITH OTHER ROOMS CONNECTED TO SAME EXHAUST FAN. WIRE PER FAN MANUFACTURER RECOMMENDATIONS. RE: HVAC PLANS.
- JUNCTION BOX MOUNTED BEHIND EXTERIOR BUILDING SIGNAGE. VERIFY EXACT LOCATION, QUANTITY, AND MOUNTING HEIGHTS WITH ARCHITECT AND SIGN CONTRACTOR PRIOR TO ROUGH IN. INSTALL PER SIGN CONTRACTOR REQUIREMENTS. SIGN LIGHTING SHALL BE CONTROLLED WITH EXTERIOR BUILDING LIGHTING.
- LIGHTING IN STAIRWELL TO MAINTAIN CONSTANT POWER. PROVIDE ALL NECESSARY BATTER PACKS, CONTACTORS, RELAYS, ETC. TO MAINTAIN POWER DURING OUTAGES.
- LIGHTING CONTROL TO FIXTURES ABOVE. SEE ADDITIONAL LIGHTING PLANS FOR CIRCUIT CONTINUATION.
- TO LIGHTING CONTROLS BELOW. SEE ADDITIONAL LIGHTING PLANS FOR CIRCUIT CONTINUATION.
- COORDINATE ALL LIGHTING AND POWER SHIELDING REQUIREMENTS IN X-RAY ROOM WITH MEDICAL EQUIPMENT CONSULTANT.



KEY ARCHITECTURE INC.
P.O. BOX 748 FAYETTEVILLE, ARKANSAS 72702
PH: 479.444.6066 FAX: 479.444.1445

FOR PERMIT & CONSTRUCTION

Revision Schedule		Description	
Rev. #	Date	Rev. #	Date
NEW Arcare MEDICAL OFFICE BUILDING 2709 Massard Rd FT. SMITH, AR 72903			
Arcare 117 S. 2ND ST. AUGUSTA, AR 72006			

DATE 06-15-2026	DRAWN BY CH
PROJECT # 2517	CHECKED BY JT
SHEET E102 1ST FLOOR LIGHTING PLAN	

TERRELL
ENGINEERING CONSULTANTS
310 W. MAIN ST. SUITE C
RUSSELLVILLE, AR 72801
PHONE (479) 595-8177
WWW.TERRELLENG.COM
AR FIRM # 3434