


As indicated 6/16/2026 10:39:30 AM Autodesk Docs//26-031 - ARCare Clinic- Fort Smith, AR/ARCC MEP.rvt

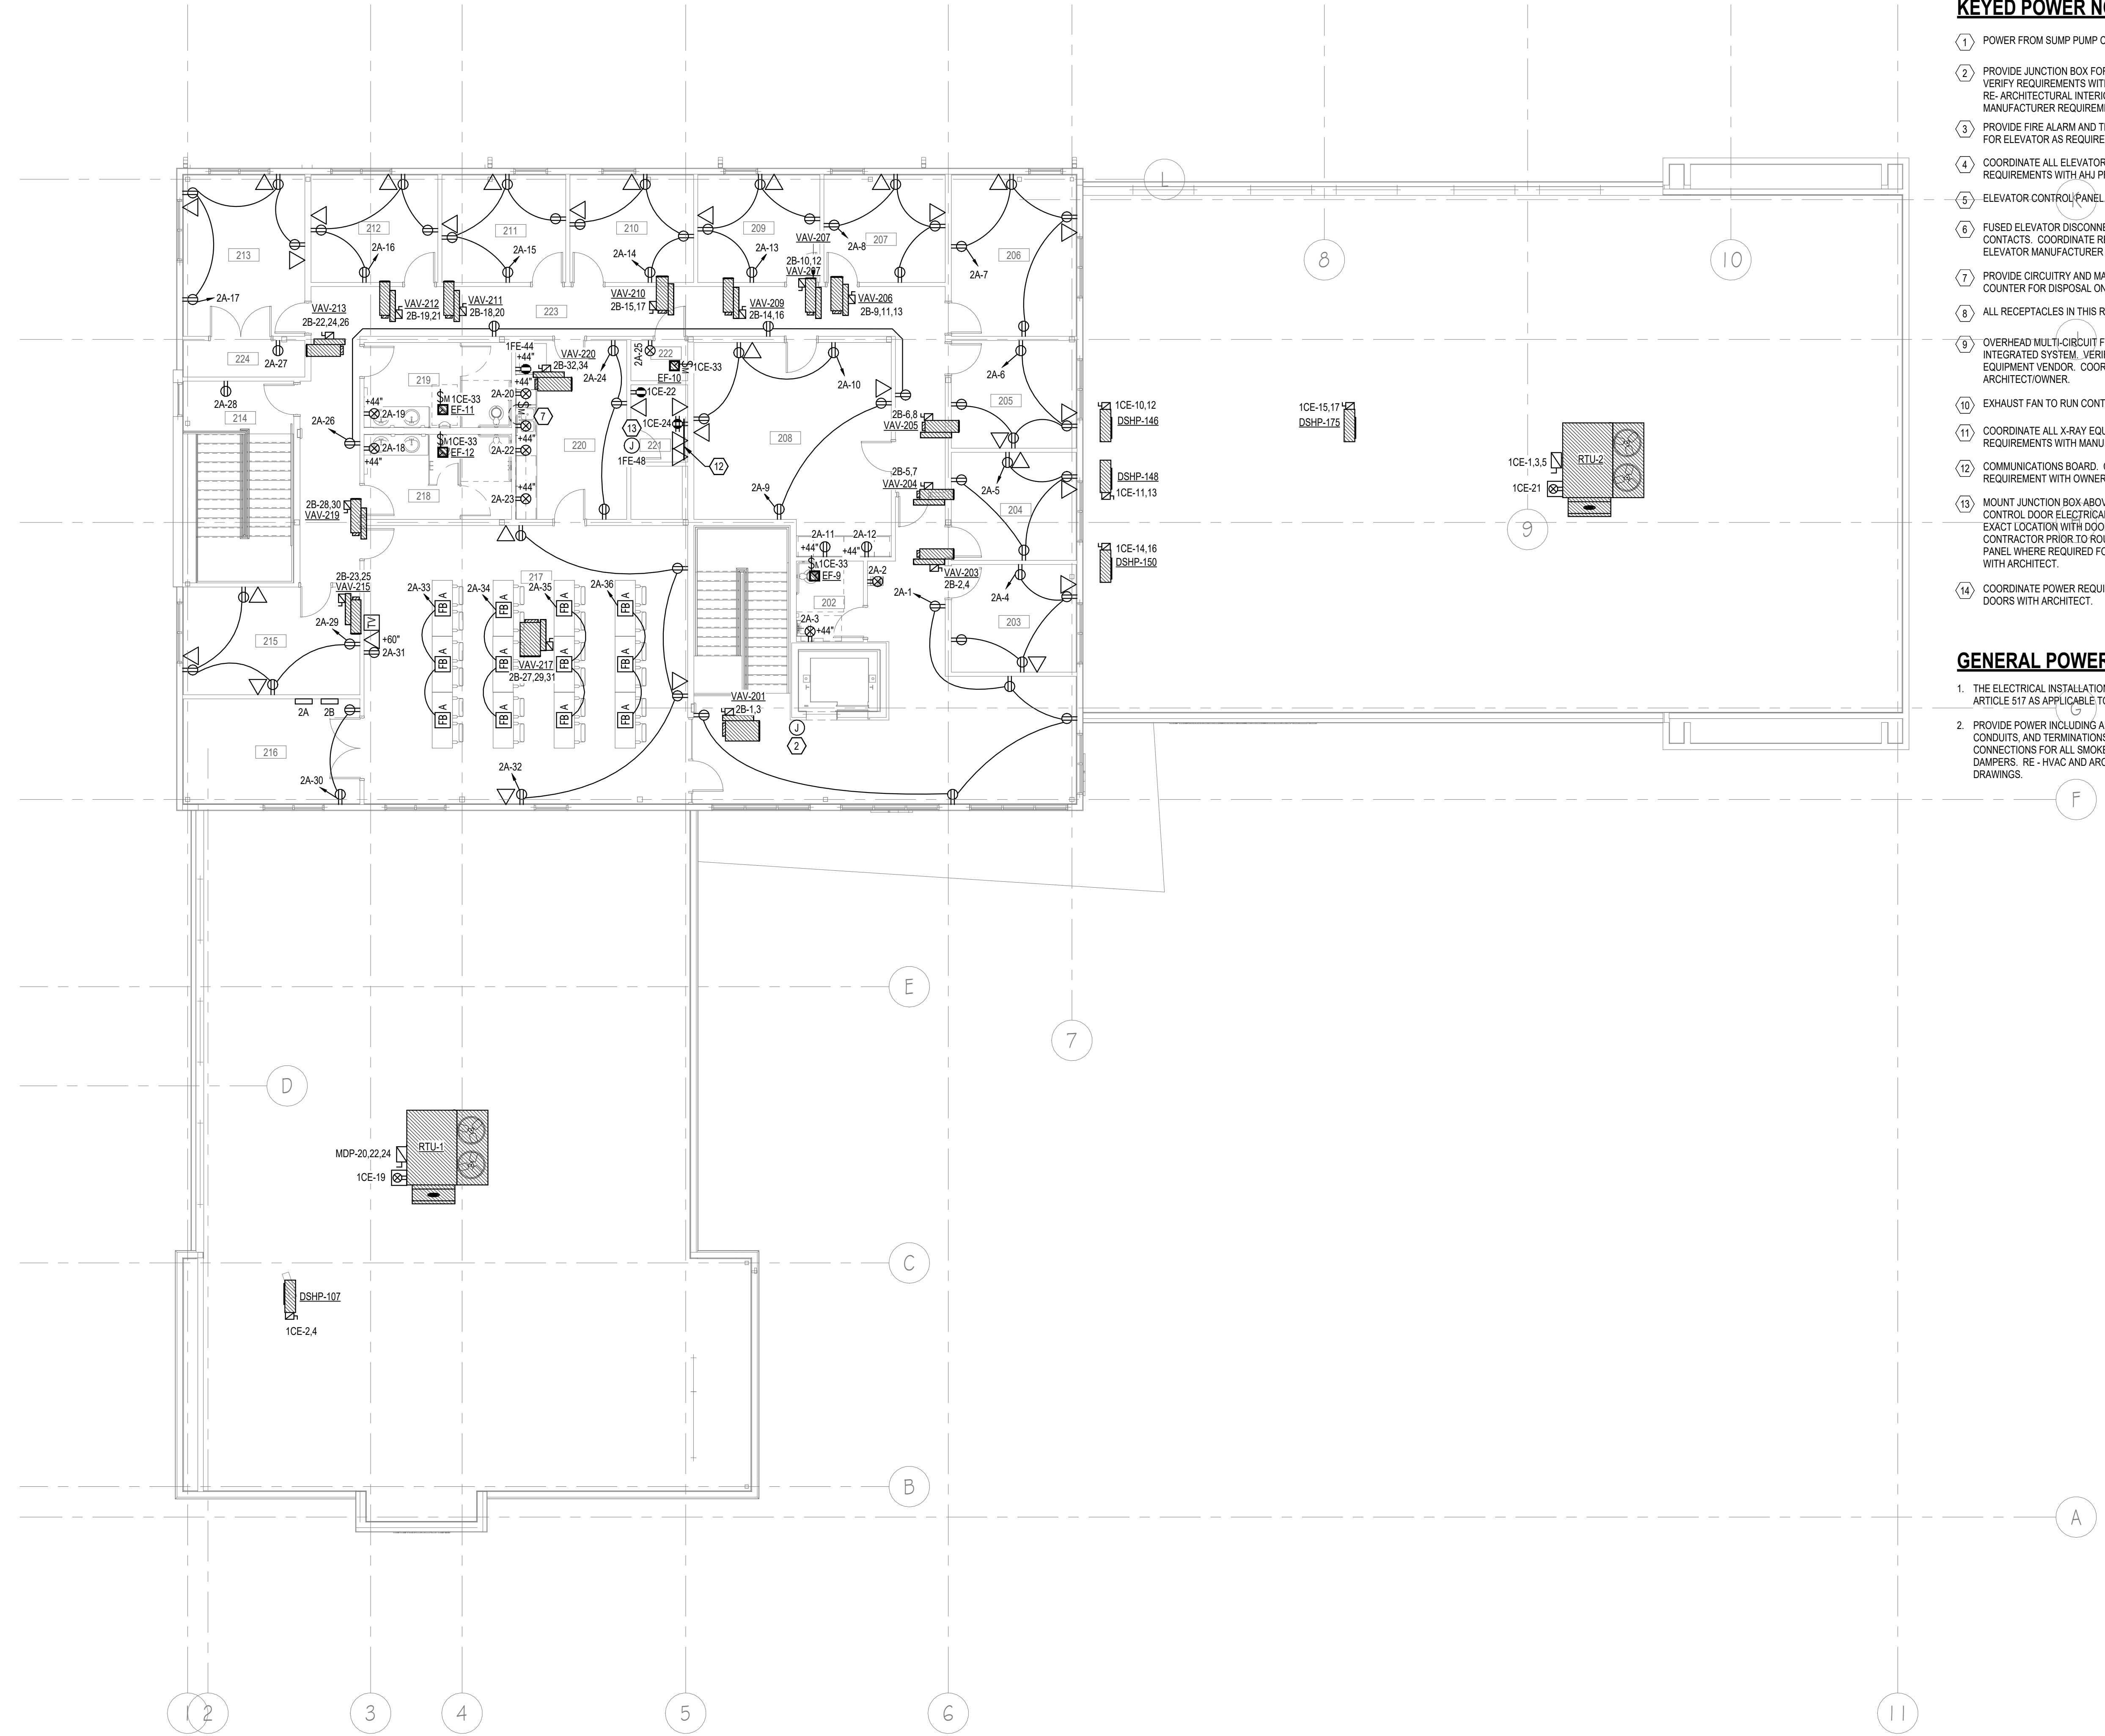

1 2ND FLOOR POWER PLAN
1/8" = 1'-0" RE: 1/M501

KEYED POWER NOTES

- POWER FROM SUMP PUMP CONTROL PANEL.
- PROVIDE JUNCTION BOX FOR ELEVATOR CONTROLS. VERIFY REQUIREMENTS WITH ELEVATOR MANUFACTURER. RE- ARCHITECTURAL INTERIOR ELEVATIONS AND MANUFACTURER REQUIREMENTS.
- PROVIDE FIRE ALARM AND TELECOMMUNICATION OUTLETS FOR ELEVATOR AS REQUIRED.
- COORDINATE ALL ELEVATOR AND EQUIPMENT REQUIREMENTS WITH AHJ PRIOR TO ROUGH-IN.
- ELEVATOR CONTROL PANEL.
- FUSED ELEVATOR DISCONNECT WITH AUXILIARY CONTACTS. COORDINATE REQUIREMENTS WITH ELEVATOR MANUFACTURER PRIOR TO ROUGH-IN.
- PROVIDE CIRCUITRY AND MANUAL SWITCH ABOVE COUNTER FOR DISPOSAL ON/OFF CONTROL.
- ALL RECEPTACLES IN THIS ROOM ARE 4" AFF.
- OVERHEAD MULTI-CIRCUIT FEED FOR VITROS 5600 INTEGRATED SYSTEM. VERIFY REQUIREMENTS WITH EQUIPMENT VENDOR. COORDINATE PLACEMENT WITH ARCHITECT/OWNER.
- EXHAUST FAN TO RUN CONTINUOUSLY. RE - MECHANICAL.
- COORDINATE ALL X-RAY EQUIPMENT POWER AND DATA REQUIREMENTS WITH MANUFACTURER.
- COMMUNICATIONS BOARD. COORDINATE LOCATION AND REQUIREMENT WITH OWNER. RE - DETAILS.
- MOUNT JUNCTION BOX ABOVE CEILING FOR ACCESS. CONTROL DOOR ELECTRICAL COMPONENTS. VERIFY EXACT LOCATION WITH DOOR HARDWARE AND SECURITY CONTRACTOR PRIOR TO ROUGH-IN. PROVIDE ACCESS PANEL WHERE REQUIRED FOR ACCESS. COORDINATE WITH ARCHITECT.
- COORDINATE POWER REQUIREMENTS FOR MAIN ACCESS DOORS WITH ARCHITECT.

GENERAL POWER NOTES

- THE ELECTRICAL INSTALLATION SHALL COMPLY WITH NEC ARTICLE 517 AS APPLICABLE TO THIS FACILITY.
- PROVIDE POWER INCLUDING ALL CONDUCTORS, CONDUITS, AND TERMINATIONS AND FIRE ALARM CONNECTIONS FOR ALL SMOKE AND FIRE/SMOKE DAMPERS. RE - HVAC AND ARCHITECTURAL LIFE SAFETY DRAWINGS.



310 W. MAIN ST. SUITE C
RUSSELLVILLE, AR 72801
PHONE (479) 595-8177

WWW.TERRELLENG.COM

AR FIRM # 3434



KEY ARCHITECTURE INC.
P.O. BOX 748 FAYETTEVILLE, ARKANSAS 72702
PH: 479.444.6066 FAX: 479.444.1445

FOR PERMIT & CONSTRUCTION

Revision Schedule	
Rev. #	Date
Description	

NEW Arcare MEDICAL OFFICE BUILDING
2709 Massard Rd
FT. SMITH, AR 72903

Arcare
117 S. 2ND ST.
AUGUSTA, AR 72006

DATE 06-15-2026	DRAWN BY CH
PROJECT # 2517	CHECKED BY JT

SHEET
E105
2ND FLOOR POWER PLAN

These Drawings and Specifications are the exclusive property of Key Architecture Inc. and are protected by Copyright. Use or reproduction is prohibited without written consent.