



As indicated 6/16/2026 10:39:34 AM Autodesk Docs://26-031 - ARCare Clinic- Fort Smith, AR/ARCC MEP.rvt

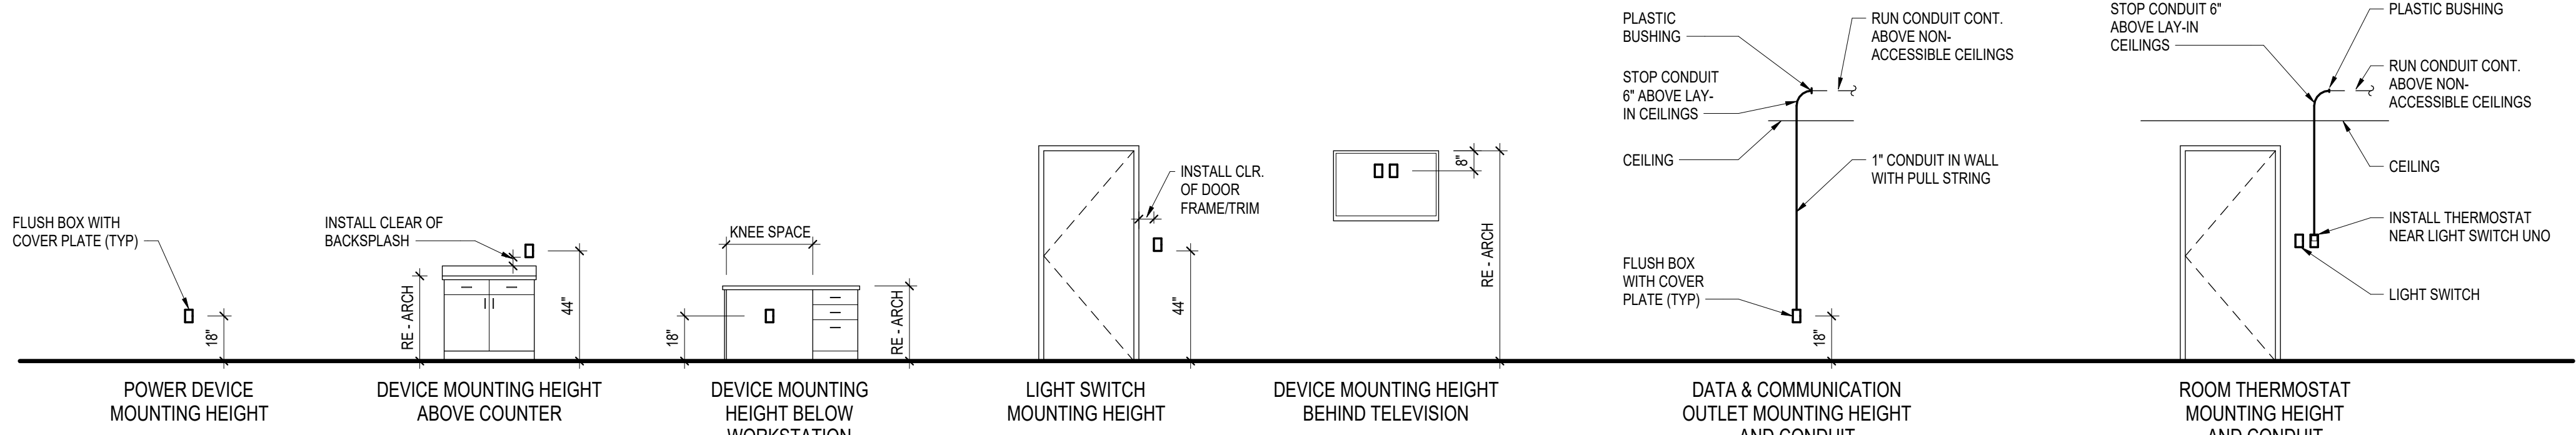

1 TYPICAL DEVICE MOUNTING ELEVATIONS
1/4" = 1'-0"

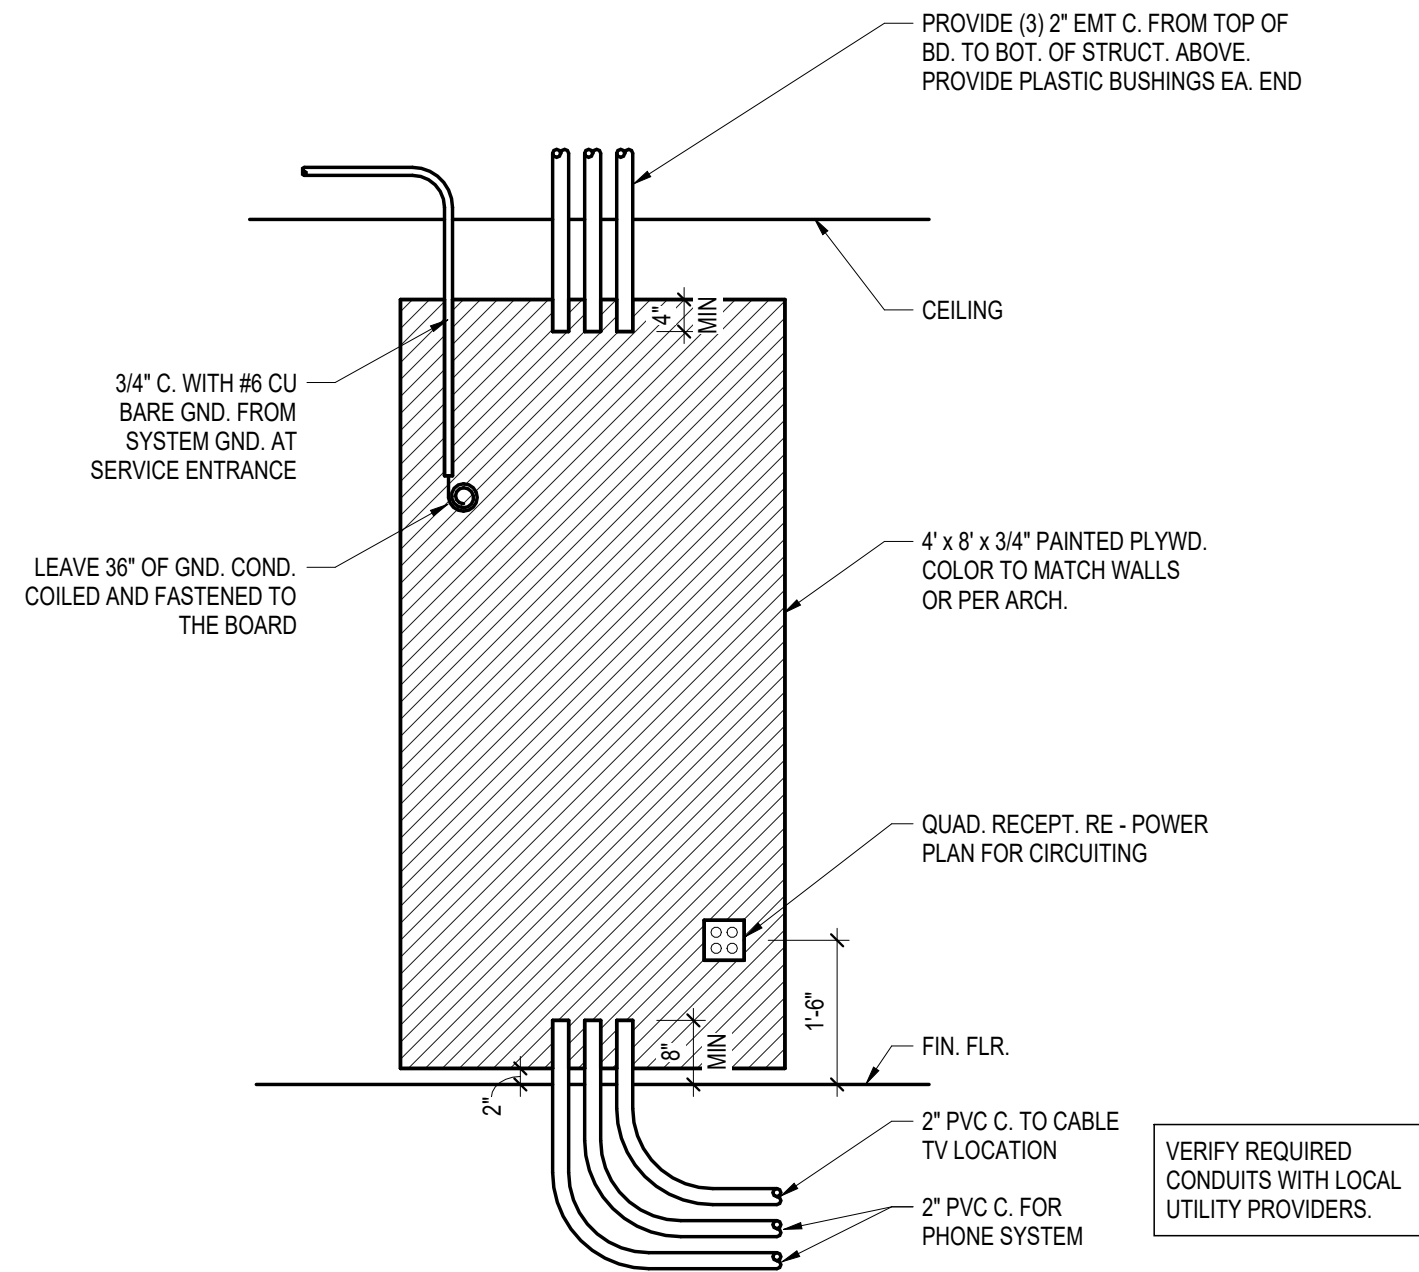

2 COMMUNICATION BOARD DETAIL
1/2" = 1'-0"

TERRELL
ENGINEERING CONSULTANTS

310 W. MAIN ST. SUITE C
RUSSELLVILLE, AR 72801
PHONE (479) 595-8177

WWW.TERRELLENG.COM

AR FIRM # 3434



KEY ARCHITECTURE INC.

P.O. BOX 748 FAYETTEVILLE, ARKANSAS 72702
PH: 479.444.6066 FAX: 479.444.1445

FOR PERMIT & CONSTRUCTION

Revision Schedule	
Rev. #	Description

NEW Arcare MEDICAL OFFICE BUILDING 2709 Massard Rd FT. SMITH, AR 72903	Arcare 117 S. 2ND ST. AUGUSTA, AR 72006
--	---

DATE 06-15-2026	DRAWN BY CH
PROJECT # 2517	CHECKED BY JT
SHEET E502 ELECTRICAL DETAILS	

These Drawings and Specifications are the exclusive property of Key Architecture Inc. and are protected by Copyright. Use or reproduction is prohibited without written consents.