


NOT TO SCALE 06/06/2026 10:39:34 AM Autodesk Docs://26-031 - ARCare Clinic- For Smith, AR/ARCC MEP.rvt

LIGHTING FIXTURE SCHEDULE											
MARK	DESCRIPTION	BASIS OF DESIGN		CONSTRUCTION		LIGHT SOURCE			ELECTRICAL		NOTES
		MANUF.	MODEL	MOUNTING	FINISH	LAMP	CCT	LUMENS	VOLTAGE	WATTAGE	
								DOWN			
A	2x4 RECESSED TROFFER	H.E. WILLIAMS INC.	FT-24-LS-8CS-AF-DIM-UNV_392_3500K	CEILING	PER ARCHITECT	LED	3,500 K	5,765 lm	120 V	39 W	1.3
A2	2x4 SURFACE MOUNT KIT	H.E. WILLIAMS INC.	FT-24-LS-8CS-AF-DIM-UNV_392_3500K	SURFACE	PER ARCHITECT	LED	3,500 K	5,765 lm	120 V	39 W	3.5
AE	2x4 RECESSED TROFFER W/EMERGENCY	H.E. WILLIAMS INC.	FT-24-LS-8CS-AF-DIM-UNV_392_3500K_EM	CEILING	PER ARCHITECT	LED	3,500 K	5,765 lm	120 V	39 W	13.5
B	2x2 RECESSED TROFFER	H.E. WILLIAMS INC.	FT-22-LS-8CS-AF-DIM-UNV_33W_3500K	CEILING	PER ARCHITECT	LED	3,500 K	4,380 lm	120 V	33 W	1.3
BE	2x2 RECESSED TROFFER W/EMERGENCY	H.E. WILLIAMS INC.	FT-22-LS-8CS-AF-DIM-UNV_33W_3500K_EM	CEILING	PER ARCHITECT	LED	3,500 K	4,380 lm	120 V	33 W	13.5
C1	6" DOWNLIGHT	WILLIAMS INDOOR	6DR-TL-L15-835-DIM-UNV-LW-OF-CS	RECESSED	PER ARCHITECT	LED	3,500 K	1,178 lm	120 V	14 W	13.7
C2	6" DOWNLIGHT (EXTERIOR)	WILLIAMS INDOOR	6DR-TL-L30-835-DIM-UNV-LW-OF-CS	RECESSED	PER ARCHITECT	LED	3,500 K	2,335 lm	120 V	27 W	13.8
D	48" STRIP LIGHT	WILLIAMS INDOOR	FS-4L-S-8CS-DIM-UNV_32W_3500K	SURFACE	PER ARCHITECT	LED	3,500 K	4,677 lm	120 V	32 W	13.5,7
E1	EXIT SIGN	ILP	EXE1-U-S-2RW-B	CEILING	PER ARCHITECT	LED			120 V	3 W	12.3
E2	REMOTE EMERGENCY LIGHT	ILP	EXR1-WHS-WL	WALL	PER ARCHITECT	LED			120 V	1 W	34.8
P	ELEVATOR PIT LIGHT	ATLAS	ORVP2L4K	WALL/CEILING	PER ARCHITECT	LED	3,000 K	2,000 lm	120 V	20 W	13.8,9
SA1	SITE LIGHTING (SINGLE)	LSI INDUSTRIES, INC.	MRM-LED-24L-SIL-R-UNV-DIM-40-70-X 4SQA-B5-A125-25-X-X	25 FT POLE	PER ARCHITECT	LED	4,000 K	25,600 lm	120 V	160 W	3.8,10
SA2	AREA LIGHT (DUAL)	LSI INDUSTRIES, INC.	MRM-LED-24L-SIL-R-UNV-DIM-40-70-X 4SQA-B5-A125-25-X-X	25 FT POLE	PER ARCHITECT	LED	4,000 K	25,600 lm	120 V	320 W	3.8,10
W	WALL PACK	BEACON	QSP2-160L-50-4K7-4F	WALL	PER ARCHITECT	LED	4,000 K	7,700 lm	120 V	57 W	3.8,10


- LIGHTING FIXTURE SCHEDULE NOTES:**
- DO NOT SUPPORT FIXTURE FROM CEILING GRID. SUPPORT SECURELY FROM STRUCTURE ABOVE.
 - POWER FROM A NON-SWITCHED POWER SOURCE.
 - COORDINATE MOUNTING LOCATION AND HEIGHT WITH ARCHITECT PRIOR TO ROUGH-IN.
 - POWER FROM NEAREST EMERGENCY FIXTURE WITH BATTERY BACKUP AND REMOTE CAPABILITY.
 - LIGHTING SHALL BE SUPPLIED AND INSTALLED WITH SURFACE MOUNTING KIT.
 - DIRECTIONAL EGRESS ARROWS SHALL BE COORDINATED WITH ARCHITECTURAL LIFE SAFETY PLANS.
 - UL LISTED FOR DAMP LOCATION.
 - UL LISTED FOR WET LOCATION.
 - WIRE GUARD.
 - POWER SWITCHED BY EXTERIOR LIGHTING CONTACTOR. CONTACTOR SHALL BE OPERATED BY PHOTOCELL AND TIMER FOR DUSK TO DAWN OPERATION.

COORDINATE ALL LIGHTING FIXTURES AND FINISHES WITH OWNER PRIOR TO ORDERING.

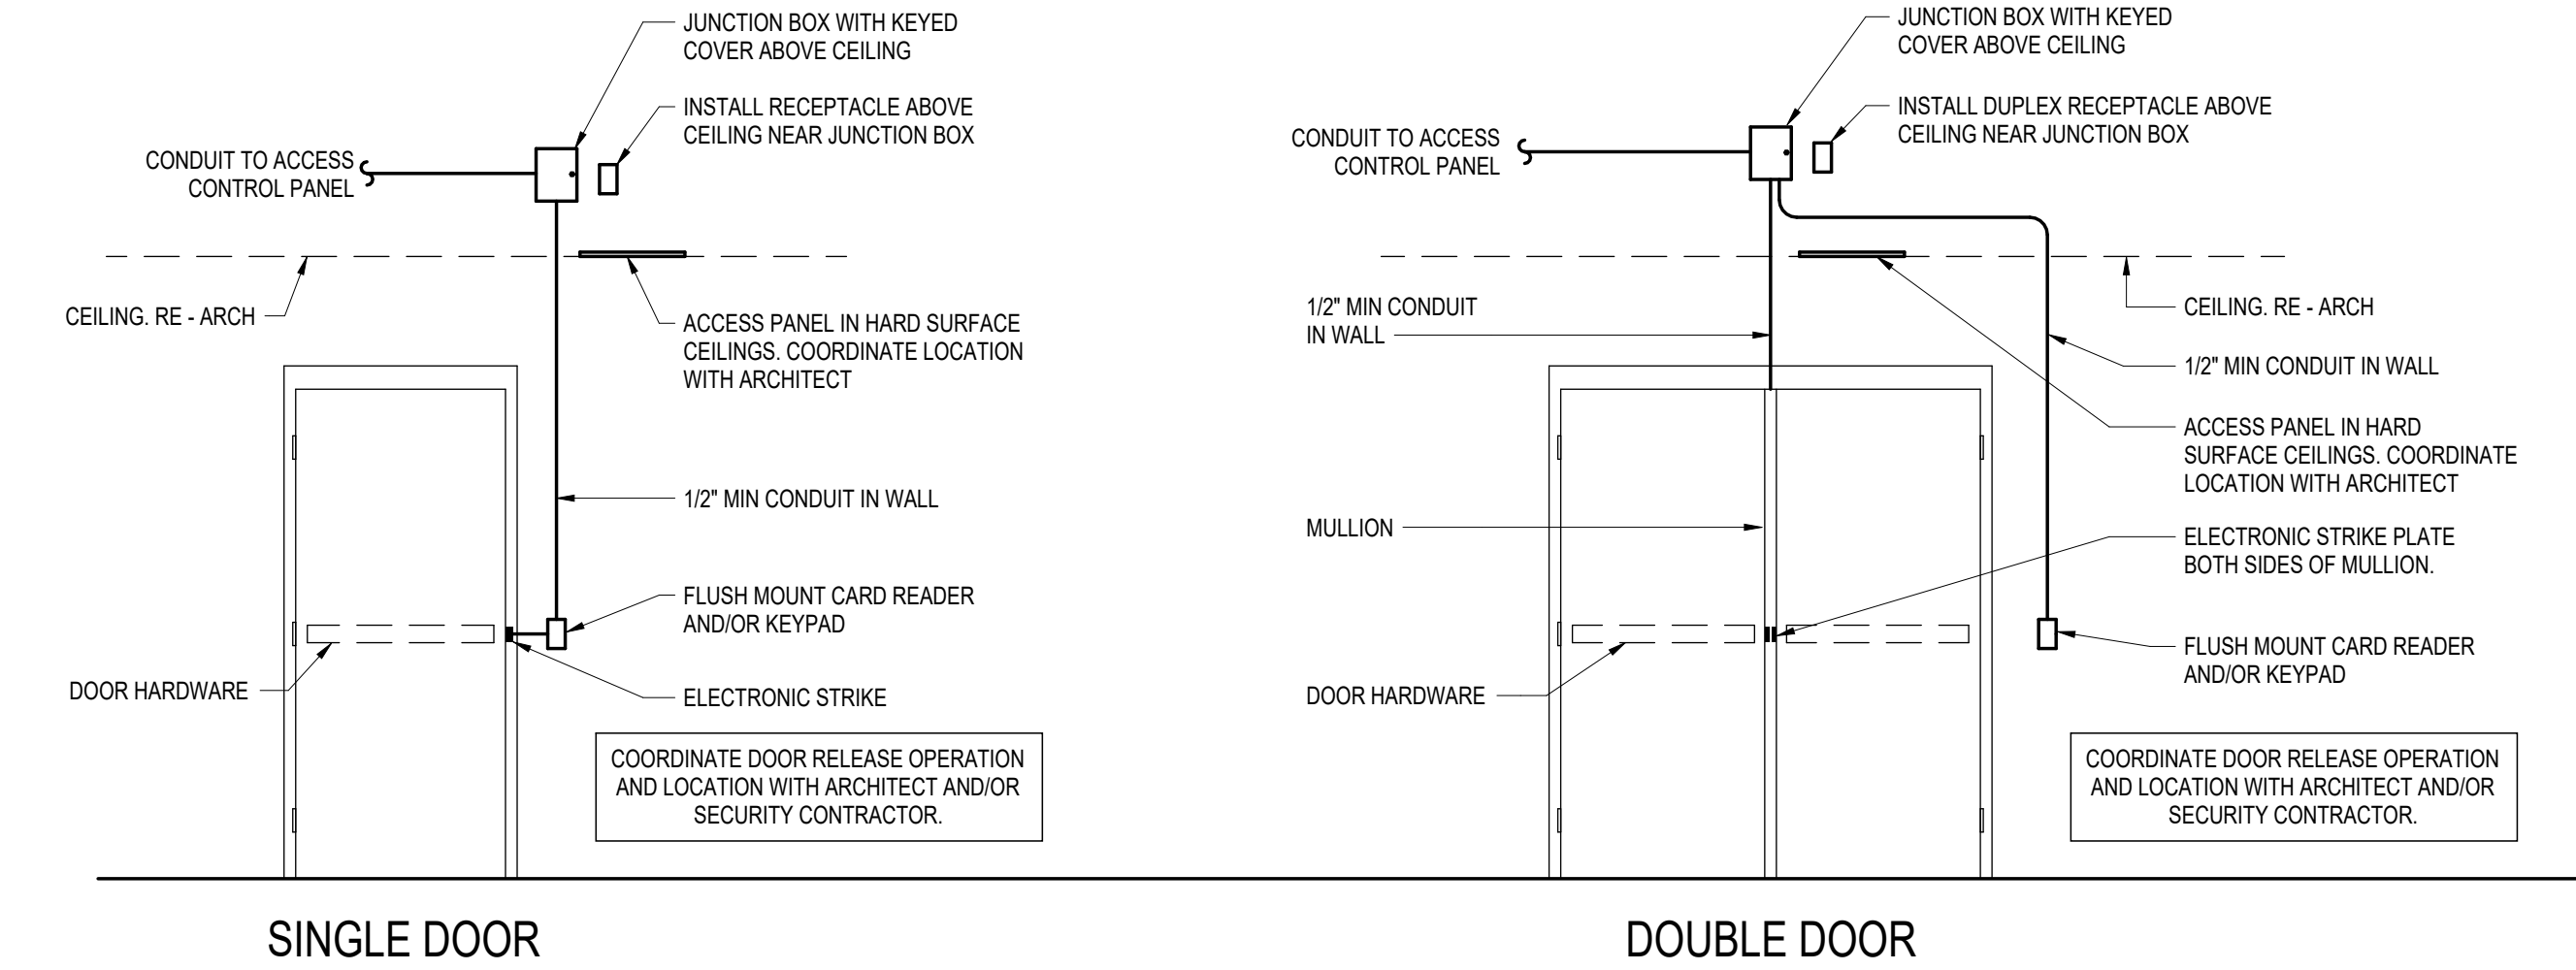

1 TYPICAL DOOR SECURE ACCESS (ELECTRIC STRIKE)

NOT TO SCALE

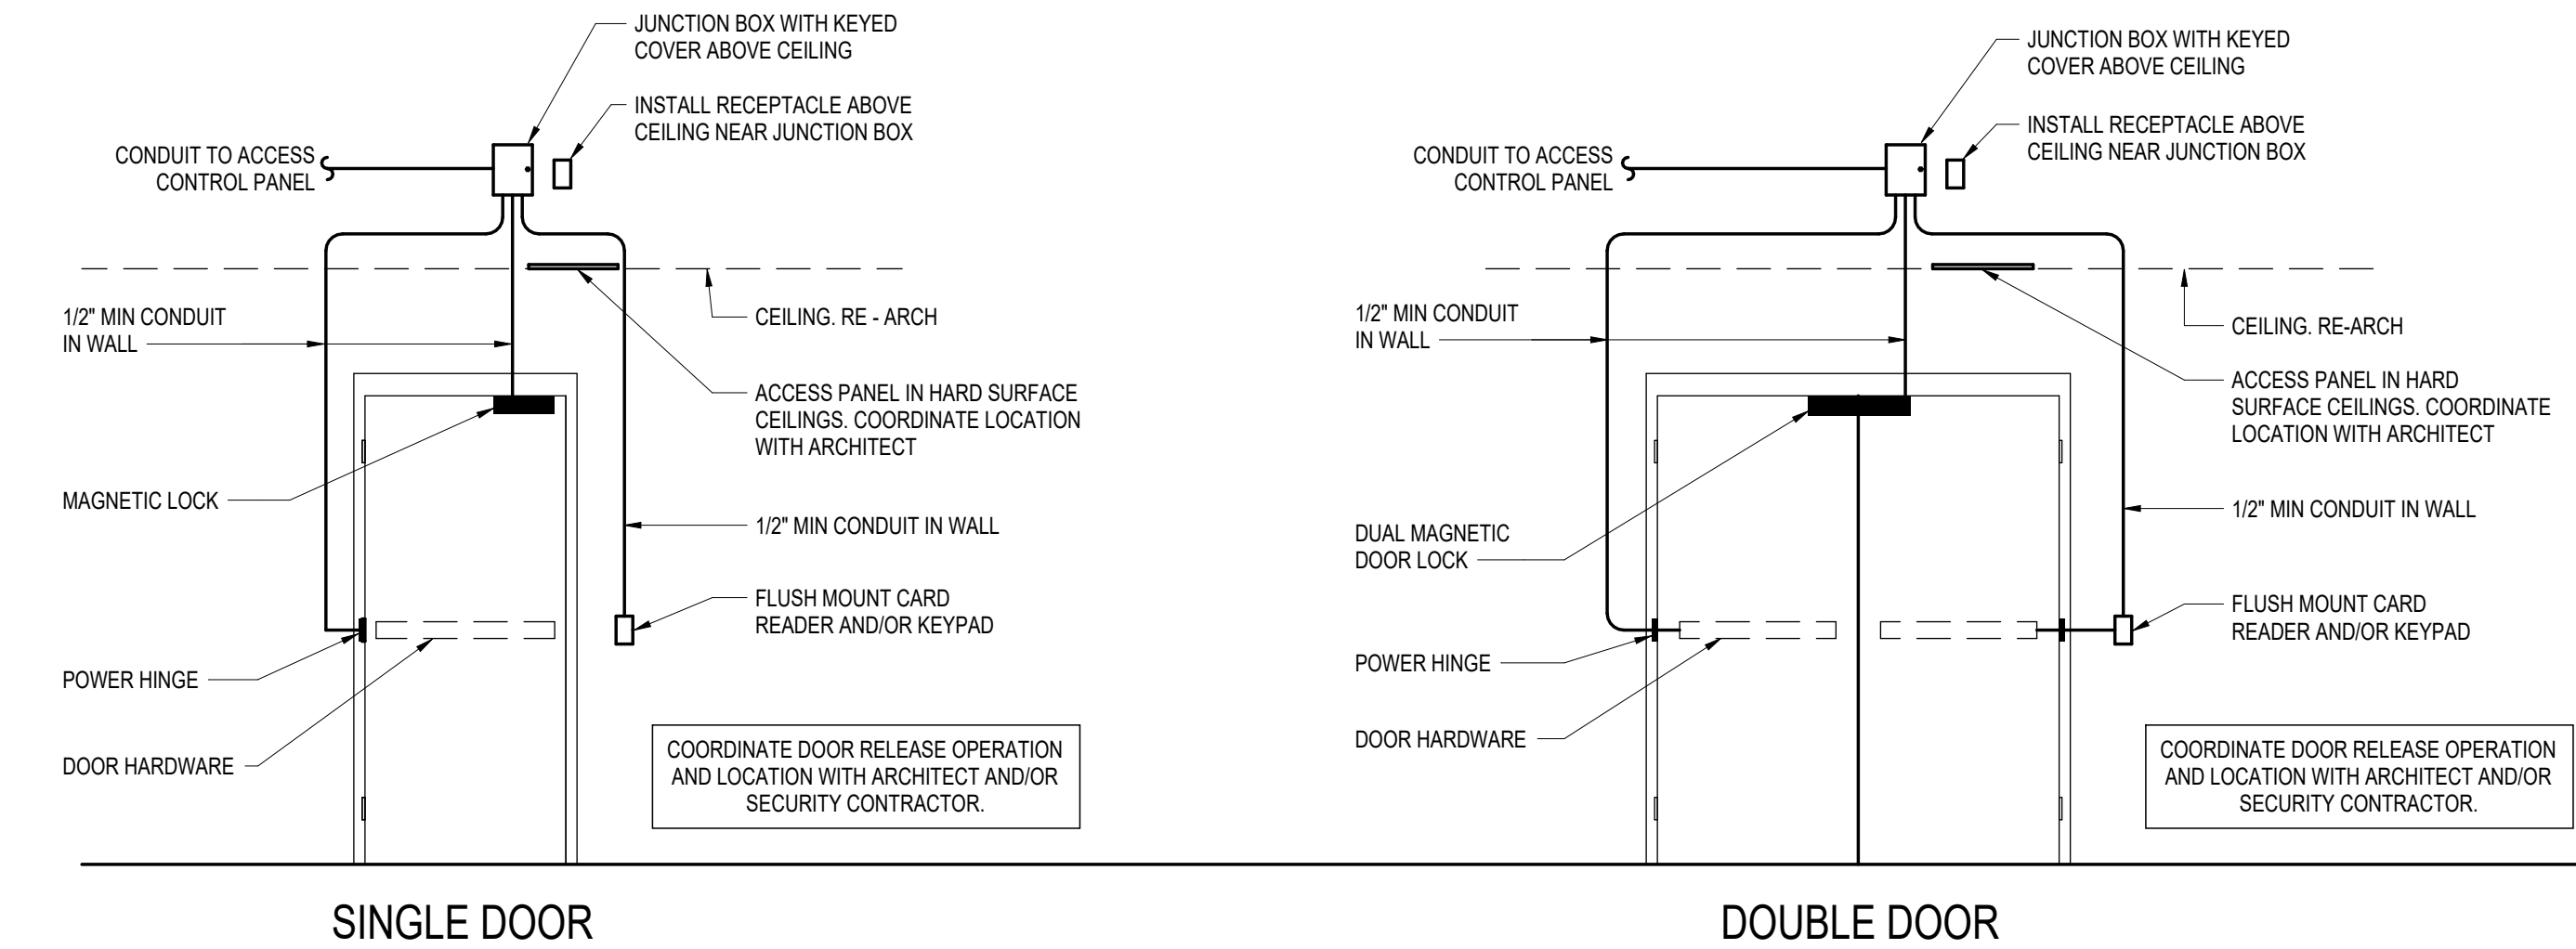

2 TYPICAL DOOR SECURE ACCESS (MAGNETIC LOCK)

NOT TO SCALE

TERRELL
ENGINEERING CONSULTANTS

310 W. MAIN ST. SUITE C
RUSSELLVILLE, AR 72801
PHONE (479) 595-8777
WWW.TERRELLENG.COM

AR FIRM # 3434



KEY ARCHITECTURE INC.

P.O. BOX 748 FAYETTEVILLE, ARKANSAS 72702
PH: 479.444.6066 FAX: 479.444.1445

FOR PERMIT & CONSTRUCTION

Revision Schedule	Rev. #	Date	Description

NEW Arcare MEDICAL OFFICE BUILDING
2709 Massard Rd
FT. SMITH, AR 72903

Arcare
117 S. 2ND ST.
AUGUSTA, AR 72006

DATE 06-15-2026	DRAWN BY CH
PROJECT # 2517	CHECKED BY JT
SHEET E601 ELECTRICAL SCHEDULES	

These Drawings and Specifications are the exclusive property of Key Architecture Inc. and are protected by Copyright. Use or reproduction is prohibited without written consents.