


As indicated 6/16/2026 10:38:19 AM Autodesk Docs://26-031 - ARCare Clinic- For Smith, AR/ARCC MEP.rvt

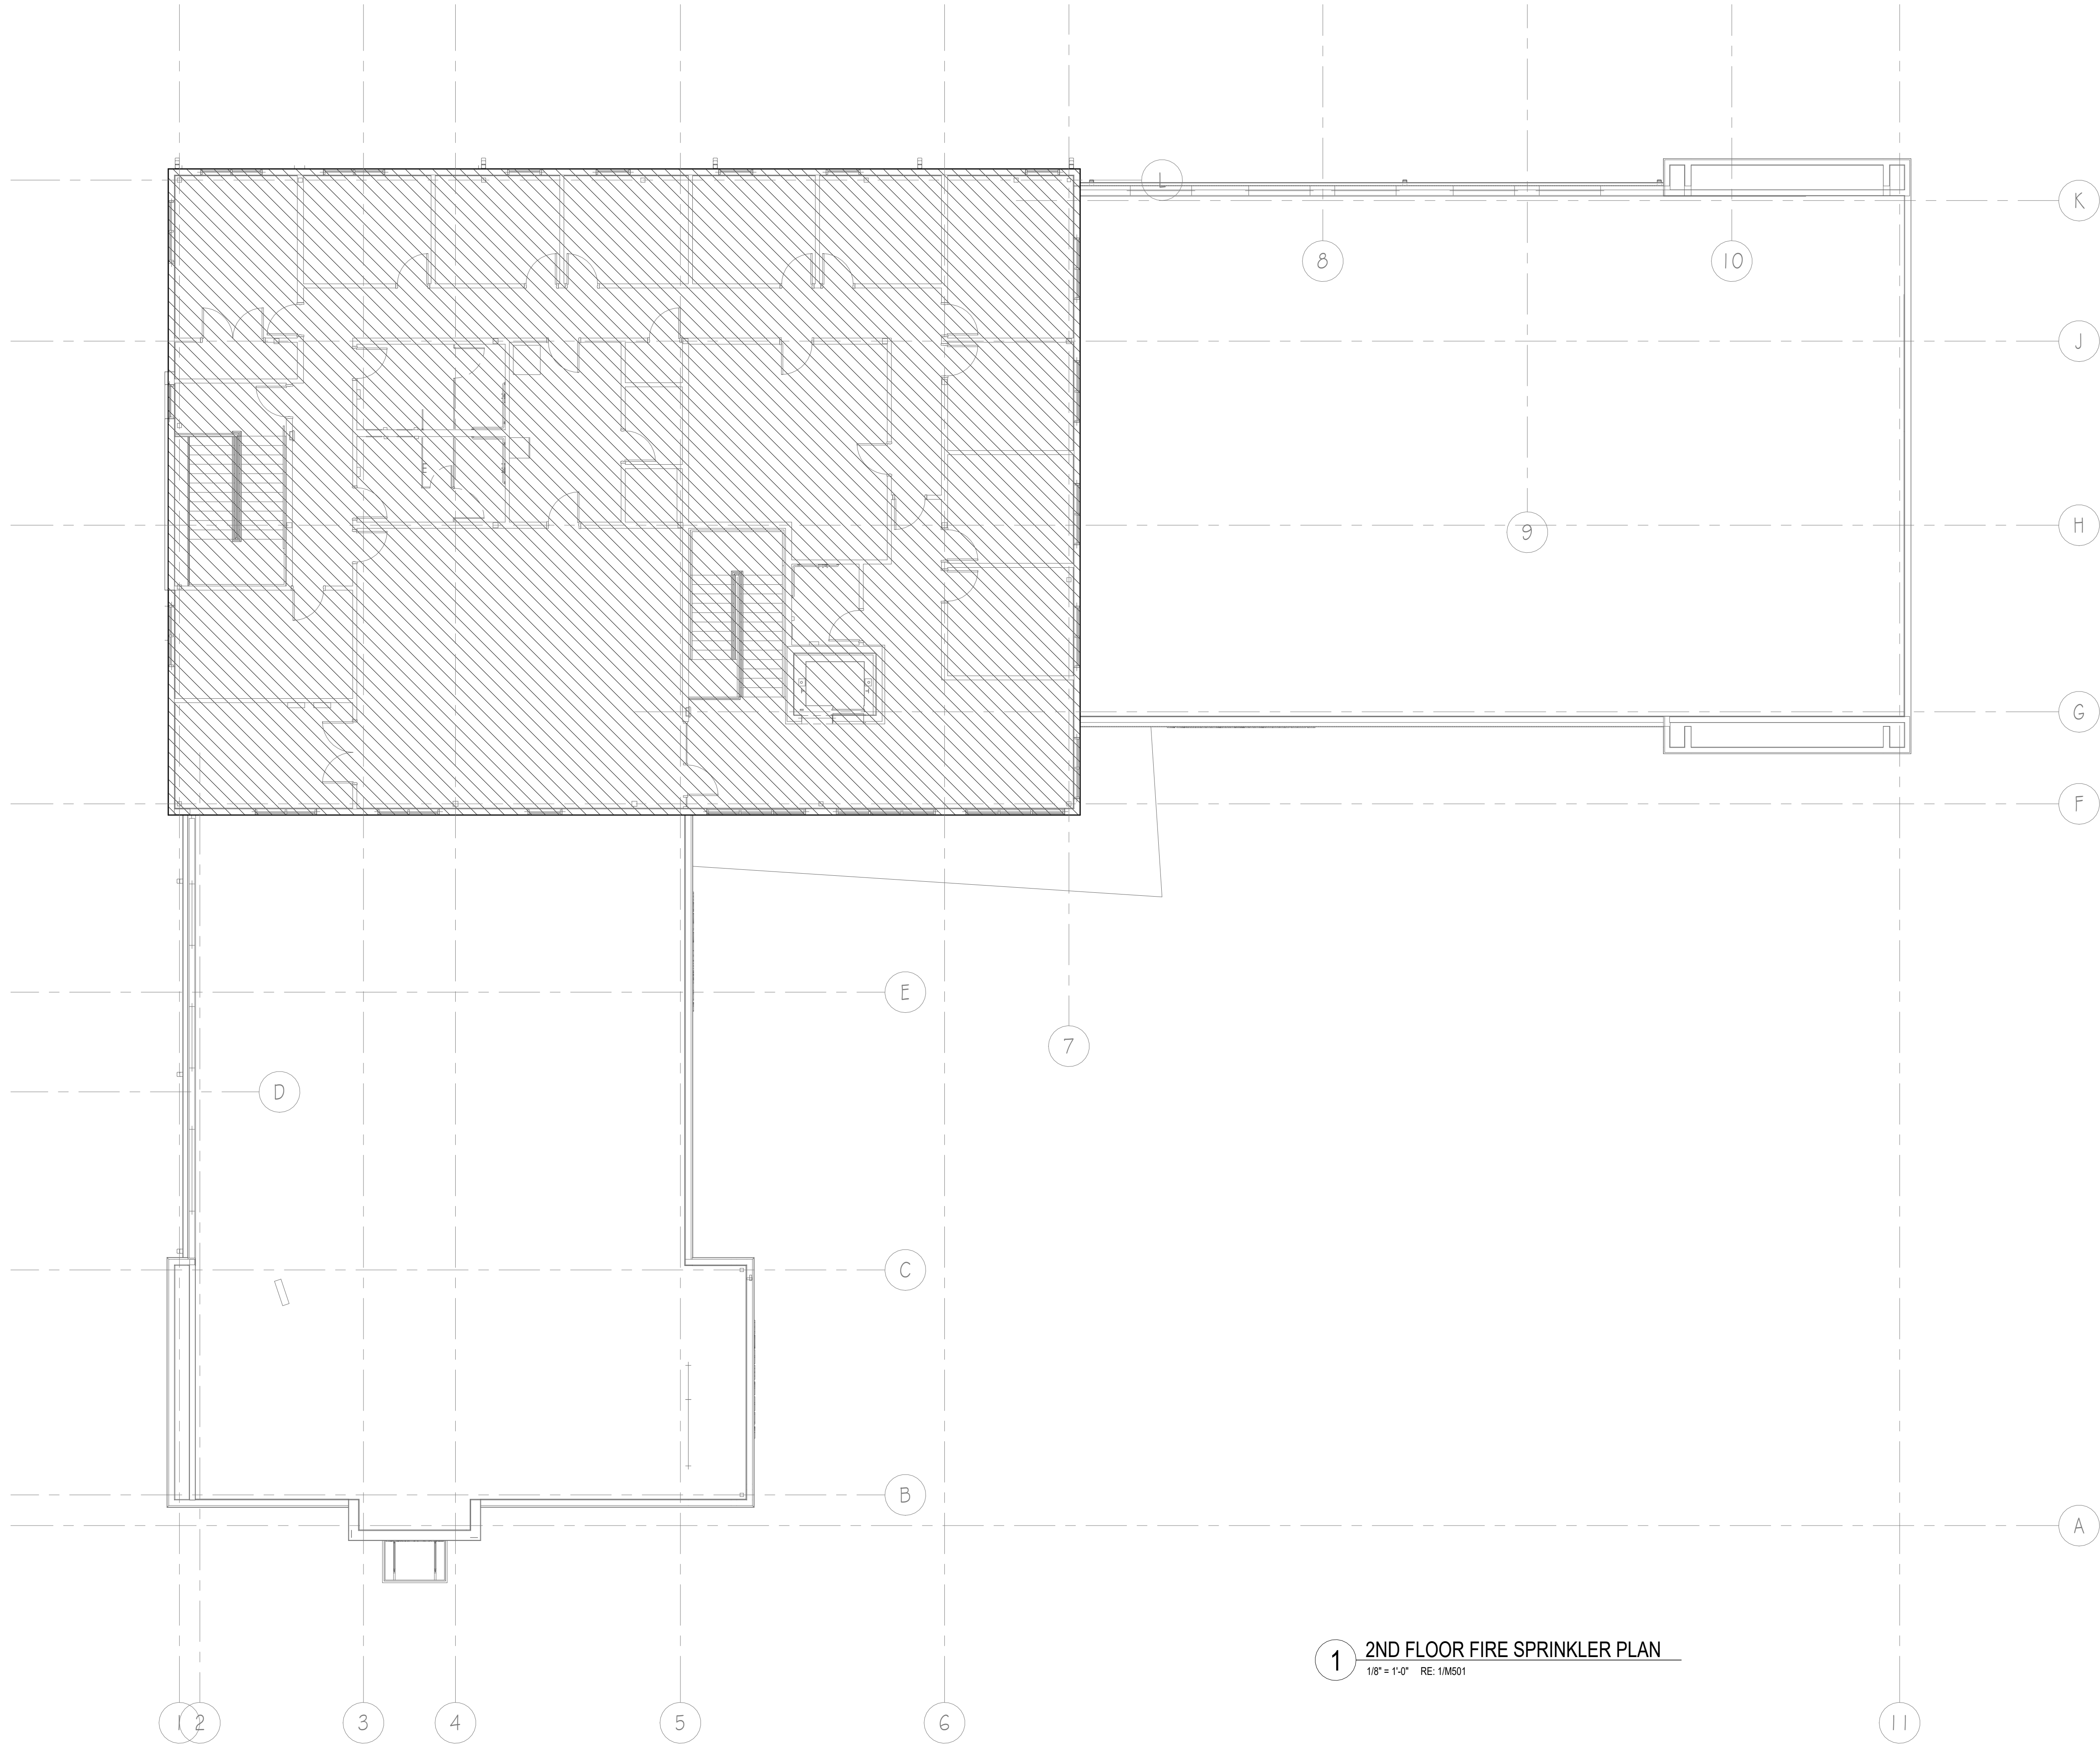

1 2ND FLOOR FIRE SPRINKLER PLAN
1/8" = 1'-0" RE: 1/M501

KEYED FIRE SPRINKLER NOTES

- 1 FIRE PROTECTION WATER SUPPLY INTO BUILDING. SEE CIVIL FOR CONTINUATION.
- 2 NFPA 13 FIRE PROTECTION RISER. EXTEND TEST PORT AND DRAIN OUTLETS TO EXTERIOR OF BUILDING. FINAL ROUTING, SIZE AND CONFIGURATION BY HYDRAULIC DESIGN BY FIRE SPRINKLER SUBCONTRACTOR. ALL PIPING TO BE LOCATED WITHIN BUILDING ENVELOPE AND NOT SUBJECT TO TEMPERATURES BELOW 40°F.
- 3 PROVIDE REMOTE FDC AND RUN SEPARATE PIPE TO SPRINKLER RISER. COORDINATE FINAL LOCATION OF FDC WITH AHJ PRIOR TO CONSTRUCTION. RE - CIVIL FOR CONTINUATION.



KEY ARCHITECTURE INC.
P.O. BOX 748 FAYETTEVILLE, ARKANSAS 72702
PH: 479.444.6066 FAX: 479.444.1445

FOR PERMIT & CONSTRUCTION

Revision Schedule	
Rev. #	Date
Description	

NEW Arcare MEDICAL OFFICE BUILDING 2709 Massard Rd FT. SMITH, AR 72903	Arcare 117 S. 2ND ST. AUGUSTA, AR 72006
--	---

DATE 06-15-2026	DRAWN BY CO
PROJECT # 2517	CHECKED BY JT
SHEET F102 2ND FLOOR FIRE SPRINKLER PLAN	

These Drawings and Specifications are the exclusive property of Key Architecture Inc. and are protected by Copyright. Use or reproduction is prohibited without written consent.

310 W. MAIN ST. SUITE C
RUSSELLVILLE, AR 72801
PHONE (479) 595-8777
WWW.TERRELLENG.COM
AR FIRM # 3434