
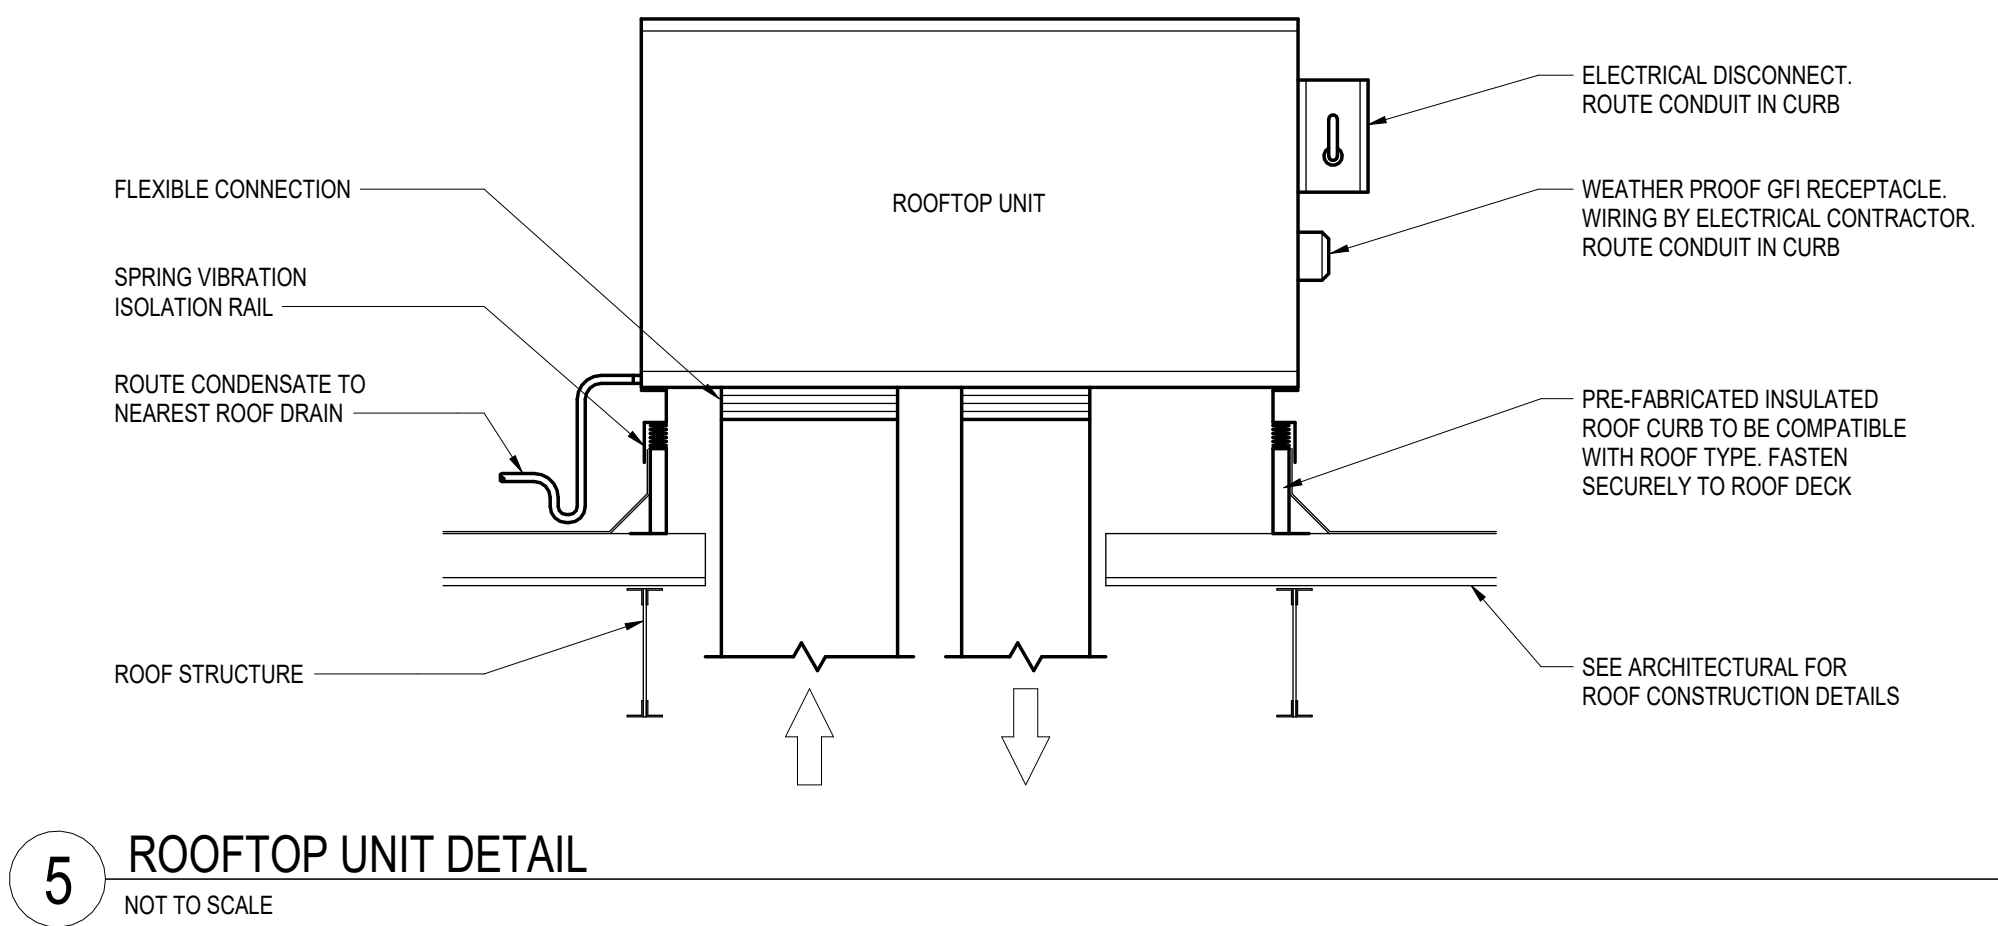
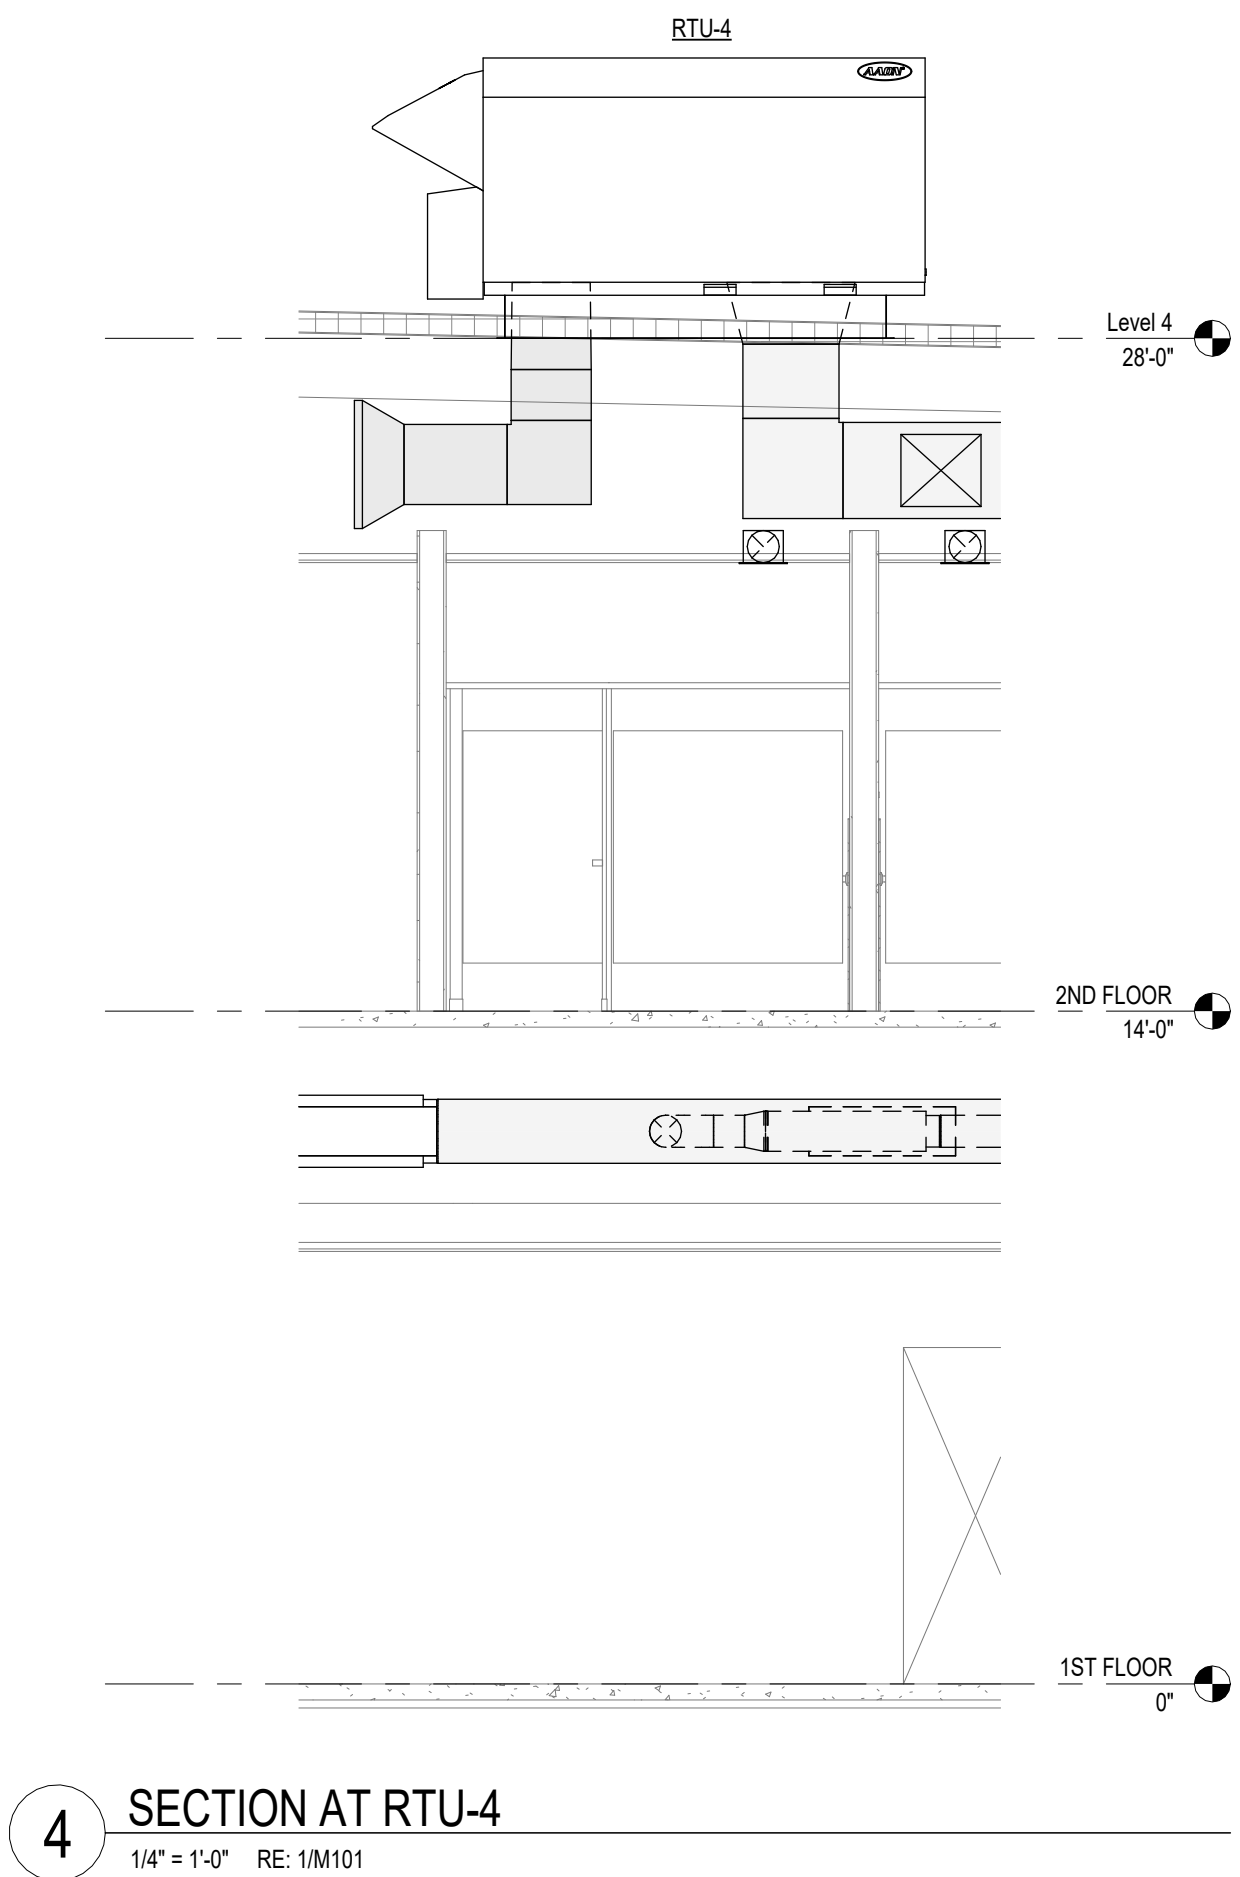
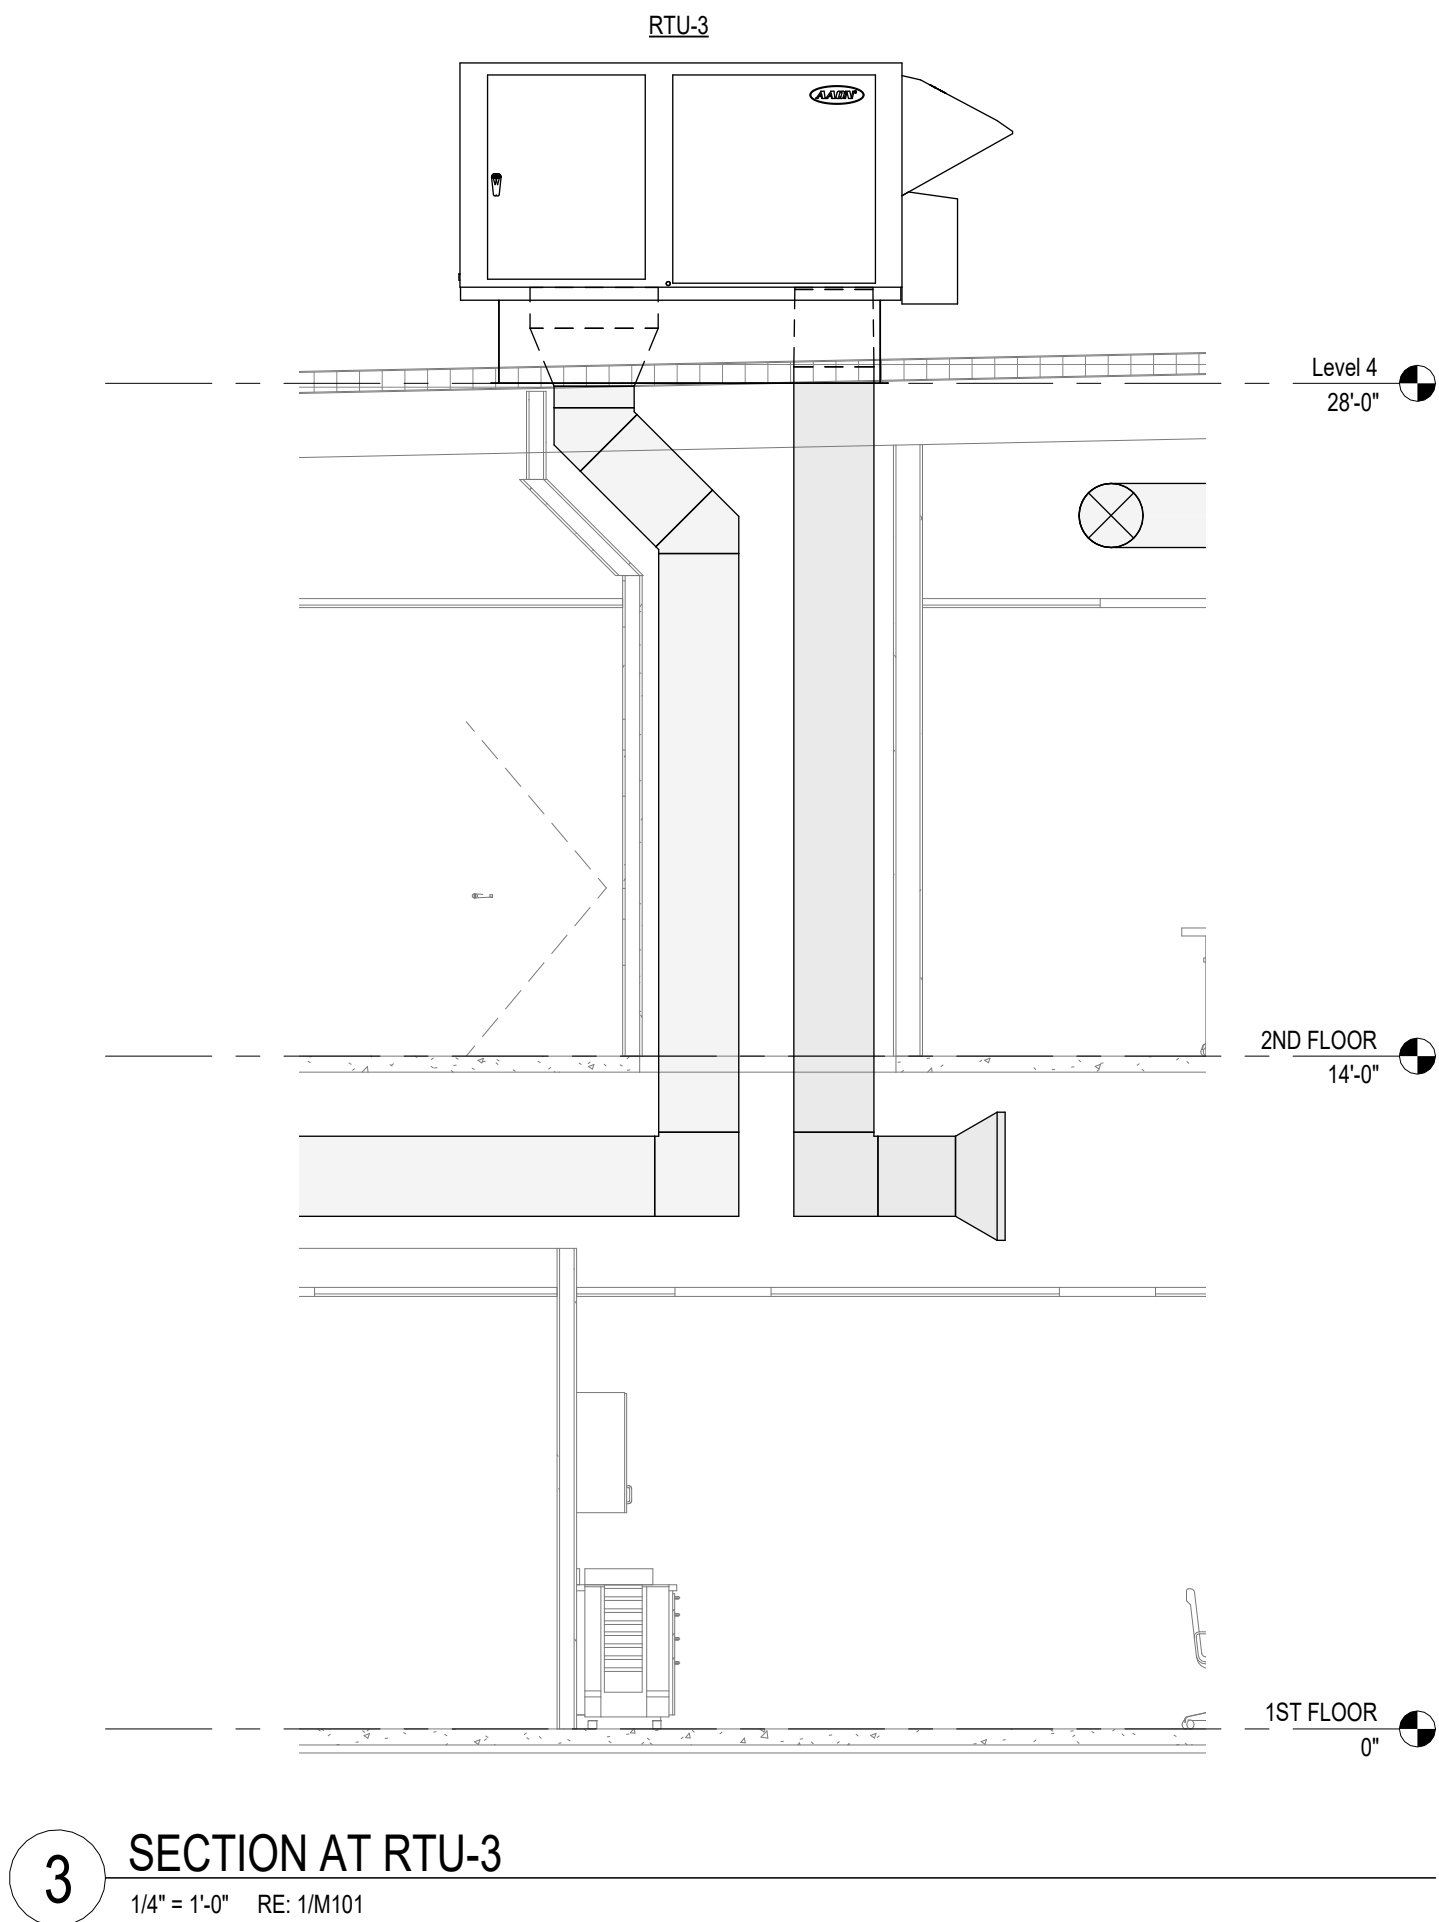
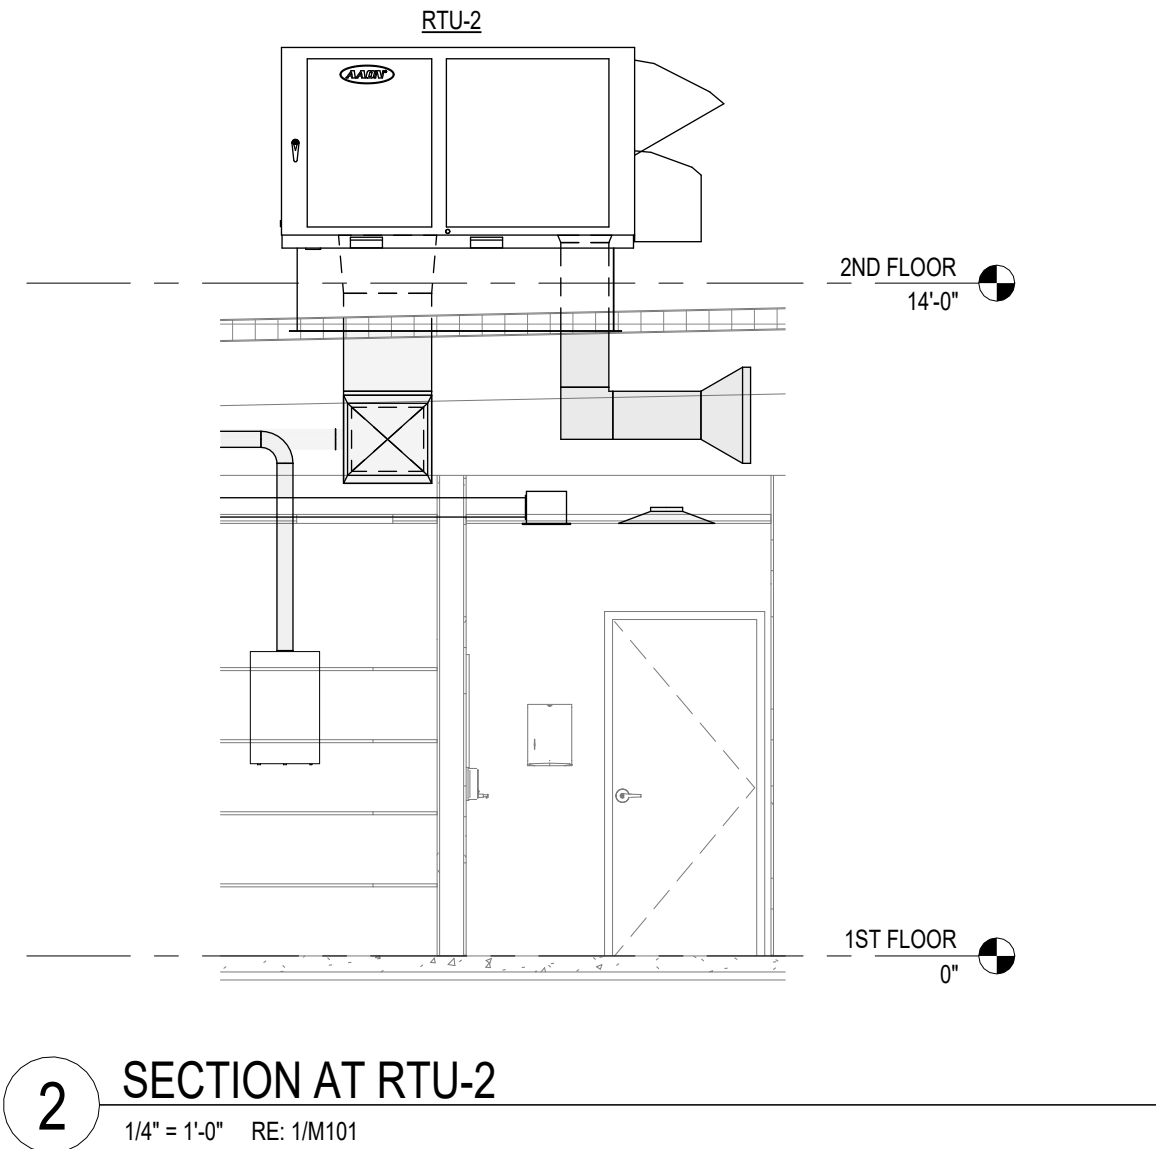


As indicated 6/16/2026 10:35:59 AM Autodesk Docs//26-031 - ARCare Clinic- For Smith, AR/ARCC MEP.rvt

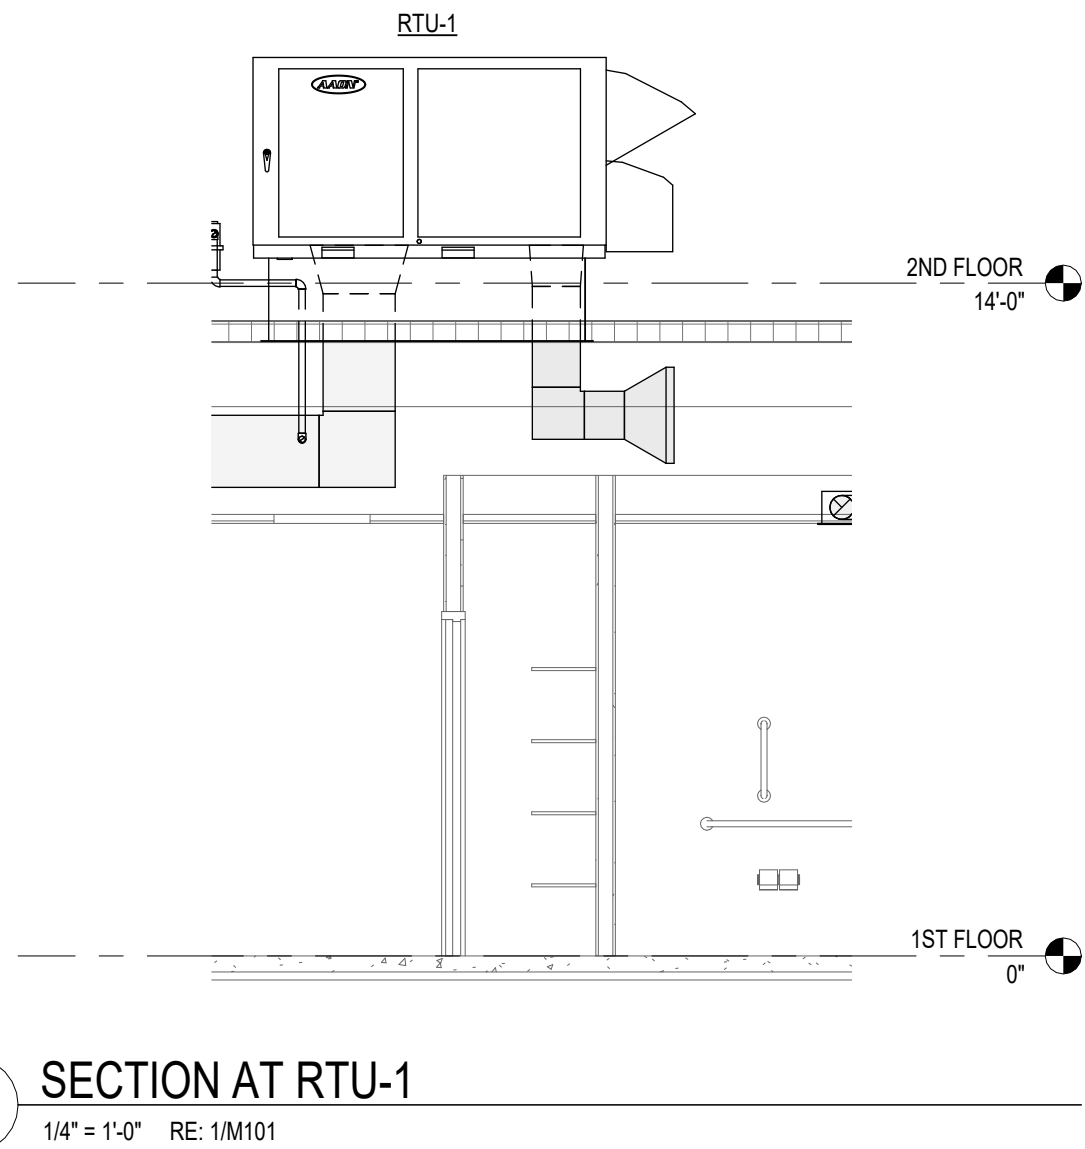

TERRELL
ENGINEERING CONSULTANTS

310 W. MAIN ST. SUITE C
RUSSELLVILLE, AR 72801
PHONE (479) 595-8177
WWW.TERRELLENG.COM

AR FIRM # 3434



KEY ARCHITECTURE INC.

P.O. BOX 748 FAYETTEVILLE, ARKANSAS 72702
PH: 479.444.6066 FAX: 479.444.1445

FOR PERMIT &
CONSTRUCTION

Revision Schedule	
Rev. #	Description

NEW Arcare MEDICAL OFFICE BUILDING
2709 Massard Rd
FT. SMITH, AR 72903

Arcare
117 S. 2ND ST.
AUGUSTA, AR 72006

DATE 06-15-2026	DRAWN BY CO
PROJECT # 2517	CHECKED BY JT

SHEET
M501
HVAC DETAILS

These Drawings and Specifications are the exclusive property of Key Architecture Inc. and are protected by Copyright. Use or reproduction is prohibited without written consent.