




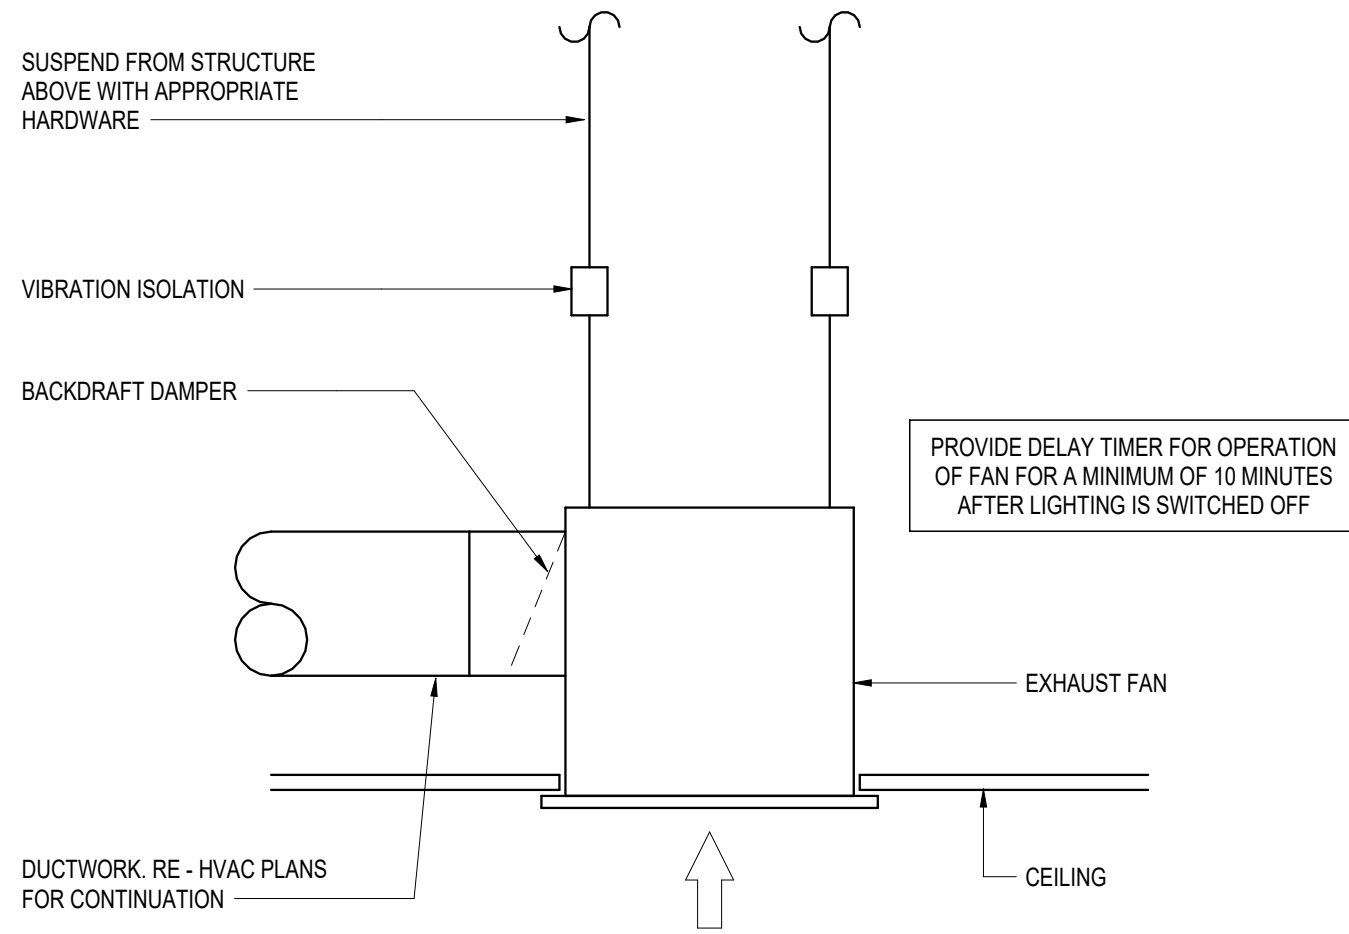


**1 CABINET EXHAUST FAN DETAIL**  
NOT TO SCALE

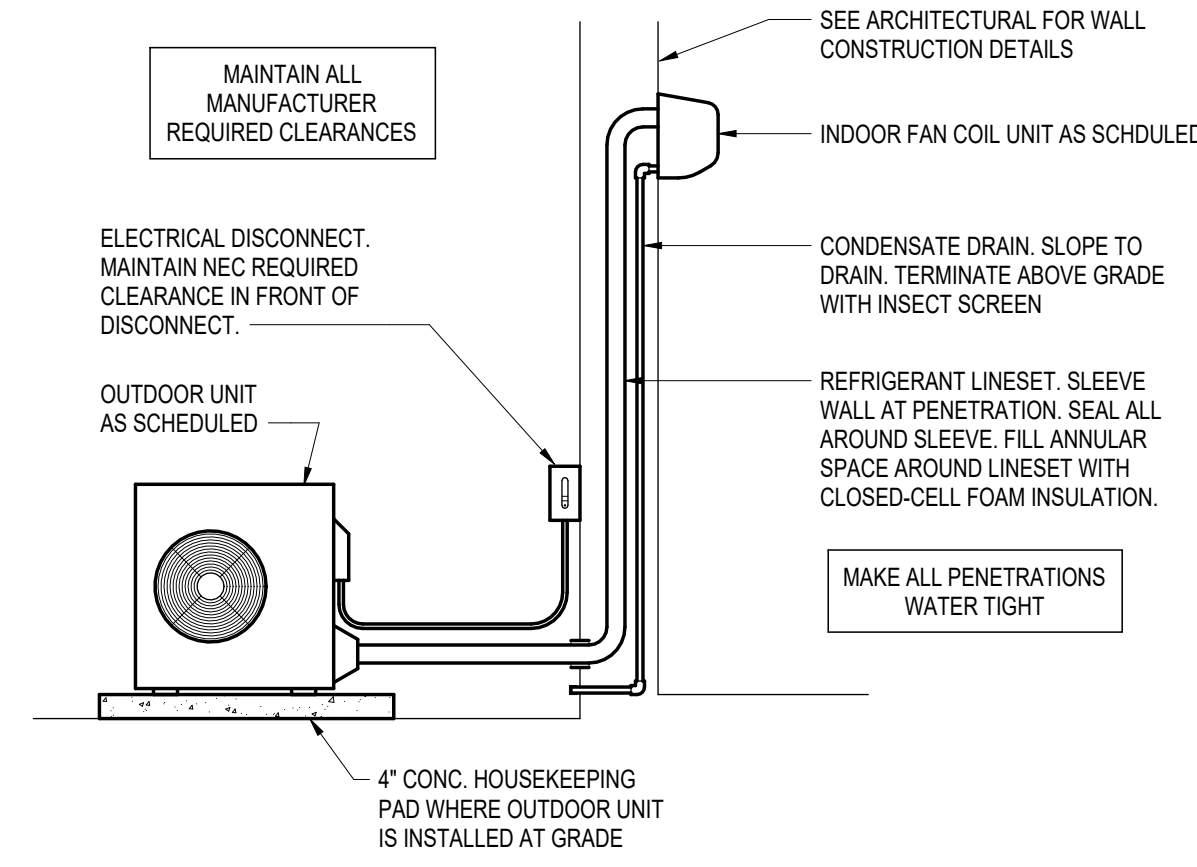


**2 DUCTLESS SPLIT SYSTEM SCHEMATIC**  
NOT TO SCALE

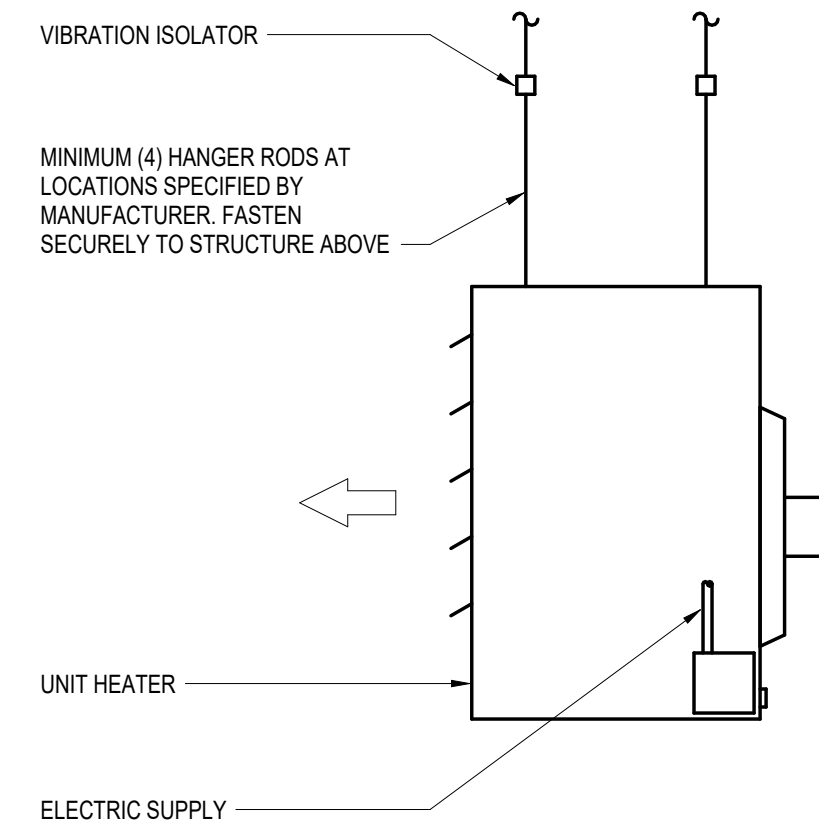


**3 UNIT HEATER DETAIL**  
NOT TO SCALE

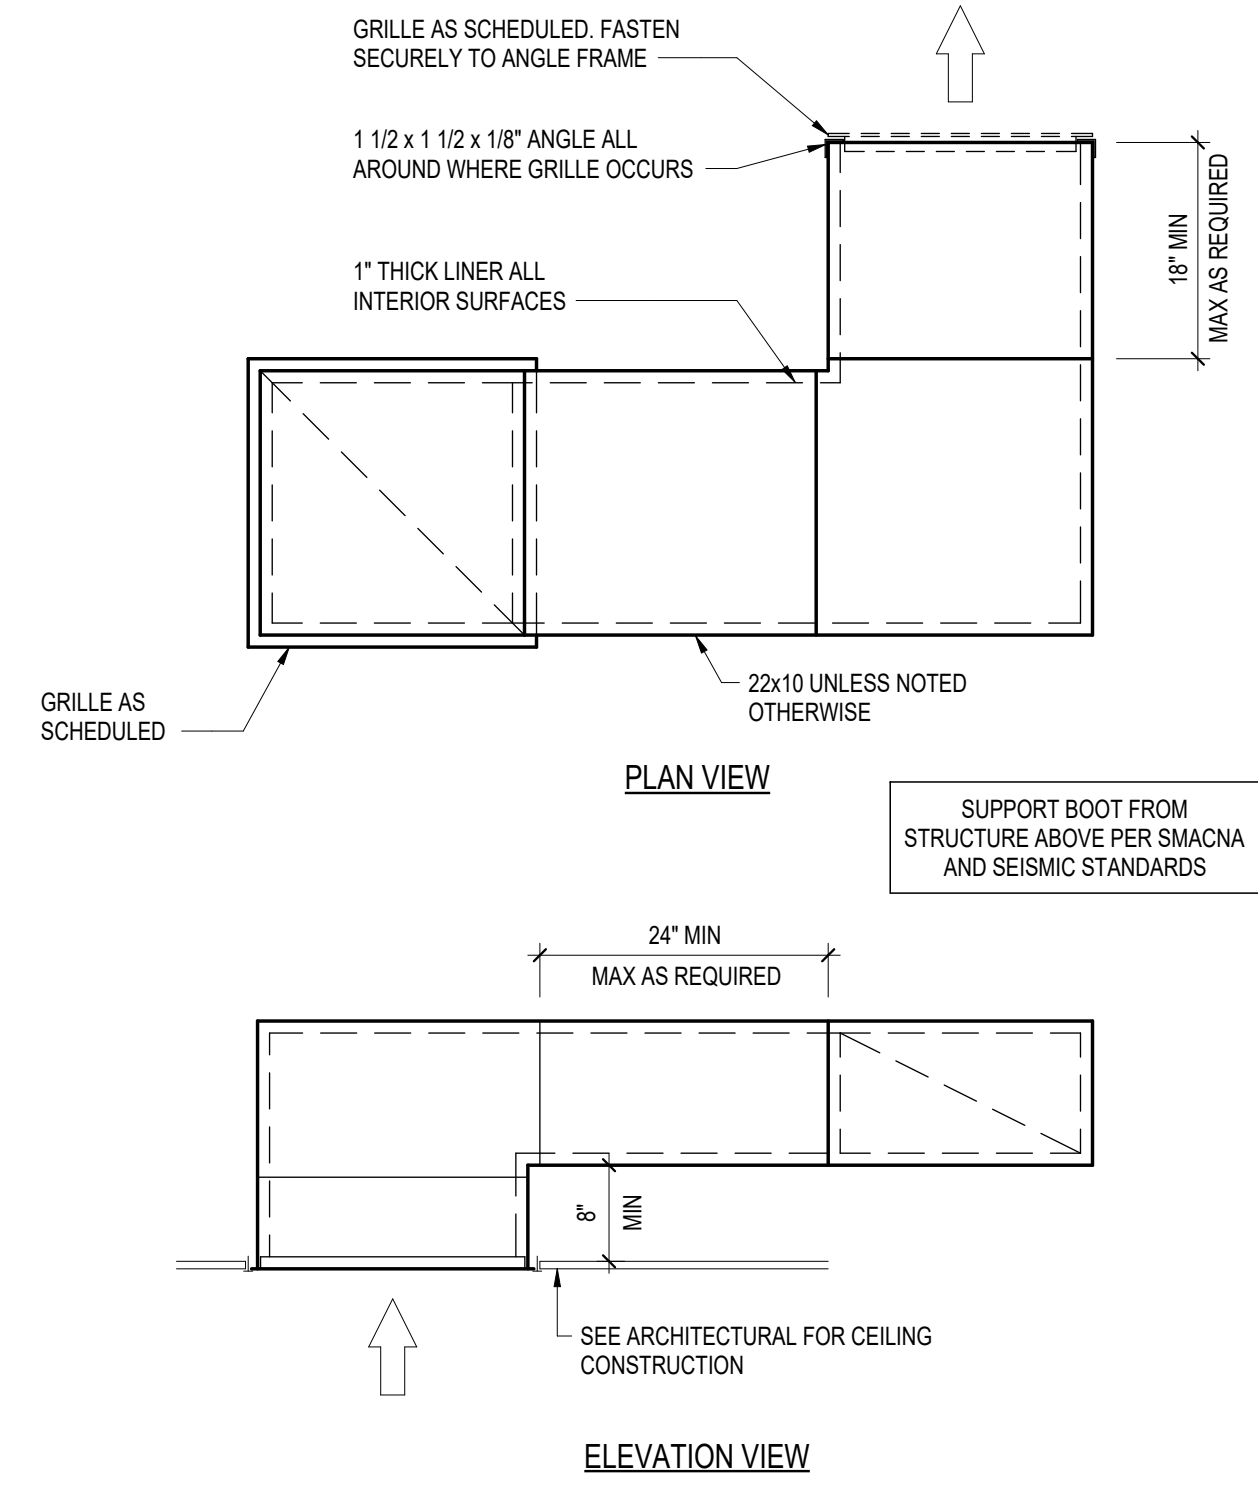

**4 RETURN ZEE DETAIL**  
NOT TO SCALE

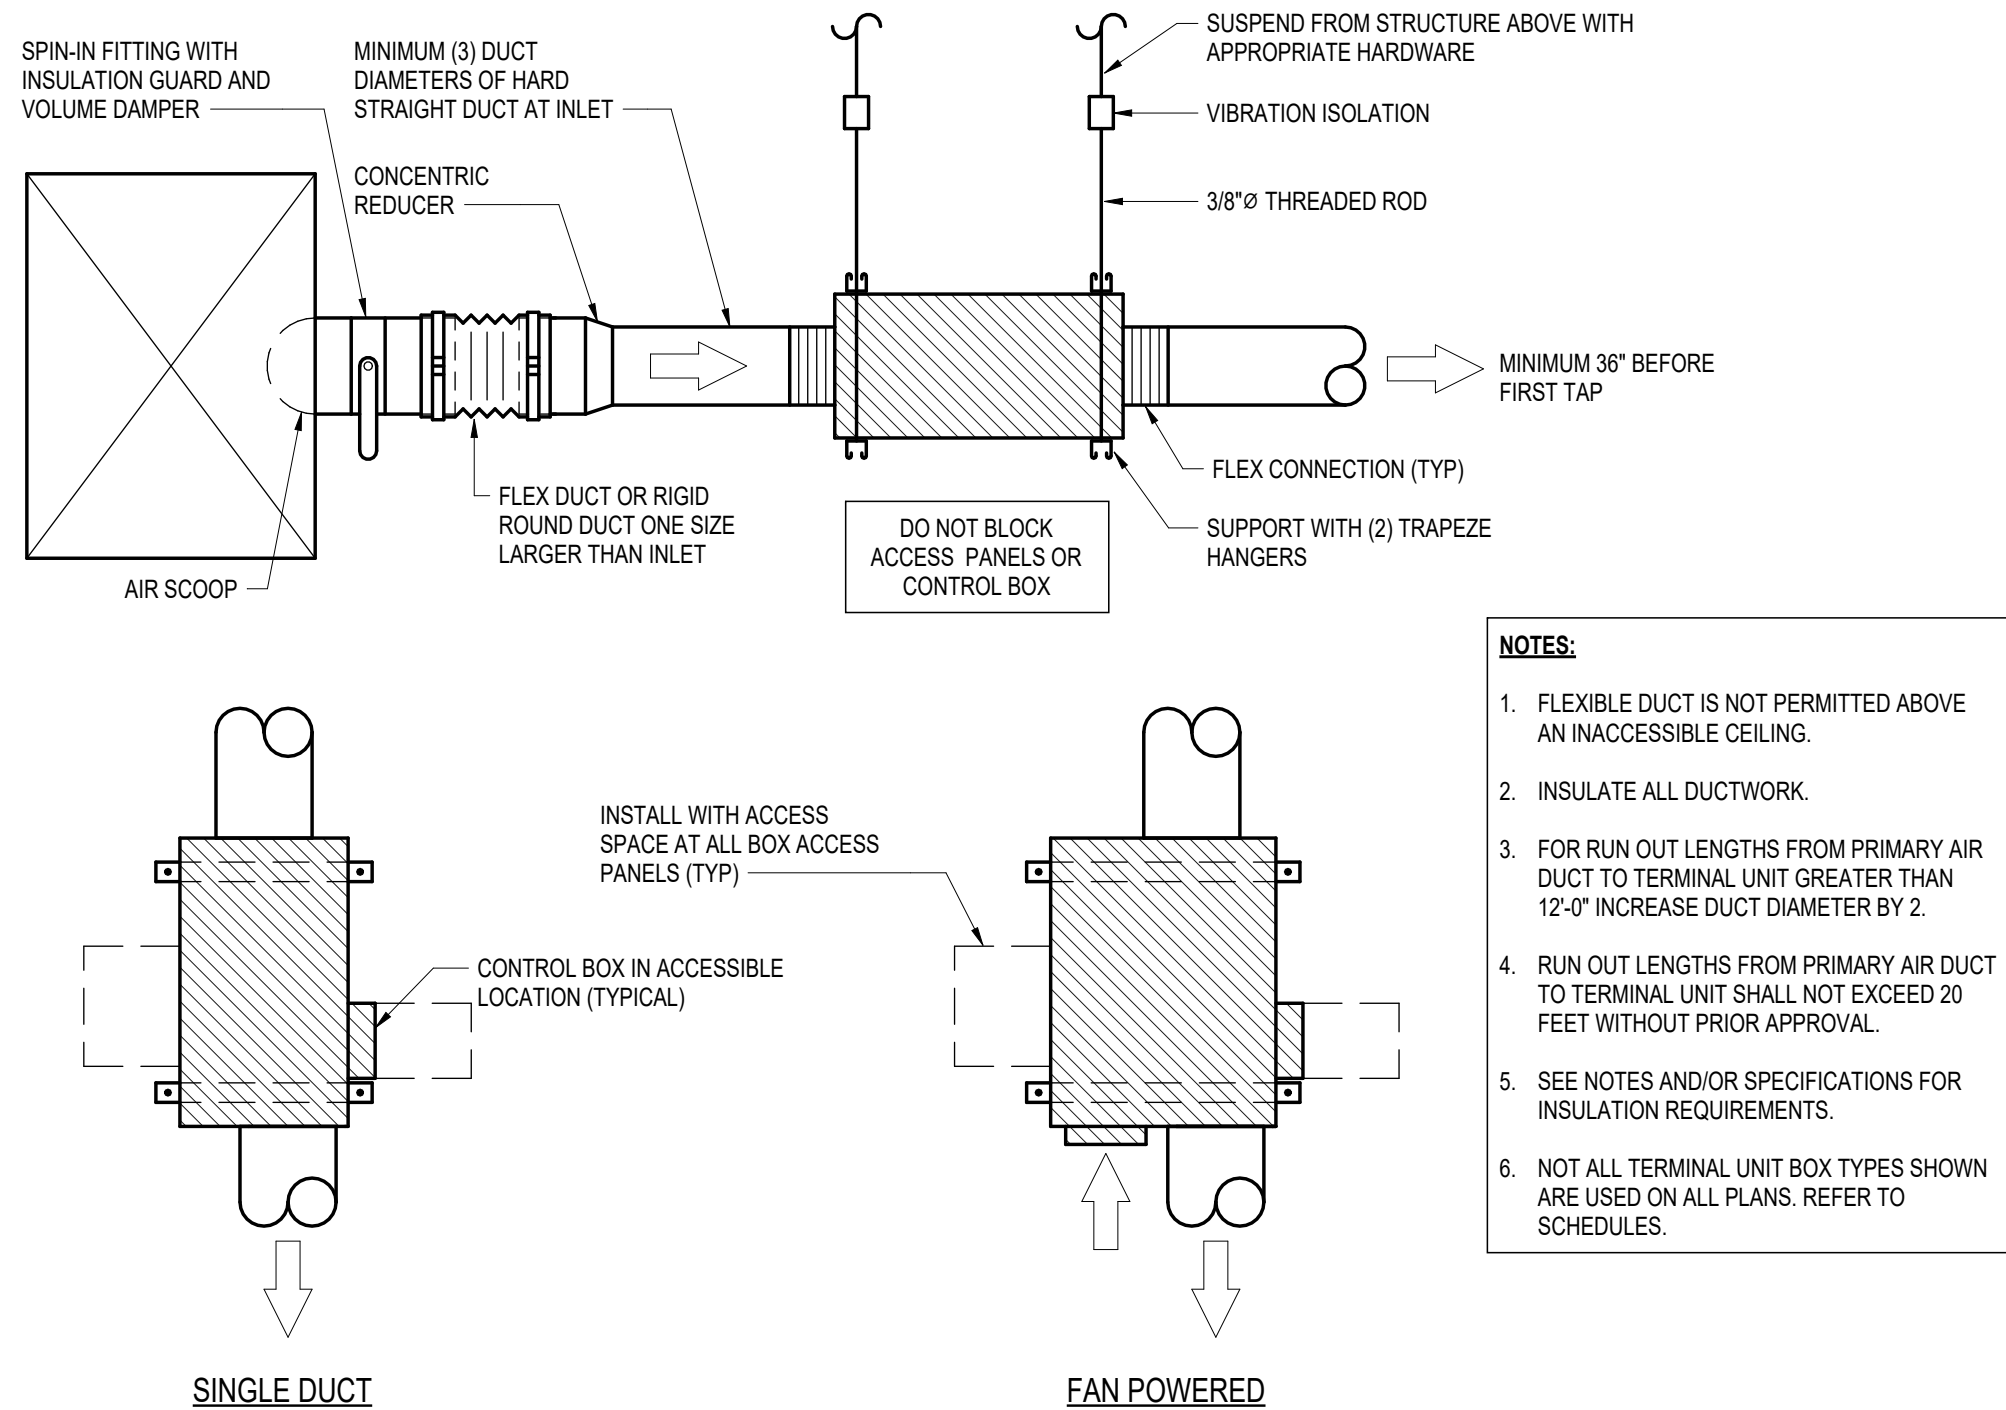

**5 VARIABLE AIR VOLUME TERMINAL UNIT**  
NOT TO SCALE

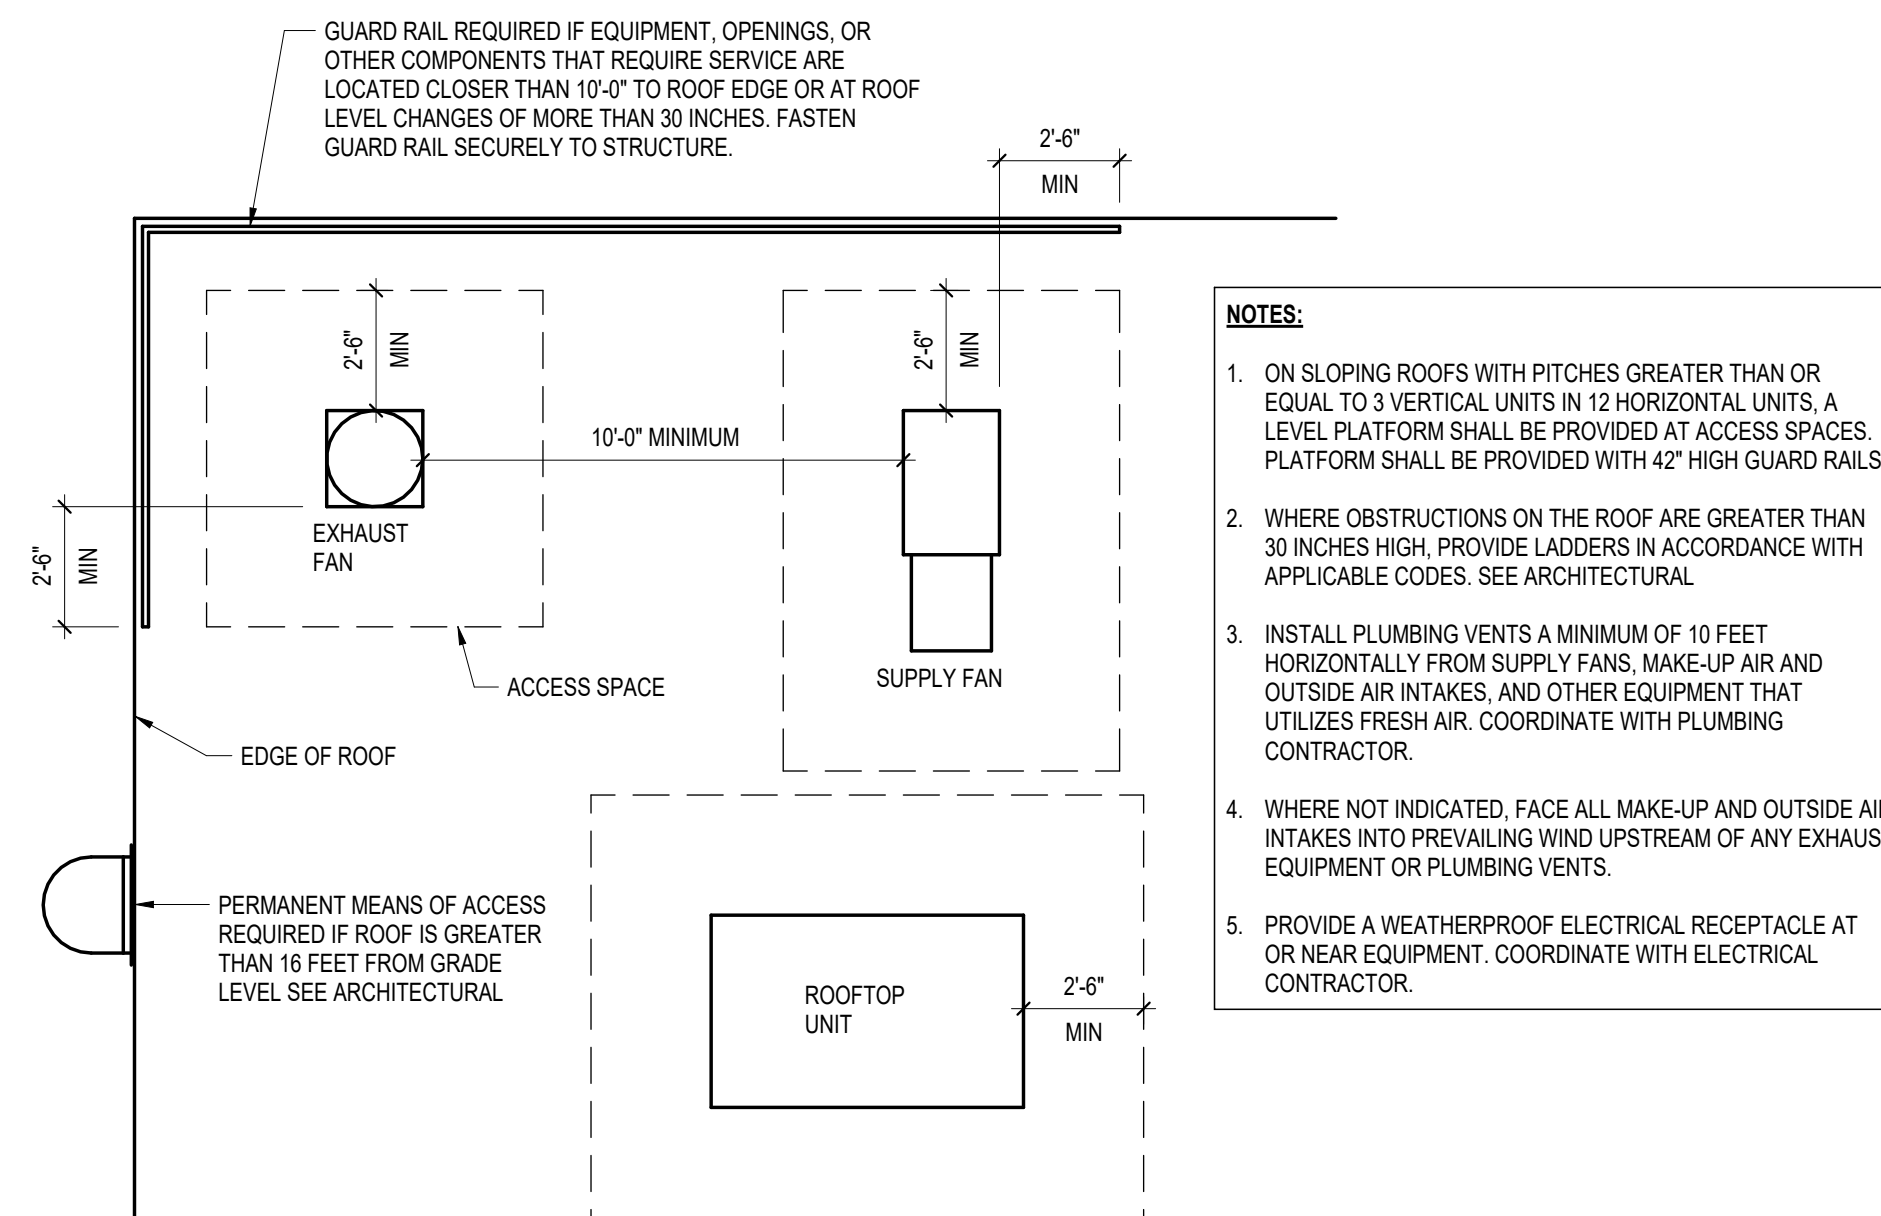

**6 ROOFTOP EQUIPMENT CLEARANCES**  
NOT TO SCALE

| Revision    | Schedule |
|-------------|----------|
| Rev. #      | Date     |
| Description |          |

|                                                                              |                                               |
|------------------------------------------------------------------------------|-----------------------------------------------|
| NEW Arcare MEDICAL OFFICE BUILDING<br>2709 Massard Rd<br>FT. SMITH, AR 72903 | Arcare<br>117 S. 2ND ST.<br>AUGUSTA, AR 72006 |
|------------------------------------------------------------------------------|-----------------------------------------------|

|                    |                  |
|--------------------|------------------|
| DATE<br>06-15-2026 | DRAWN BY<br>CO   |
| PROJECT #<br>2517  | CHECKED BY<br>JT |

|                                      |
|--------------------------------------|
| SHEET<br><b>M503</b><br>HVAC DETAILS |
|--------------------------------------|