




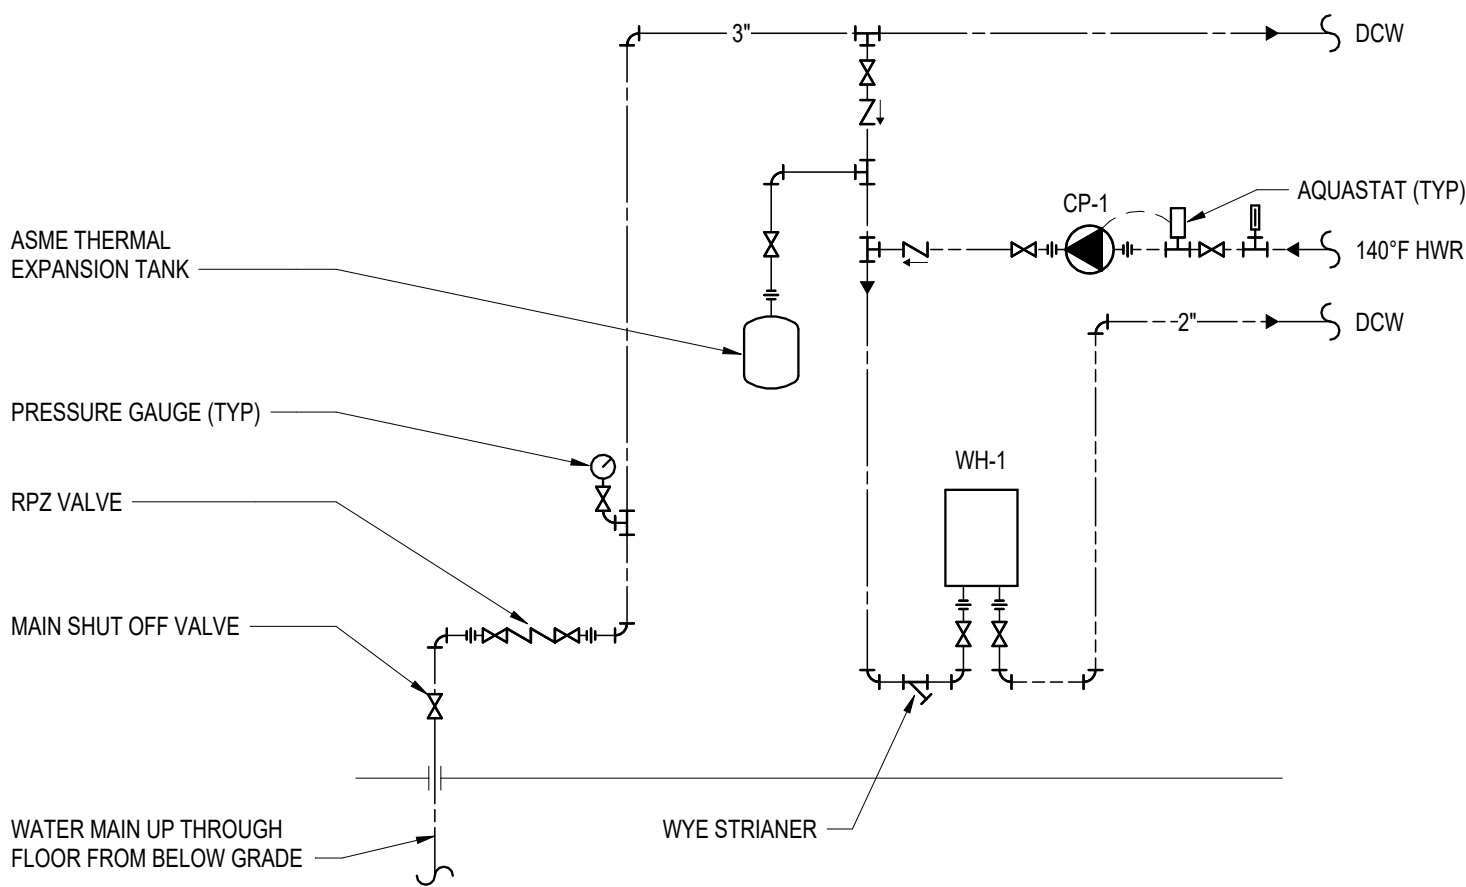


1 DOMESTIC WATER SERVICE SCHEMATIC
NOT TO SCALE

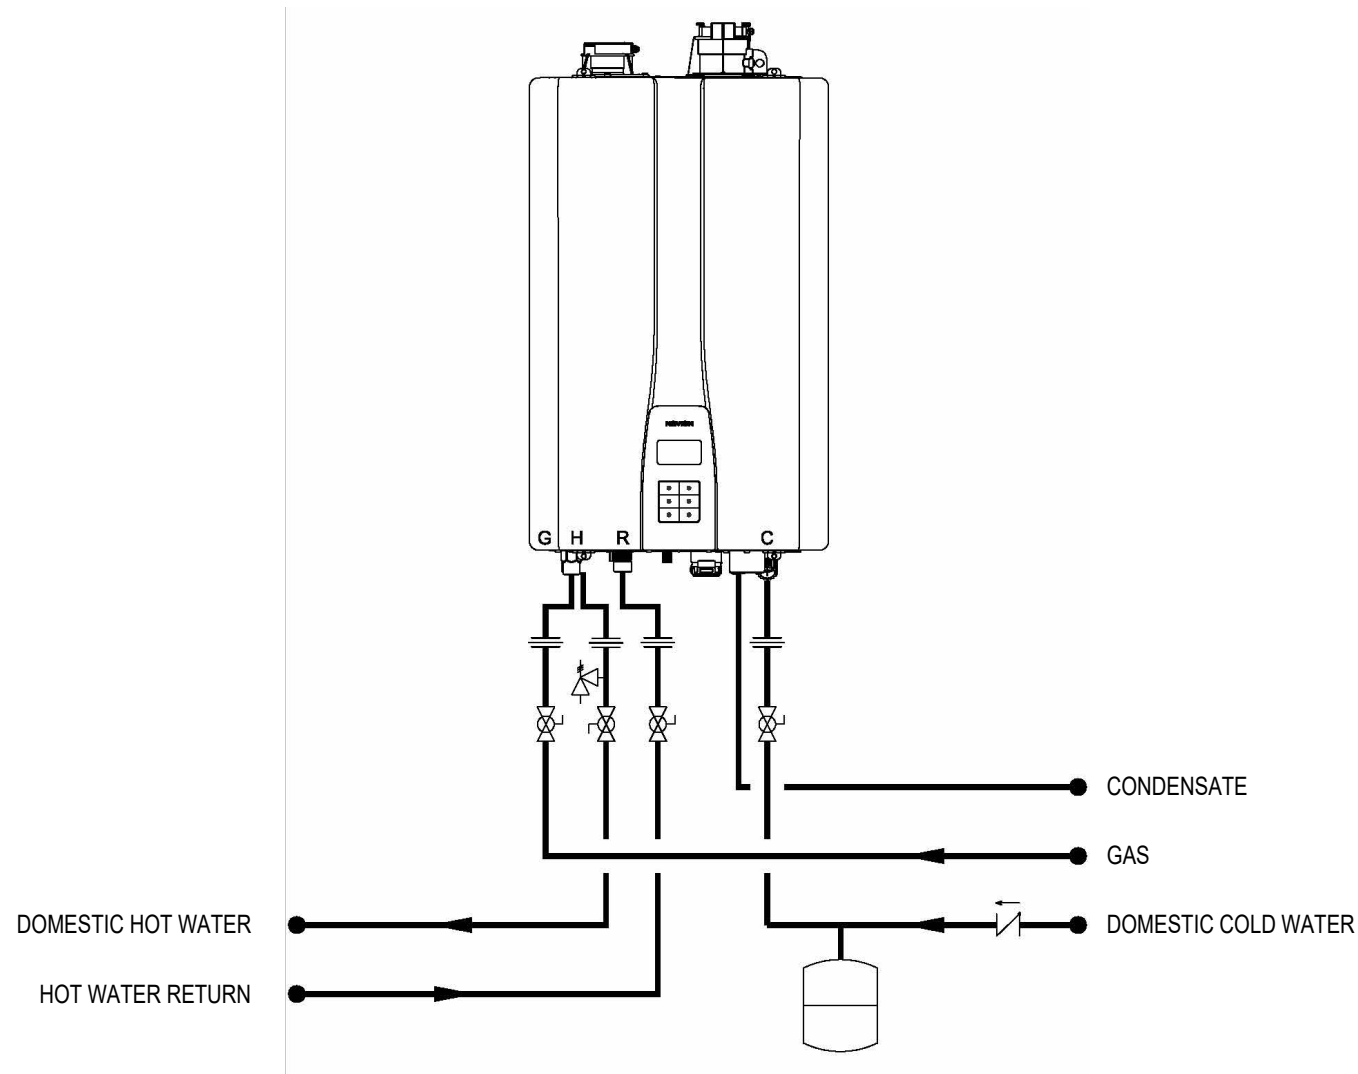


2 WATER HEATER DETAIL
NOT TO SCALE

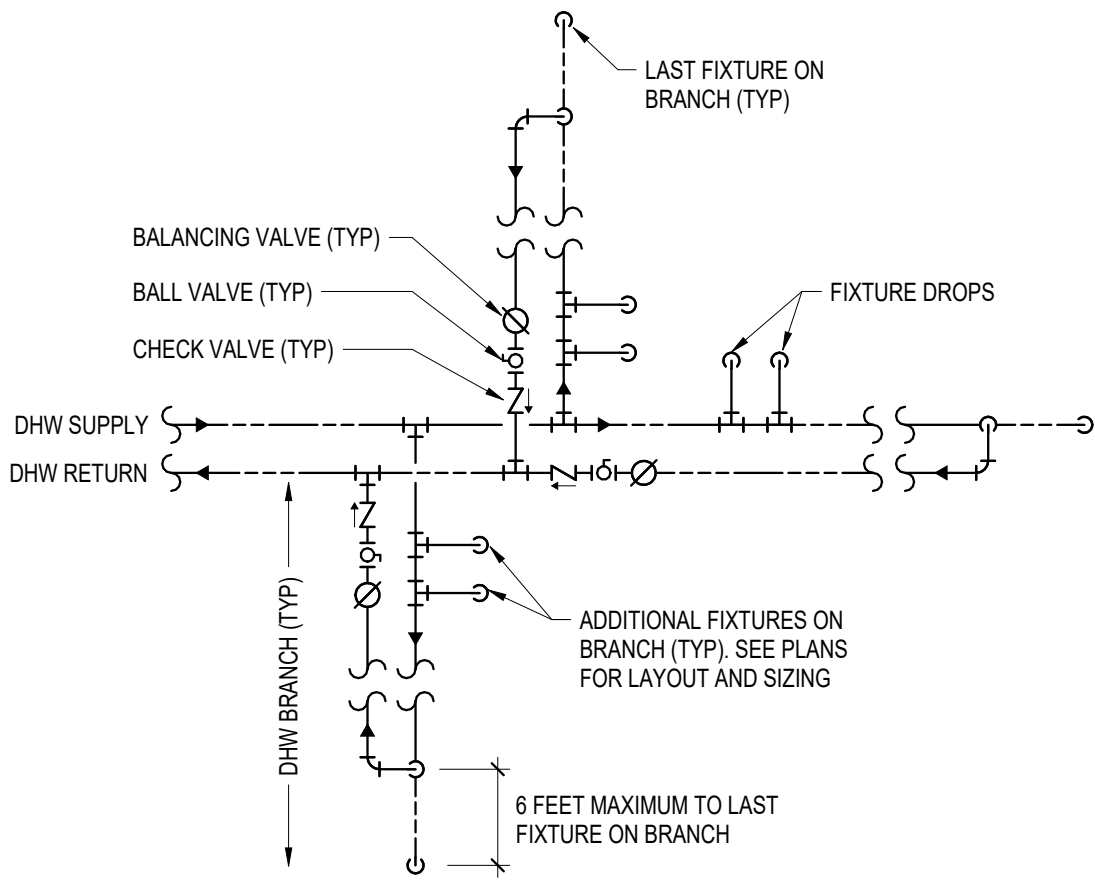


3 HOT WATER BRANCH RECIRCULATION DETAIL
NOT TO SCALE

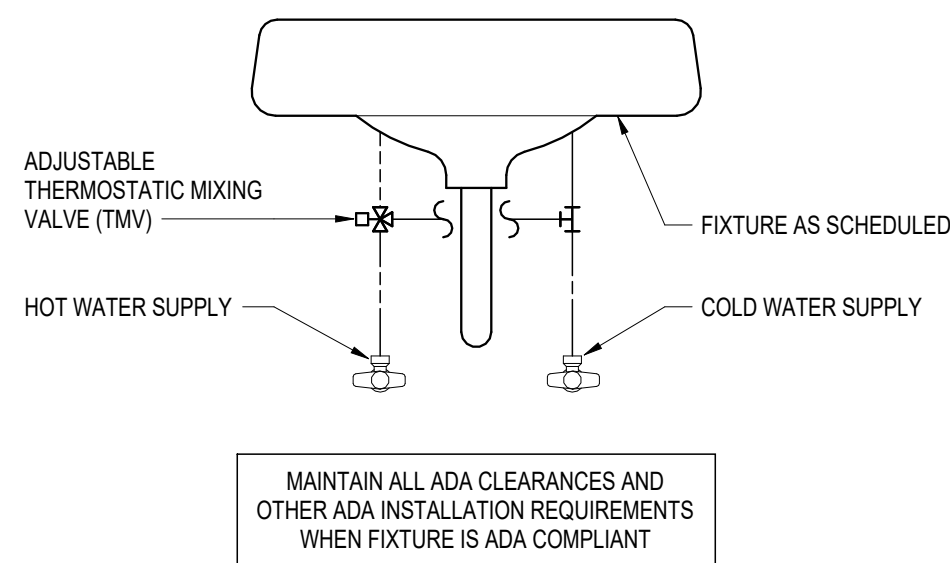


4 TMV DETAIL AT LAVATORY/SINK
NOT TO SCALE

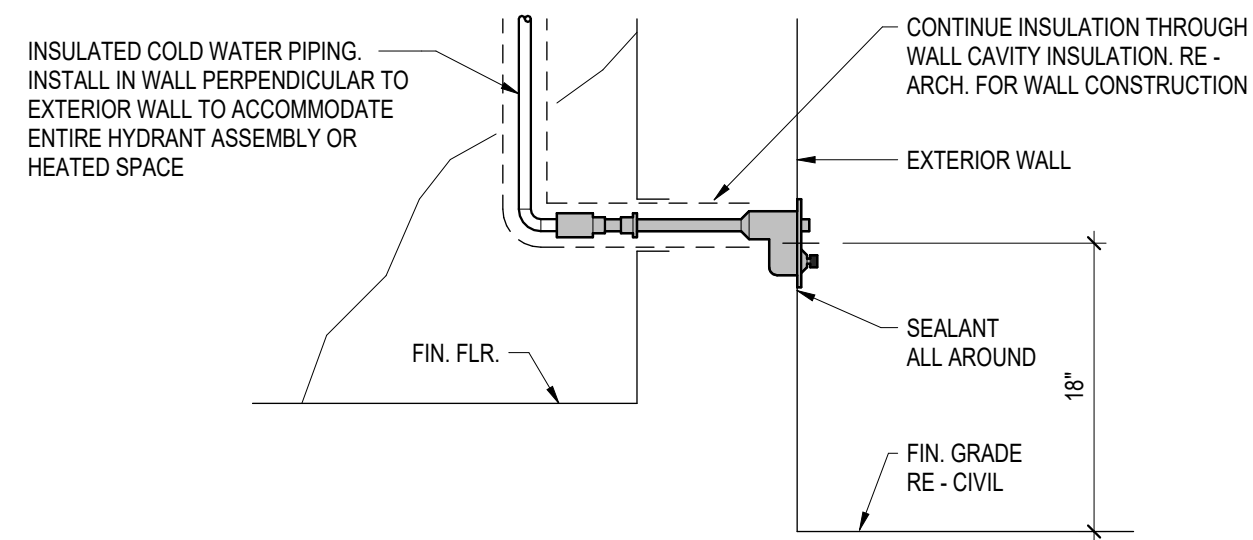

5 WALL HYDRANT DETAIL
NOT TO SCALE

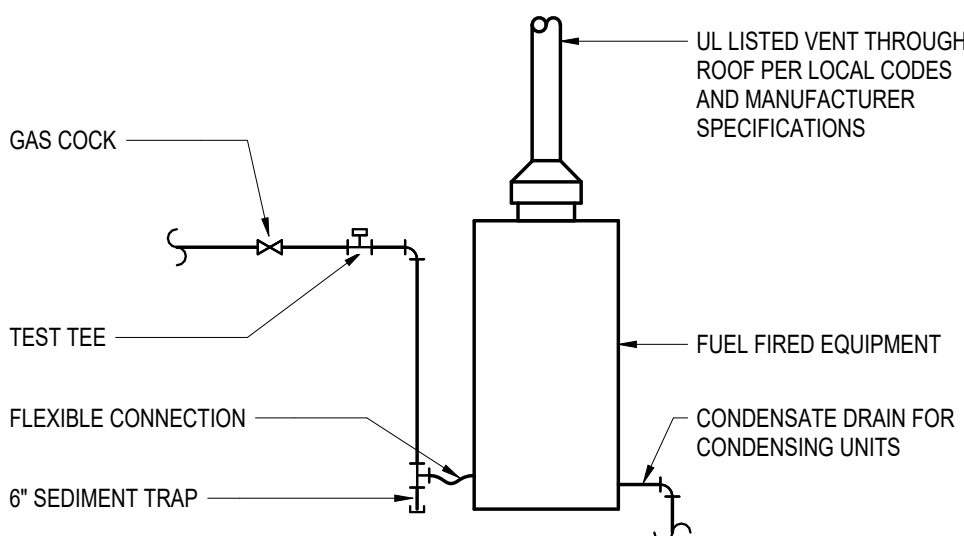

6 GAS FIRED EQUIPMENT DETAIL
NOT TO SCALE

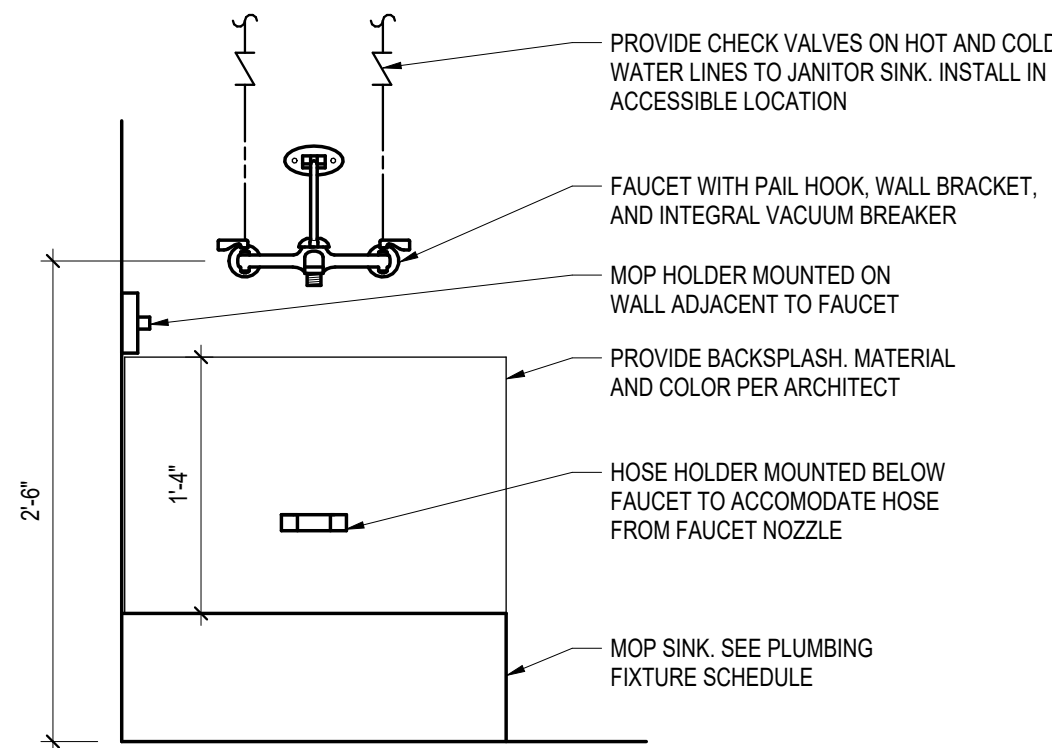

7 FLOOR MOUNTED SERVICE SINK DETAIL
NOT TO SCALE

TERRELL
ENGINEERING CONSULTANTS

310 W. MAIN ST. SUITE C
RUSSELLVILLE, AR 72801
PHONE (479) 595-8177
WWW.TERRELLENG.COM

AR FIRM # 3434



KEY ARCHITECTURE INC.
P.O. BOX 748 FAYETTEVILLE, ARKANSAS 72702
PH: 479.444.6066 FAX: 479.444.1445

FOR PERMIT & CONSTRUCTION

Revision Schedule	Description	
	Rev. #	Date

NEW Arcare Medical Office Building
2709 Massard Rd
FT. SMITH, AR 72903
Arcare
117 S. 2ND ST.
AUGUSTA, AR 72006

DATE 06-15-2026	DRAWN BY CO
PROJECT # 2517	CHECKED BY JT

SHEET
P502
PLUMBING DETAILS

These Drawings and Specifications are the exclusive property of Key Architecture Inc. and are protected by Copyright. Use or reproduction is prohibited without written consent.