


VETERANS HEALTH ADMINISTRATION

RENOVATE SPACE FOR LOGISTICS (B-1)

FAYETTEVILLE VA MEDICAL CENTER

1100 NORTH COLLEGE AVENUE - FAYETTEVILLE, AR 72703 | PROJECT NUMBER - 564-24-104

LOCATION MAP

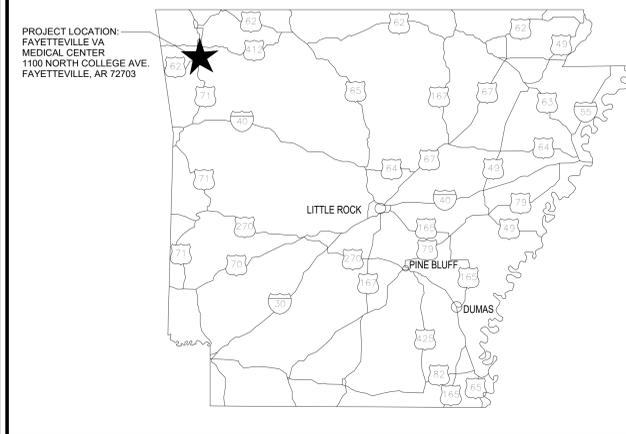

VA CAMPUS MAP



INDEX OF DRAWINGS

GENERAL	COVER SHEET, DRAWING INDEX, AND PROJECT INFORMATION
GI001-A	EQUIPMENT MOUNTING LEGEND
GI002-A	ACCESSIBILITY LEGEND
GI003-A	FIRST FLOOR - LIFE SAFETY PLAN AND CODE SUMMARY
GI010-A	PARTITION TYPES AND STANDARD DETAILS
GI501-A	UL DETAILS
GI502-A	UL DETAILS
GENERAL	INTERIOR DETAILS
GC101-A	BASEMENT FLOOR - ICRA PLAN
GC102-A	FIRST FLOOR - ICRA PLAN
HAZARDOUS	FIRST FLOOR - HAZARDOUS ABATEMENT PLAN
HA101-A	FIRST FLOOR - HAZARDOUS ABATEMENT PLAN
STRUCTURAL	STRUCTURAL GENERAL NOTES
S001-A	FIRST FLOOR FRAMING PLAN - STERILE AREA
S102-A	TYPICAL CONCRETE DETAILS
S301-A	TYPICAL CONCRETE DETAILS
ARCHITECTURAL	ARCHITECTURAL ABBREVIATIONS
A001-A	ARCHITECTURAL NOTES AND LEGENDS
A002-A	BASEMENT FLOOR - DEMOLITION PLAN
AD101-A	FIRST FLOOR - DEMOLITION PLAN
AD102-A	FIRST FLOOR - DEMOLITION PLAN
AE101-A	BASEMENT FLOOR - CONSTRUCTION PLAN
AE102-A	FIRST FLOOR - CONSTRUCTION PLAN
AE103-A	ROOF PLAN
AE111-A	FIRST FLOOR - REFLECTED CEILING PLAN
AE201-A	INTERIOR ELEVATIONS - FIRST FLOOR
AE300-A	BUILDING SECTION - OVERALL 01
AE301-A	BUILDING SECTION - OVERALL 02
AE310-A	INTERIOR DETAILS
AE511-A	INTERIOR DETAILS
AE600-A	DOOR SCHEDULE AND DOOR DETAILS
INTERIORS	FIRST FLOOR FINISH PLAN
AF001-A	INTERIOR FINISH SCHEDULE AND SIGNAGE SCHEDULE
AF002-A	INTERIOR FINISH SCHEDULE AND SIGNAGE SCHEDULE
AF003-A	INTERIOR FINISH MATERIALS LEGENDS
AF004-A	WALL PROTECTION/SIGNAGE TYPES
EQUIPMENT	FIRST FLOOR - EQUIPMENT PLANS
QH001-A	EQUIPMENT SCHEDULES
QH601-A	EQUIPMENT SCHEDULES
FIRE ALARM	GENERAL NOTES AND SCHEDULES
FA001-A	FIRST FLOOR - FIRE ALARM PLAN
FIRE PROTECTION	GENERAL NOTES, SYMBOLS & LEGENDS
FX001-A	FIRST FLOOR FIRE PROTECTION DEMOLITION PLAN
FD101-A	FIRST FLOOR FIRE PROTECTION PLAN
FX101-A	FIRST FLOOR FIRE PROTECTION PLAN
FX501-A	FIRE PROTECTION DETAILS
PLUMBING	GENERAL NOTES, LEGENDS, & SCHEDULES
PL001-A	FIRST FLOOR PLUMBING DEMOLITION PLAN
PD101-A	FIRST FLOOR DOMESTIC WATER PLANS
PL101-A	FIRST FLOOR DOMESTIC WATER PLANS
PL201-A	FIRST FLOOR SANITARY SEWER PLAN
PL501-A	PLUMBING DETAILS
PL701-A	PLUMBING ISOMETRICS
MECHANICAL	GENERAL NOTES & LEGENDS
MH001-A	BASEMENT AND FIRST FLOOR MECHANICAL DEMOLITION PLAN
MD101-A	FIRST FLOOR AND LOADING DOCK ROOF DUCTWORK PLANS
MH101-A	FIRST FLOOR AND LOADING DOCK ROOF DUCTWORK PLANS
MH104-A	ROOF MECHANICAL PLAN
MP101-A	BASEMENT AND FIRST FLOOR MECHANICAL PIPING PLANS
MH501-A	DETAILS
MH502-A	DETAILS
MH503-A	DETAILS
MH601-A	SCHEDULES
M701-A	CONTROLS SCHEMATICS AND CONTROL POINTS
M702-A	CONTROLS SCHEMATICS AND CONTROL POINTS
ELECTRICAL	GENERAL NOTES AND SCHEDULES
EG001-A	FIRST FLOOR - DEMOLITION PLAN
EL101-A	FIRST FLOOR - LIGHTING PLAN
EP101-A	FIRST FLOOR - POWER PLAN
EP104-A	ROOF PLAN - POWER
EY101-A	FIRST FLOOR - SYSTEMS PLAN
EE601-A	ELECTRICAL DETAILS
EE602-A	ELECTRICAL DETAILS
EE601-A	ELECTRICAL RISER DIAGRAM
EE701-A	ELECTRICAL EQUIPMENT SCHEDULE
EE702-A	PANEL SCHEDULES

PROJECT DESCRIPTION

CONTRACTOR MUST COMPLETELY PREPARE SITE FOR BUILDING OPERATIONS, INCLUDING DEMOLITION AND REMOVAL OF EXISTING BUILDING MATERIALS, AND FURNISH LABOR AND MATERIALS AND PERFORM WORK FOR THE RENOVATE SPACE FOR LOGISTICS (B-1) PROJECT ON THE FIRST FLOOR OF BUILDING 1, AS REQUIRED BY DRAWINGS AND SPECIFICATIONS. THE CONTRACTOR MUST FURNISH ALL MANAGEMENT, SUPERVISION, LABOR, MATERIAL, EQUIPMENT, TOOLS, SUPPLIES, PARTS, AND RELATED SERVICES, IN ACCORDANCE WITH STATEMENT OF WORK (SOW), DRAWINGS, AND SPECIFICATIONS TO CONSTRUCT A COMPLETE AND WORKING SYSTEM. ELECTRONIC COPIES OF DRAWINGS AND SPECIFICATIONS TO THIS WORK WILL BE FURNISHED BY VA UPON CONTRACTOR'S WRITTEN REQUEST TO CONTRACTING OFFICER (VA-CO) OR CONTRACTING OFFICER'S REPRESENTATIVE (VA-COR). HARD COPIES OF SOW, DRAWINGS, AND SPECIFICATIONS ARE CONTRACTOR'S RESPONSIBILITY AND EXPENSE. THE CONTRACTOR IS RESPONSIBLE FOR VERIFYING EXISTING AND NEW DIMENSIONS, LOCATIONS, MEASUREMENTS, AND QUANTITIES. THIS PROJECT IS LOCATED ON THE MAIN CAMPUS OF THE VETERANS HEALTHCARE SYSTEM OF THE OZARKS (VHSO) AT 1100 NORTH COLLEGE AVENUE, IN FAYETTEVILLE, ARKANSAS.

COORDINATION DRAWINGS

THE GENERAL CONTRACTOR SHALL TAKE THE LEAD IN PREPARING COORDINATION DRAWINGS, INCLUDING THE COMPLETION OF A REVIT MODEL THAT IS BASED ON THE CONSTRUCTION DOCUMENT PDF FILES. SUCH DRAWINGS SHALL BE ARRANGED AND DESIGNED THROUGH AND FROM COORDINATION WITH ALL OTHER MAJOR AND MINOR SUBCONTRACTORS. PROVIDE PLAN VIEWS, SECTIONS, AND ELEVATIONS AS REQUIRED TO FULLY COORDINATE ALL NEW WORK WITH ITSELF AND EXISTING CONDITIONS. DRAW TO SCALE (AT NOT LESS THAN 3/8" = 1'-0"). DRAWINGS SHALL SHOW, BUT NOT BE LIMITED TO: ALL WALL RATINGS; ALL DUCTWORK; ALL AIR DISTRIBUTION; MECHANICAL EQUIPMENT; MECHANICAL PIPING; FIRE PROTECTION PIPING; ALL PLUMBING PIPING; CABLE TRAYS (WITH ELEVATIONS NOTED); LIGHTING FIXTURES; CEILING GRID AND CEILING HEIGHT; MAJOR BEAMS AND JOISTS (WITH ELEVATIONS MARKED); FIRE, SAFETY, AND SECURITY ALARM DEVICES AND SPEAKERS (WHERE CEILING MOUNTED); ELECTRICAL CONDUITS LARGER THAN 2-INCH DIAMETER; ELECTRICAL BUSWAY AND REQUIRED CLEARANCES; EQUIPMENT PROVIDED BY OTHERS THAT PROTRUDE INTO CEILING CAVITIES OR IMPEDS THE LOCATION OR ACCESS TO ABOVE CEILING PIPING OR DUCTWORK OF OTHER EQUIPMENT. SECTIONS SHALL BE CUT THROUGH AREAS SHOWING MATERIALS AND SYSTEMS OF ALL CONTRACTS. IF THERE ARE ANY OUTSTANDING ISSUES THAT CANNOT BE RESOLVED, CONSULT WITH THE PRIME ARCHITECT AND/OR ENGINEER THROUGH THE VA COR FOR GUIDANCE AND MAKE CORRECTIONS IN ACCORDANCE WITH DIRECTIONS GIVEN. IT IS IMPORTANT TO NOTE THAT FABRICATION CANNOT BEGIN UNTIL COORDINATION DRAWINGS HAVE BEEN APPROVED. MATERIALS, EQUIPMENT, SYSTEMS, ETC. SHALL NOT BE PROCURED OR INSTALLED PRIOR TO RECEIPT OF AN APPROVED SUBMITTAL.

SCHEDULE OF BID ITEMS

- ITEM 1: GENERAL CONSTRUCTION: WORK INCLUDES GENERAL CONSTRUCTION, ALTERATIONS, NECESSARY DEMOLITION AND CONSTRUCTION AND CERTAIN OTHER ITEMS.
- ITEM 2: DEDUCT ALTERNATE NO. 1: COMPLETE ALL BASE BID WORK EXCEPT DELETE ALL WORK ASSOCIATED WITH BATHROOM PORCELAIN TILED WALLS AND FLOORS. IN PLACE OF PORCELAIN TILE, INSTALL WALL PAINT ON WALLS AND INTEGRALLY COVERED, RESINOUS EPOXY FLOORING ON FLOORS AND WALL BASE.
- ITEM 3: DEDUCT ALTERNATE NO. 2: COMPLETE ALL BASE BID WORK EXCEPT DELETE DEDUCT ALTERNATE 1 AND DELETE FURNISHING THE WIRE SHELVING (JSN #M2055). IN DEDUCT ALTERNATE NO. 2, VA FURNISHES WIRE SHELVING UNITS (JSN #M2055).
- ITEM 4: DEDUCT ALTERNATE NO. 3: COMPLETE ALL BASE BID WORK EXCEPT DELETE DEDUCT ALTERNATE NO. 1, DEDUCT ALTERNATE NO. 2, AND DELETE FURNISHING THE EIFS AND COLD-FORMED METAL FRAMED EXTERIOR DUCT ENCLOSURE ON THE LOADING DOCK. INSTALL EXTERIOR METAL DUCT JACKETING IN PLACE OF THE EIFS AND COLD-FORMED METAL FRAMED ENCLOSURE. RETAIN THE BOLLARDS.
- COMPLETE ALL BASE BID WORK EXCEPT DELETE DEDUCT ALTERNATE NO. 1, DEDUCT ALTERNATE NO. 2, AND DELETE INSTALLING THE EAST FURRING WALL IN EMS PRIMARY STORAGE ROOM L116. ALSO, DELETE THE ELEVATOR WORK TO PERMANENTLY DISCONNECT THE DOUBLE-SIDED ELEVATOR DOORS THAT FORMERLY OPEN INTO EMS PRIMARY STORAGE ROOM L116. IN PLACE OF REMOVING THE EAST FURRING WALL, PAINT THE EXISTING WALL. RETAIN THE FLOOR BASE.

NAME BRAND OR EQUAL ITEMS:

- NAME BRAND OR EQUAL ITEMS.
 - CORIAN COUNTERTOPS
 - HARDIE BOARD BACKER BOARD FOR TILE WALLS
 - ALERTON AUTOMATIC TEMPERATURE CONTROLS*
 - ABB VARIABLE SPEED DRIVES
 - KOHLER SINGLE P-TRAPS AND CLEAN-OUTS
 - WOLVERINE BRASS PLUMBING FAUCETS, VALVES, STOPS
 - PACS AND INTRUSION DETECTION TYCO C CURE 9000 SERIES*
 - SECURITY - EXACOVISSION SOFTWARE*
 - CAMERAS - AXIS/ILLUSTR*
 - FIRE ALARM DEVICES - NOTIFIER*
 - ARDEX FLOOR TOPPING
 - PANEL AND DISTRIBUTION BOARDS - SCHNEIDER ELECTRICAL SQUARE D

*SYSTEM SHALL BE NATIVE COMPATIBLE, SHALL PROVIDE ALL EXISTING SYSTEM FUNCTIONS WITHOUT ANY THIRD PARTY INTEGRATION, AND SHALL MAINTAIN ALL TESTING AGENCY LISTINGS AND SERVICE AGREEMENTS FOR THE ENTIRE SYSTEM.

Revision Number	Revisions:	Date:

CONSULTANTS

CONSULTING STRUCTURAL ENGINEERS

BRITT, PETERS AND ASSOCIATES
consulting engineers

ARCHITECT/ENGINEER OF RECORD

AE:
HARRELL DESIGN GROUP PC
10720 SIKES PLACE, SUITE 100
CHARLOTTE, NC 28277
704-814-1346
POC: LEE HARRELL PE, LEED AP, QCCP
PRESIDENT
HDG PROJECT: 19022

HARRELL DESIGN GROUP PC
WWW.HARRELLDG.COM
COPYRIGHT © 2024

STAMP

Digital Signature not valid without Certificate

DRAWING TITLE

COVER SHEET, DRAWING INDEX, AND PROJECT INFORMATION

APPROVED

PHASE

CONSTRUCTION DOCUMENTS SUBMISSION

FULLY SPRINKLERED

PROJECT TITLE

RENOVATE SPACE FOR LOGISTICS (B-1)

PROJECT NUMBER

564-24-104

BUILDING NUMBER

1

DRAWING NUMBER

GI001-A

LOCATION

FAYETTEVILLE VA MEDICAL CENTER

ISSUE DATE

11 APRIL 2024

CHECKED

JC

DRAWN

MS

Engineering Service

VETERANS HEALTH CARE SYSTEM OF THE OZARKS

VA U.S. Department of Veterans Affairs

4/12/2024 11:19:44 AM
BIM 360/191922 - Fayetteville, IDIQ Project No. 64-19-103 Renovation of SPS/19022 - ARCH - R2020.rvt