



REVIEW SET  
30% REVIEW

Hight Jackson  
ASSOCIATES  
5201 W Village Parkway, Suite 300 | Rogers, Arkansas 72761 (479) 464-4965 | www.hjarch.com

BENTONVILLE SCHOOL DISTRICT #6  
BWFH - DEN Remodel  
1355 GAMBLE ROAD, CENTERTON, ARKANSAS

DRAWN BY:  
KPH  
CHECK BY:  
NEW  
ISSUE DATE:  
2/2/2026

PROJECT NO:  
2421

REVISION DATES


PLUMBING DEMO PLAN -  
AREA "A"

SHEET

P.2.0

COPYRIGHT 2026  
THESE DRAWINGS AND SPECIFICATIONS ARE  
THE EXCLUSIVE PROPERTY OF  
HIGHT JACKSON ASSOCIATES P.A.  
USE OR REPRODUCTION IS PROHIBITED  
WITHOUT WRITTEN CONSENT


HSA JOB # 25-200

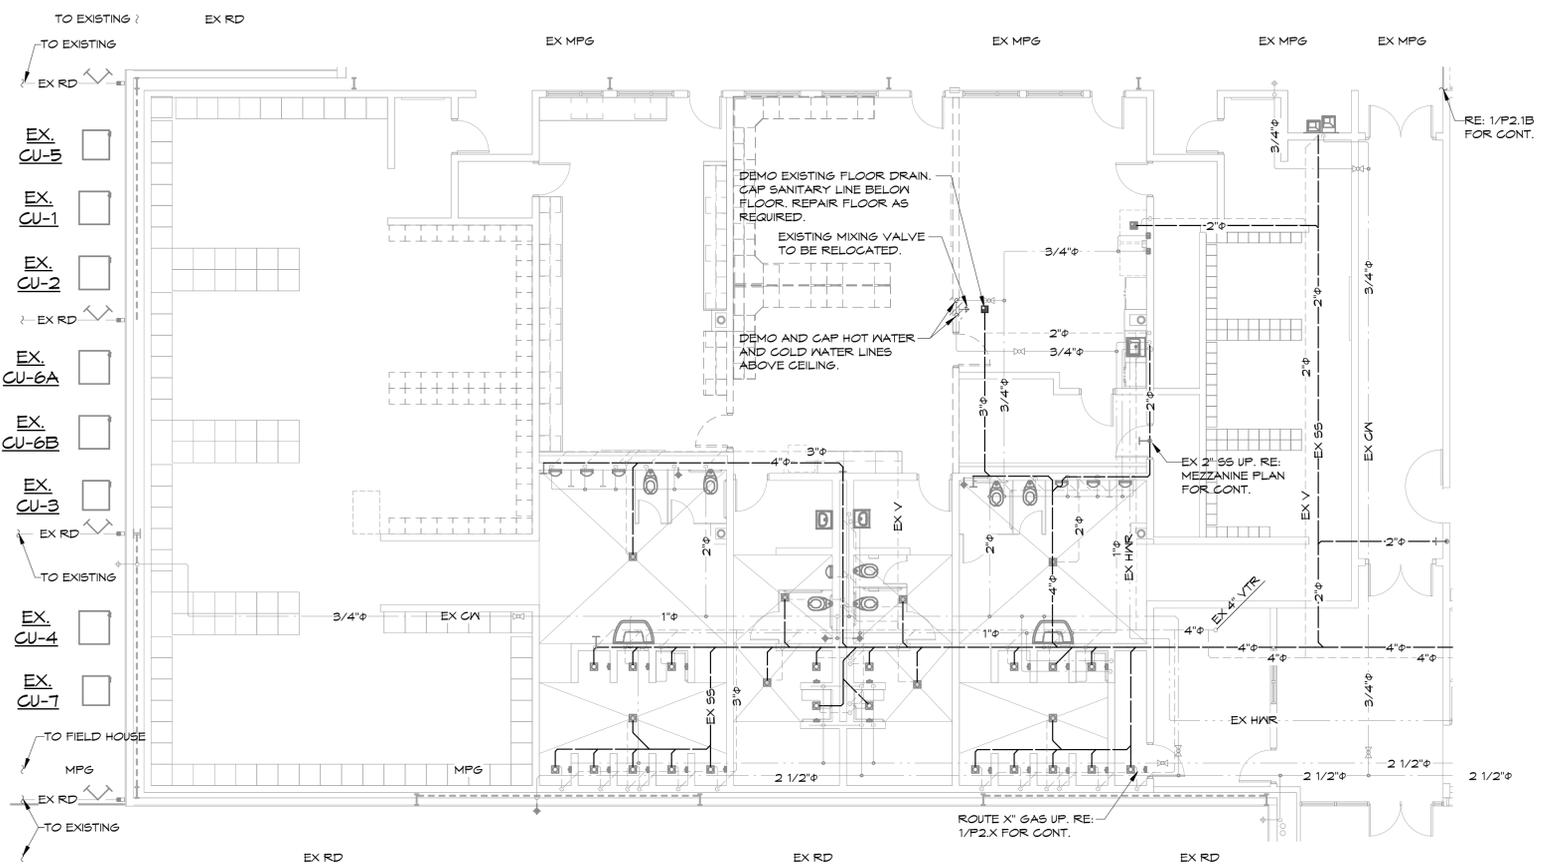

1 FIRST FLOOR PLUMBING DEMO PLAN - AREA "A"  
1/8" = 1'-0"

NOTE:  
REFER TO SHEET P1.1 FOR PLUMBING NOTES, LEGEND, DETAILS, & SCHEDULES.  
REFER TO SHEETS P2.1 & P2.2 FOR PLUMBING PLANS.

**HSA** Engineering  
479 / 452 / 8922 office  
7405 Ellis St.  
Fort Smith, AR 72916  
HSAConsultants.com

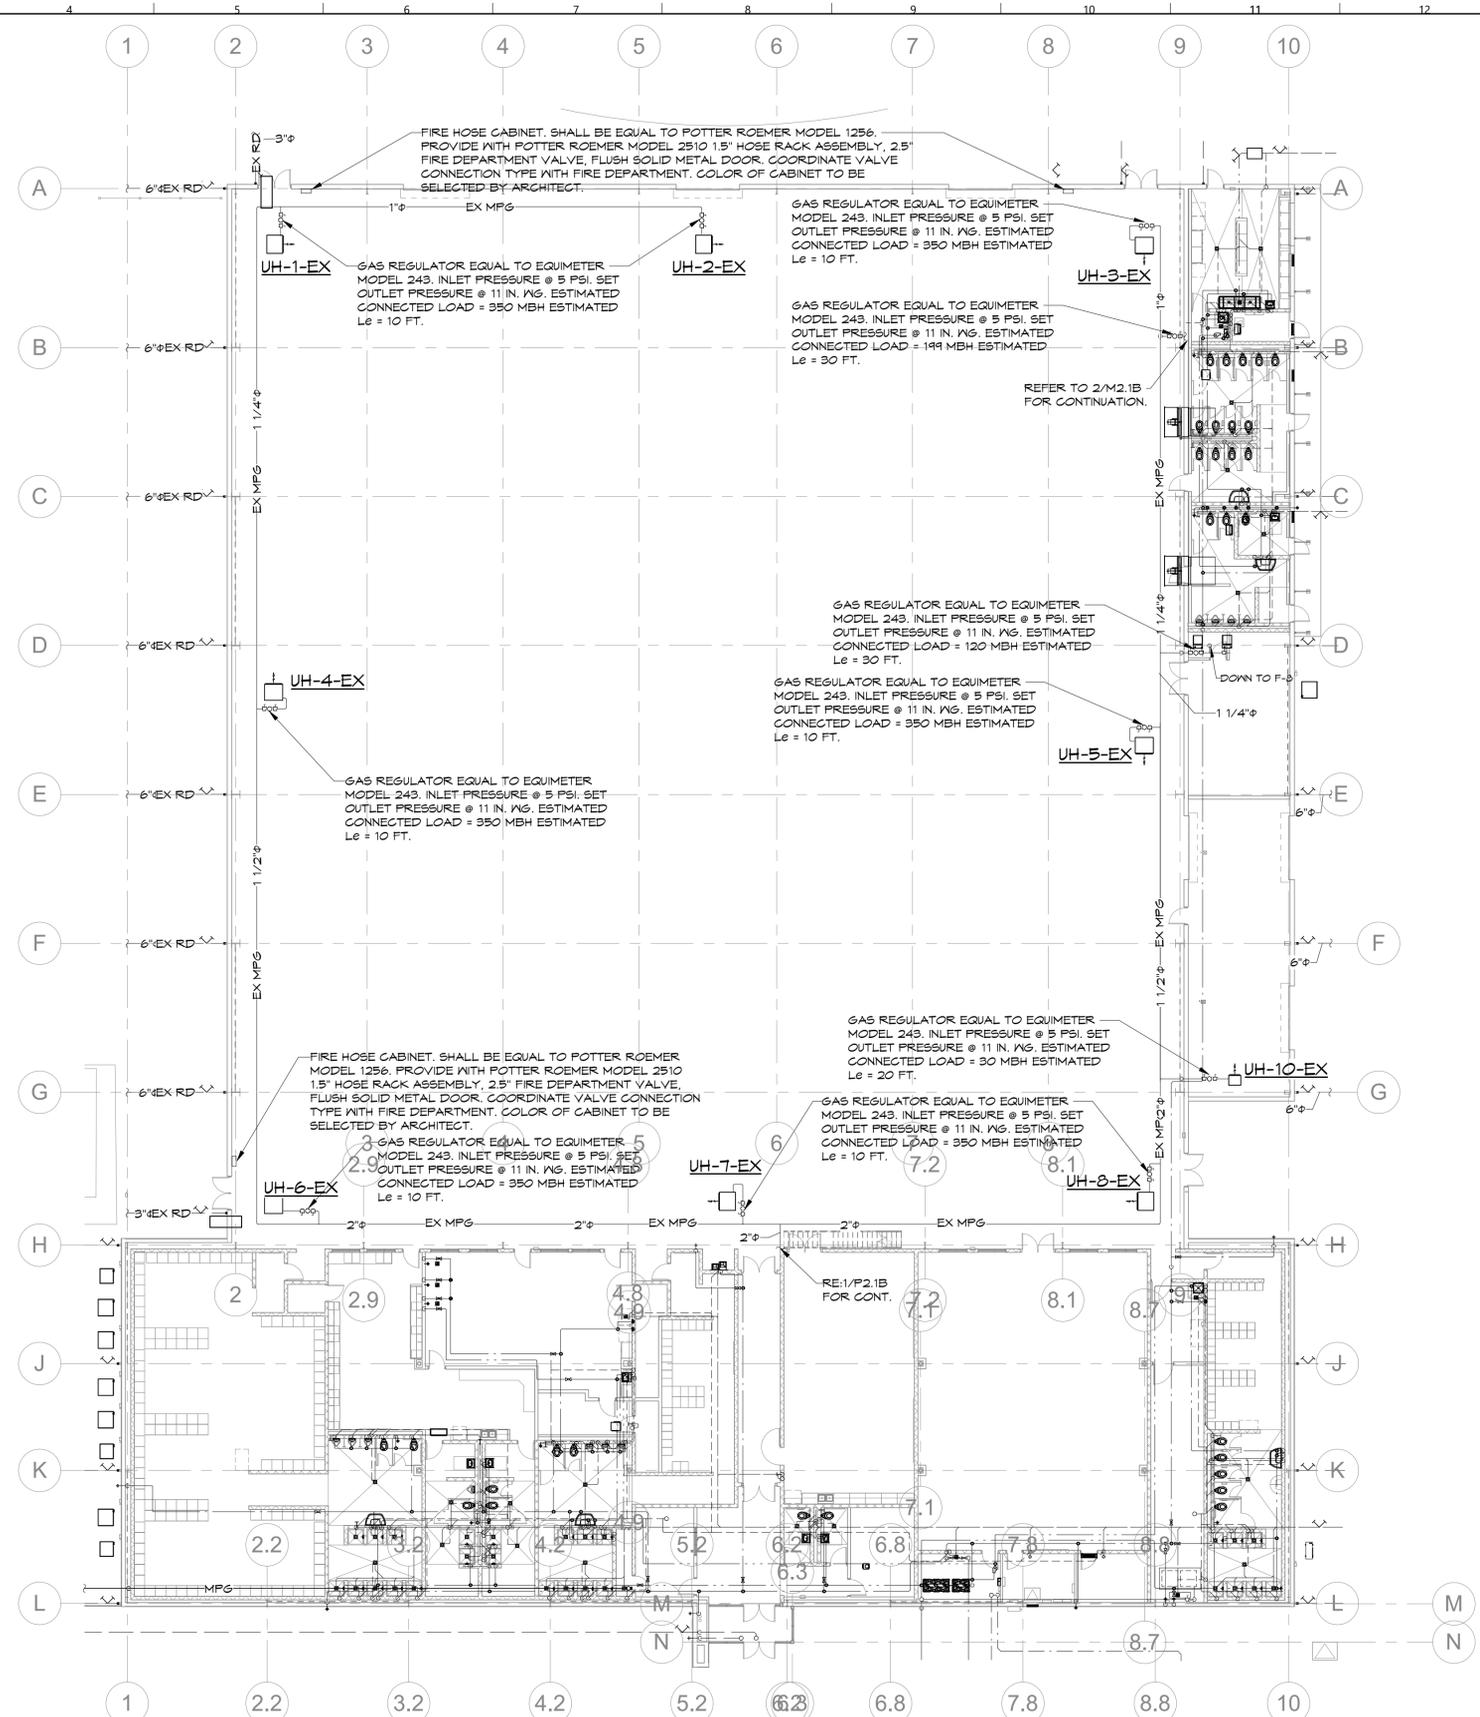

**1 OVERALL FIRST FLOOR PLUMBING PLAN**  
 1/16" = 1'-0"



**NOTE:**  
 REFER TO SHEET P1.1 FOR PLUMBING NOTES, LEGEND, DETAILS, & SCHEDULES.  
 REFER TO SHEETS P2.1 & P2.2 FOR PLUMBING PLANS.

**HSA** Engineering  
 479 / 452 / 8922 office  
 7405 Ellis St.  
 Fort Smith, AR 72916  
 HSAConsultants.com

**REVIEW SET**  
 30% REVIEW

**Hight Jackson**  
 ASSOCIATES  
 5201 W Village Parkway, Suite 3001 Rogers, Arkansas 72761 (479) 464-4965 | www.hjarch.com

BENTONVILLE SCHOOL DISTRICT #6  
**BWFH - DEN Remodel**  
 1355 GAMBLE ROAD, CENTERTON, ARKANSAS


DRAWN BY:  
**KPH**  
 CHECK BY:  
**NEW**  
 ISSUE DATE:  
**2/2/2026**

PROJECT NO:  
**2421**

REVISION DATES

PLUMBING PLAN  
 SHEET  
**P2.1**

COPYRIGHT 2026  
 THESE DRAWINGS AND SPECIFICATIONS ARE  
 THE EXCLUSIVE PROPERTY OF  
 HIGHT JACKSON ASSOCIATES P.A.  
 USE OR REPRODUCTION IS PROHIBITED  
 WITHOUT WRITTEN CONSENT

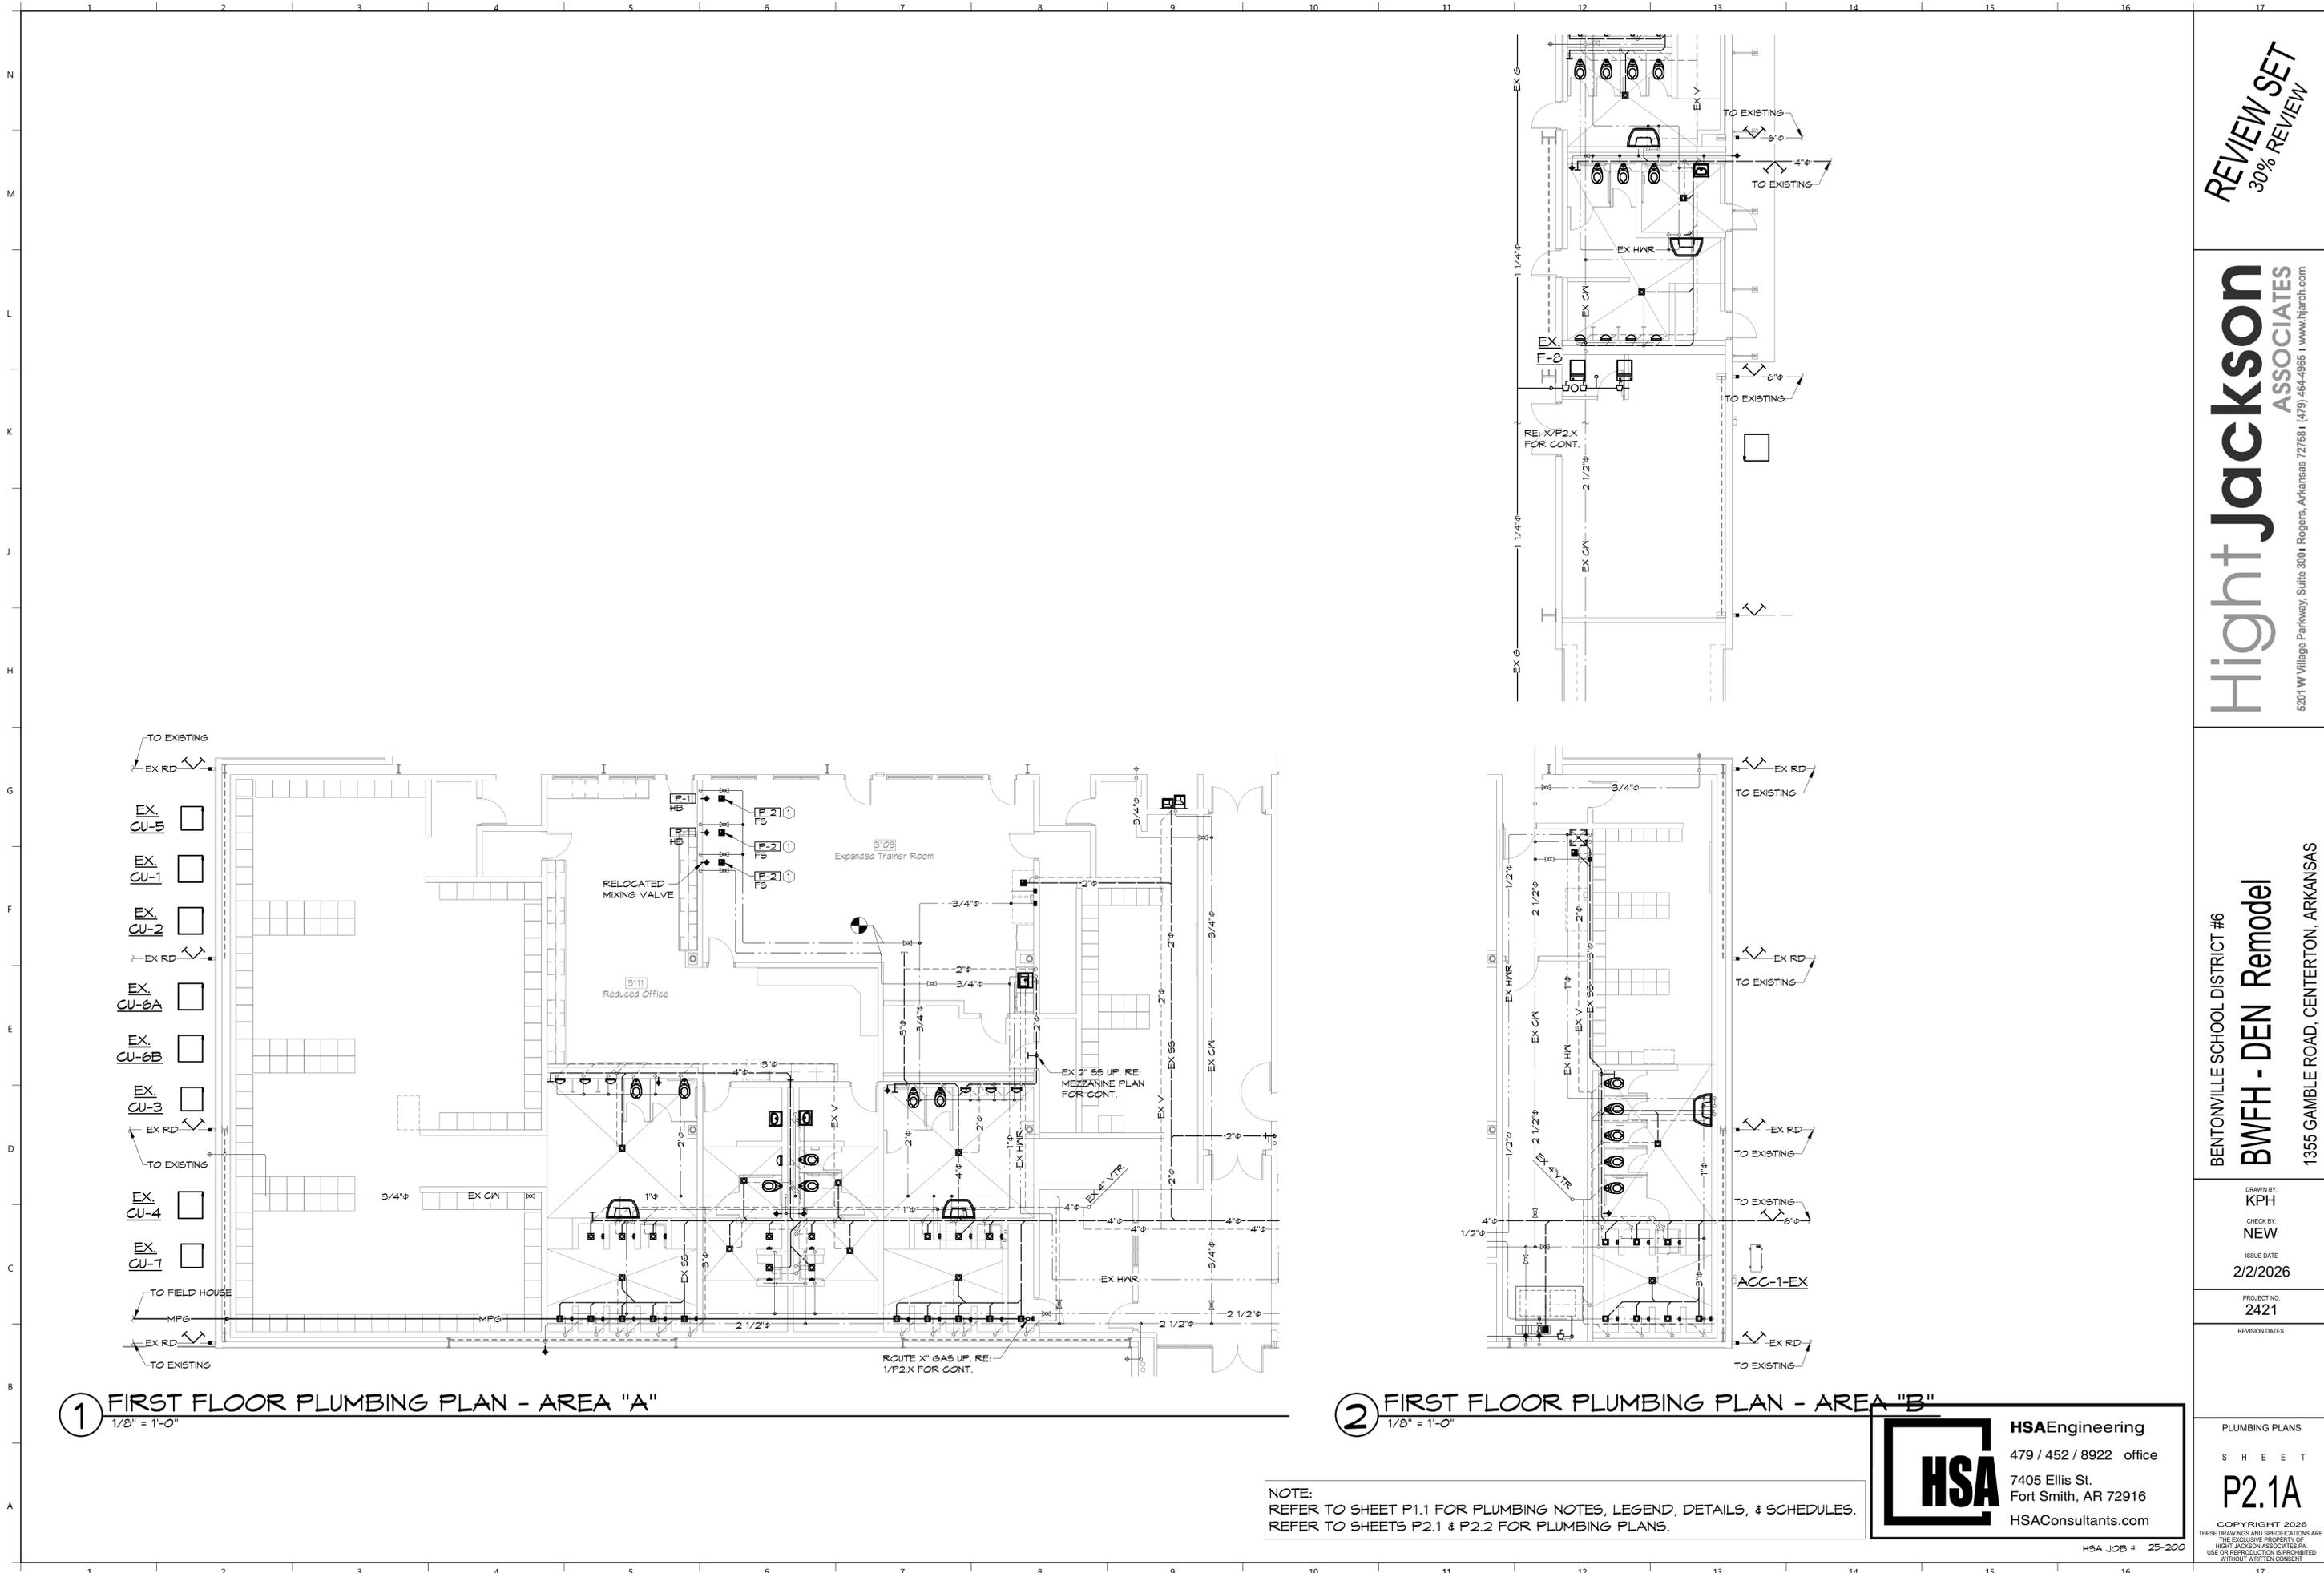

① FIRST FLOOR PLUMBING PLAN - AREA "A"  
1/8" = 1'-0"

② FIRST FLOOR PLUMBING PLAN - AREA "B"  
1/8" = 1'-0"

NOTE:  
REFER TO SHEET P1.1 FOR PLUMBING NOTES, LEGEND, DETAILS, & SCHEDULES.  
REFER TO SHEETS P2.1 & P2.2 FOR PLUMBING PLANS.

**HSA** Engineering  
 479 / 452 / 8922 office  
 7405 Ellis St.  
 Fort Smith, AR 72916  
 HSAConsultants.com

REVIEW SET  
30% REVIEW

**Hight Jackson**  
ASSOCIATES  
 5201 W Village Parkway, Suite 300 | Rogers, Arkansas 72768 | (479) 464-4965 | www.hjarch.com

BENTONVILLE SCHOOL DISTRICT #6  
**BWFH - DEN Remodel**  
 1355 GAMBLE ROAD, CENTERTON, ARKANSAS

DRAWN BY:  
KPH  
 CHECK BY:  
NEW  
 ISSUE DATE:  
2/2/2026

PROJECT NO:  
2421

REVISION DATES

PLUMBING PLANS  
 SHEET  
**P2.1A**  
 COPYRIGHT 2026  
 THESE DRAWINGS AND SPECIFICATIONS ARE  
 THE EXCLUSIVE PROPERTY OF  
 HIGHT JACKSON ASSOCIATES, P.A.  
 USE OR REPRODUCTION IS PROHIBITED  
 WITHOUT WRITTEN CONSENT

REVIEW SET  
30% REVIEW

Hight Jackson  
ASSOCIATES  
5201 W Village Parkway, Suite 3001 Rogers, Arkansas 72768 | (479) 464-4965 | www.hjarch.com

BENTONVILLE SCHOOL DISTRICT #6  
BWFH - DEN Remodel  
1355 GAMBLE ROAD, CENTERTON, ARKANSAS

DRAWN BY:  
KPH  
CHECK BY:  
NEW  
ISSUE DATE:  
2/2/2026

PROJECT NO:  
2421

REVISION DATES


PLUMBING PLAN - MEZZ

SHEET

P2.1B

COPYRIGHT 2026  
THESE DRAWINGS AND SPECIFICATIONS ARE  
THE EXCLUSIVE PROPERTY OF  
HIGHT JACKSON ASSOCIATES P.A.  
USE OR REPRODUCTION IS PROHIBITED  
WITHOUT WRITTEN CONSENT

HSA JOB # 25-200

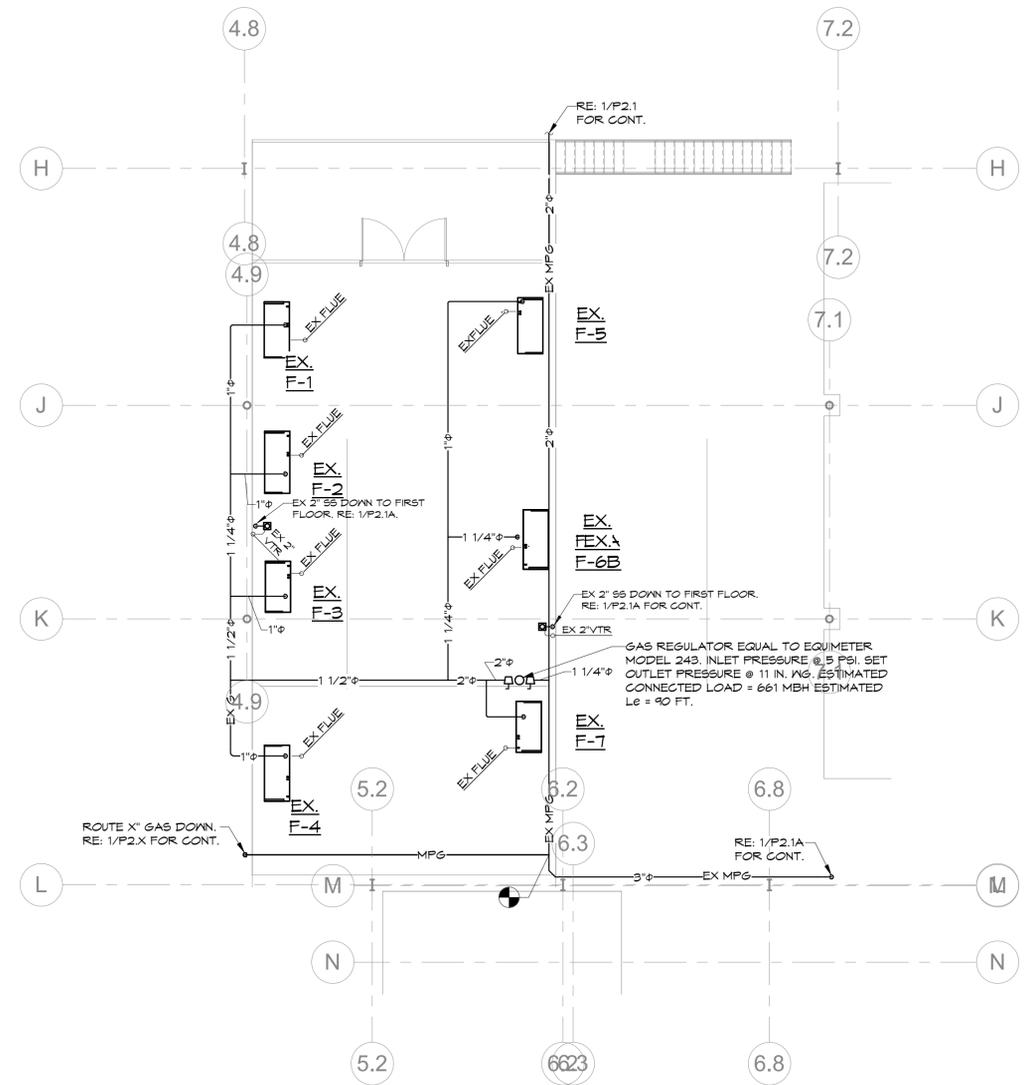

1 MEZZANINE PLUMBING PLAN  
1/8" = 1'-0"

NOTE:  
REFER TO SHEET P1.1 FOR PLUMBING NOTES, LEGEND, DETAILS, & SCHEDULES.  
REFER TO SHEETS P2.1 & P2.2 FOR PLUMBING PLANS.

**HSA** Engineering  
479 / 452 / 8922 office  
7405 Ellis St.  
Fort Smith, AR 72916  
HSAConsultants.com