 



ELECTRICAL DEMO GENERAL NOTES

1. FOR ALL DEVICES IN WALLS/MILLWORK BEING DEMOLISHED: DISCONNECT REMOVE CONDUIT AND WIRE BACK TO JUNCTION POINT. MAINTAIN CONTINUITY TO REMAINING DEVICES ON THAT CIRCUIT.
2. FOR ALL UNUSED CIRCUITS, REMOVE CONDUIT AND WIRE BACK TO SOURCE, LABEL BREAKER AS SPARE.
3. REFER TO ARCHITECTURAL DRAWINGS FOR AREAS TO BE DEMOLISHED.
4. GRAYED OUT DEVICES SHOW EXISTING TO REMAIN DEVICE LOCATIONS.
5. DEVICES SHOWN AS BOLD OR DASHED ARE TO BE REMOVED AND DISPOSED OF UNLESS OTHERWISE NOTED.
6. REMOVE POWER TO ALL EXISTING EQUIPMENT TO BE DEMOLISHED, COORDINATE WITH ALL TRADES.
7. EXISTING LIGHT FIXTURES LABELED "RRE": REMOVE, PROTECT, AND STORE ON SITE. LOCATE AS SHOWN ON LIGHTING PLANS. REPLACE ALL EXISTING BROKEN OR DISCOLORED LIGHT FIXTURE LENSES. REPLACE ALL EXISTING BURNT OUT LAMPS AND BALLASTS.
8. OCCUPANCY SENSORS IN CEILINGS BEING DEMOLISHED ARE TO BE REMOVED AND RELOCATED, REFER TO ELECTRICAL LIGHTING SHEETS FOR NEW LOCATIONS.
9. WIFI DEVICES IN CEILINGS BEING DEMOLISHED ARE TO BE REMOVED AND RELOCATED, REFER ELECTRICAL POWER SHEETS FOR NEW LOCATIONS.
10. EXISTING FIRE ALARM DEVICES IN WALLS OR CEILINGS BEING DEMOLISHED ARE TO BE REMOVED AND RELOCATED AS SHOWN ON SPECIAL SYSTEMS PLAN.
11. FIELD VERIFY ALL EXISTING CONDITIONS.


ELECTRICAL DEMO LEGEND





SUBSCRIPTS
 ER= EXISTING TO REMAIN
 RE= REMOVE EXISTING
 RRE= REMOVE AND RELOCATE EXISTING
 S= SURFACE MOUNT

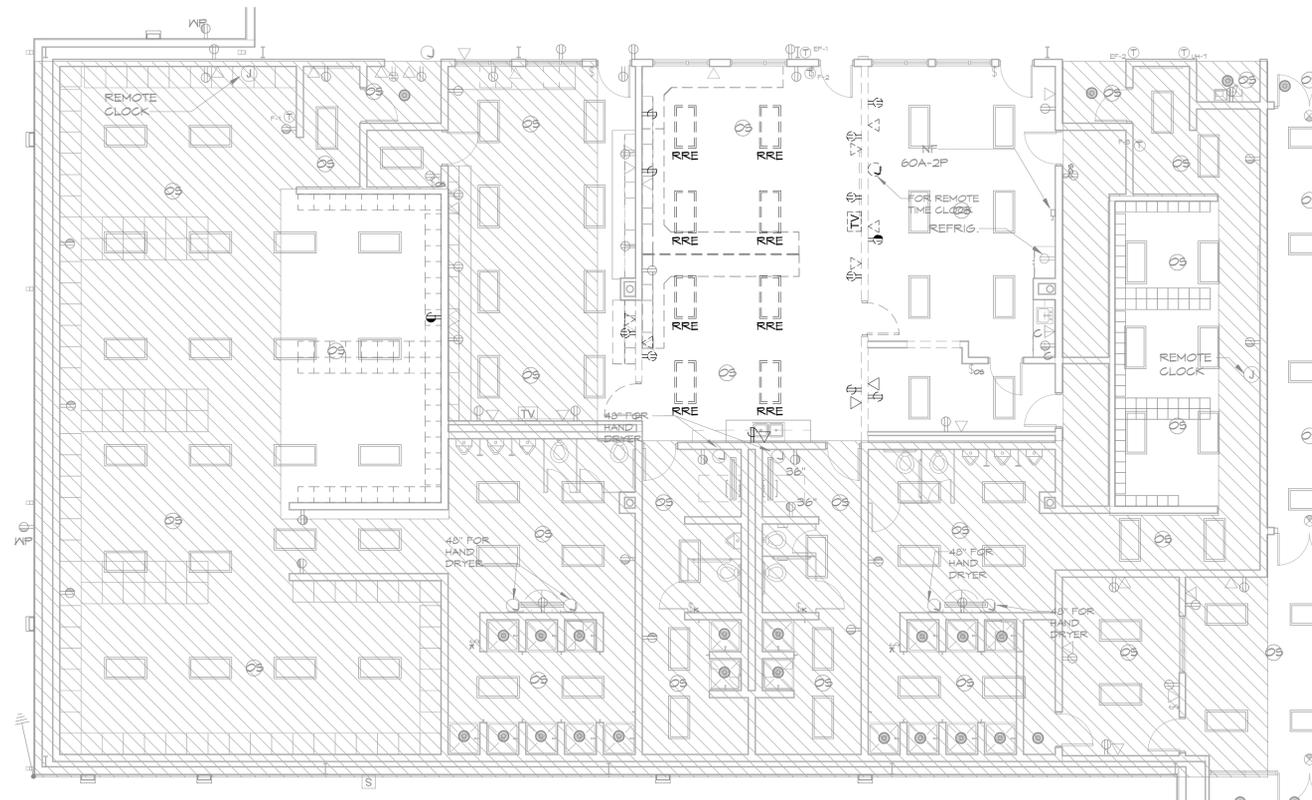

1 ELECTRICAL DEMOLITION PLAN - AREA "A"
1/8" = 1'-0"

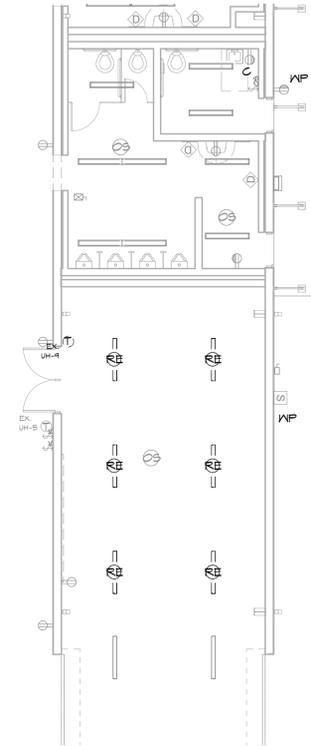

2 ELECTRICAL DEMOLITION PLAN - AREA "B"
1/8" = 1'-0"

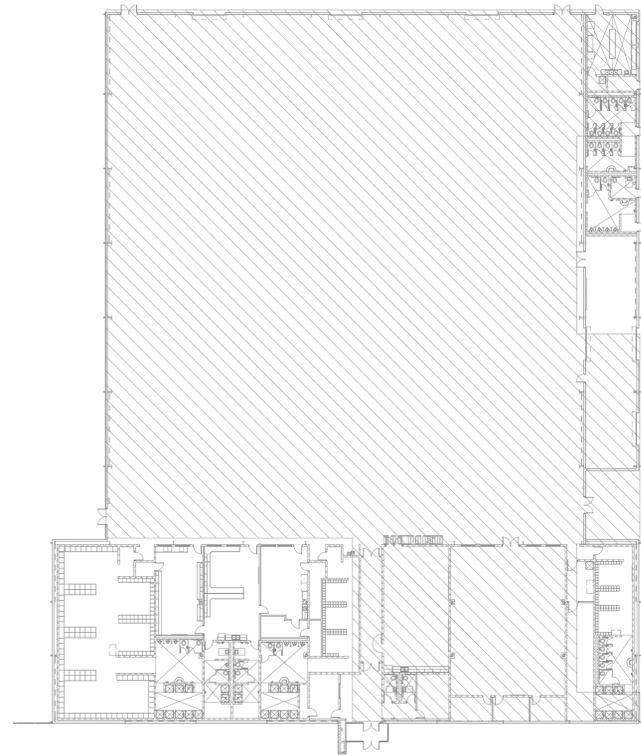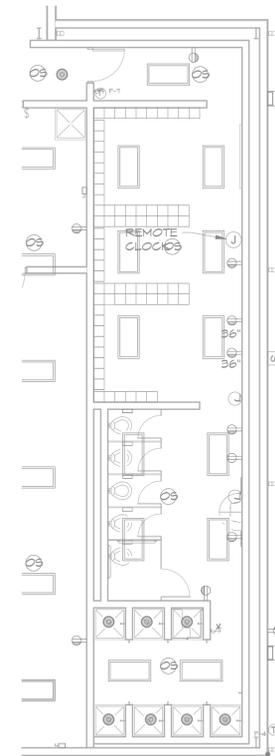


HSAEngineering
 479 / 452 / 8922 office
 7405 Ellis St.
 Fort Smith, AR 72916
 HSAConsultants.com

REVIEW SET
30% REVIEW

Hight Jackson
ASSOCIATES
5201 W Village Parkway, Suite 300 | Rogers, Arkansas 72768 | (479) 464-4965 | www.hjarch.com

BENTONVILLE SCHOOL DISTRICT #6
BWFH - DEN Remodel
 1355 GAMBLE ROAD, CENTERTON, ARKANSAS

DRAWN BY:
G.S.
 CHECK BY:
M.T.R.
 ISSUE DATE:
2/2/2026

PROJECT NO:
2421

REVISION DATES





ELECTRICAL DEMOLITION
 PLAN
 S H E E T
E.2.0

COPYRIGHT 2026
 THESE DRAWINGS AND SPECIFICATIONS ARE
 THE EXCLUSIVE PROPERTY OF
 HIGHT JACKSON ASSOCIATES P.A.
 USE OR REPRODUCTION IS PROHIBITED
 WITHOUT WRITTEN CONSENT

LIGHTING FIXTURE SCHEDULE

MARK	VOLT	WATT	LAMP				MOUNTING		MANUFACTURER	CATALOG NO.	REMARKS
			NO.	COLOR	TEMP	BRKT	PEND	REC			
A2	UNV	41	--	4000K				X	H.E. WILLIAMS METALUX	LT-24-L52/840-AF-DIM-UNV 24CZ2-55-S-UNV-L840-CD1-U	2X4' LED DIRECT INDIRECT TROFFER, 5200 LUMEN OUTPUT, 0-10V
RRE											EXISTING LIGHT FIXTURE TO BE REMOVED AND RELOCATED.
RE											EXISTING LIGHT FIXTURE TO BE REMOVED AND RETURNED TO THE OWNER

NOTE: HOLD ALL INSULATION OFF RECESSED FIXTURES AT A MINIMUM OF 3" TO THE SIDE.
 NOTE: EXIT LIGHTS AND EMERGENCY LIGHTS REQUIRES UNSWITCHED HOT WIRE PER MANUFACTURER RECOMMENDATION.
 NOTE: FIXTURES MARKED AS "GTBS" REQUIRE STANDARD FINISHED SELECTED BY THE ARCHITECT.
 NOTE: FOR ALL FIXTURES WITH 0-10V DIMMING, PROVIDE LOW VOLTAGE CABLE.
 NOTE: FIXTURES MARKED NL REQUIRE UNSWITCHED HOT WIRE.
 NOTE: ELECTRICAL CONTRACTOR TO PROVIDE AND INSTALL LED AND DRIVER COMBINATIONS THAT WILL PROVIDE THE OWNER WITH A FIVE YEAR WARRANTY ON THE FIXTURE.
 NOTE: FIELD VERIFY ALL FIXTURE LENGTHS NOTES AS LENGTH PER PLANS, PROVIDE CONTINUOUS RUNS OF FIXTURES. COORDINATE WITH THE ARCHITECTURAL DRAWINGS AND THE ARCHITECT.

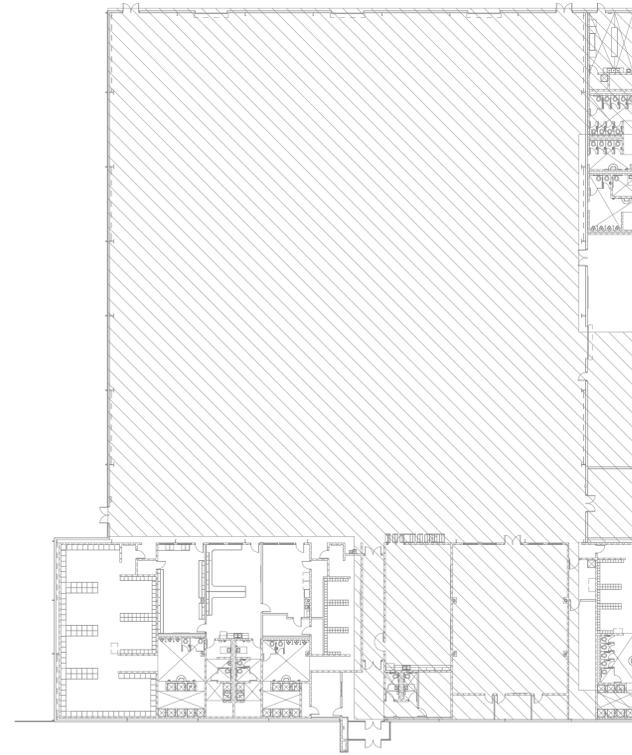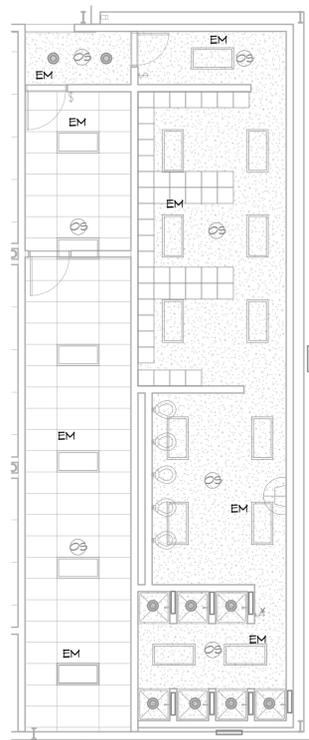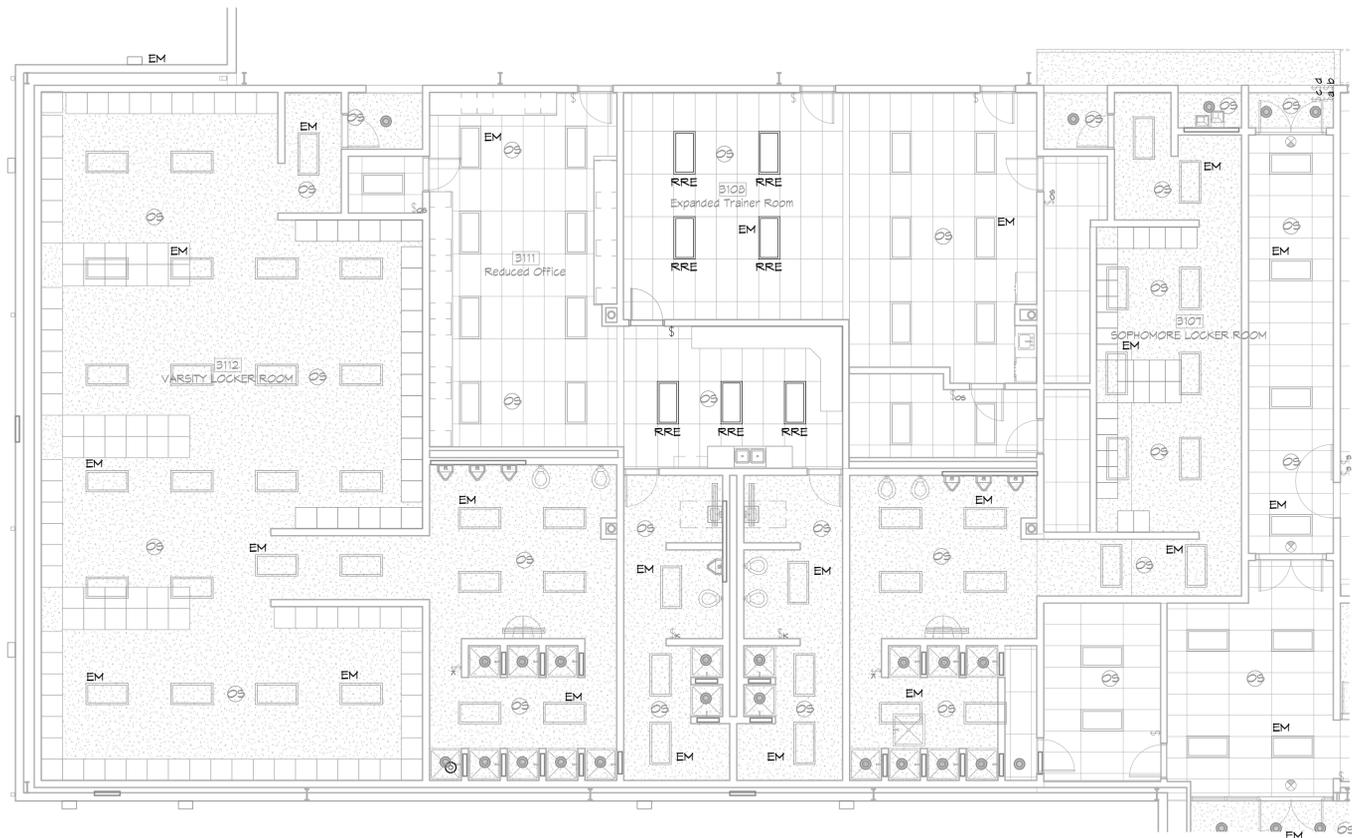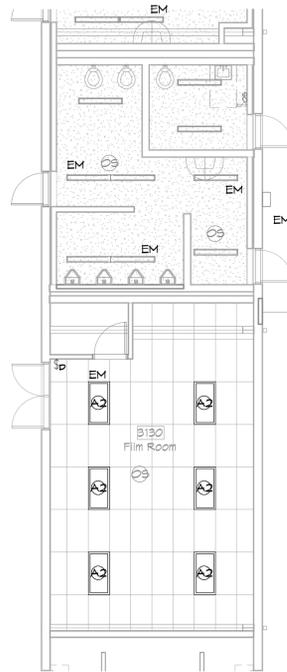

1 LIGHTING PLAN - AREA "A"
1/8" = 1'-0"

2 LIGHTING PLAN - AREA "B"
1/8" = 1'-0"

HSA Engineering
 479 / 452 / 8922 office
 7405 Ellis St.
 Fort Smith, AR 72916
 HSAConsultants.com

REVIEW SET
30% REVIEW

Hight Jackson
ASSOCIATES
5201 W Village Parkway, Suite 300 | Rogers, Arkansas 72768 | (479) 464-4965 | www.hjarch.com

BENTONVILLE SCHOOL DISTRICT #6
BWFH - DEN Remodel
 1355 GAMBLE ROAD, CENTERTON, ARKANSAS

DRAWN BY: GS
 CHECK BY: CER
 ISSUE DATE: 2/2/2026

PROJECT NO: 2421

REVISION DATES

LIGHTING PLAN
 SHEET
E2.1

COPYRIGHT 2026
 THESE DRAWINGS AND SPECIFICATIONS ARE THE EXCLUSIVE PROPERTY OF HIGHT JACKSON ASSOCIATES P.A. USE OR REPRODUCTION IS PROHIBITED WITHOUT WRITTEN CONSENT.

HSA JOB # 25-200

REVIEW SET
30% REVIEW

Hight Jackson
ASSOCIATES
5201 W Village Parkway, Suite 300 | Rogers, Arkansas 72768 | (479) 464-4965 | www.hjarch.com

BENTONVILLE SCHOOL DISTRICT #6
BWFH - DEN Remodel
1355 GAMBLE ROAD, CENTERTON, ARKANSAS

DRAWN BY:
GS

CHECK BY:
CER

ISSUE DATE:
2/2/2026

PROJECT NO:
2421

REVISION DATES

POWER PLAN





SHEET

E.2.2

COPYRIGHT 2026
THESE DRAWINGS AND SPECIFICATIONS ARE
THE EXCLUSIVE PROPERTY OF
HIGHT JACKSON ASSOCIATES P.A.
USE OR REPRODUCTION IS PROHIBITED
WITHOUT WRITTEN CONSENT


HSA JOB # 25-200

HSA Engineering
 479 / 452 / 8922 office
 7405 Ellis St.
 Fort Smith, AR 72916
 HSAConsultants.com

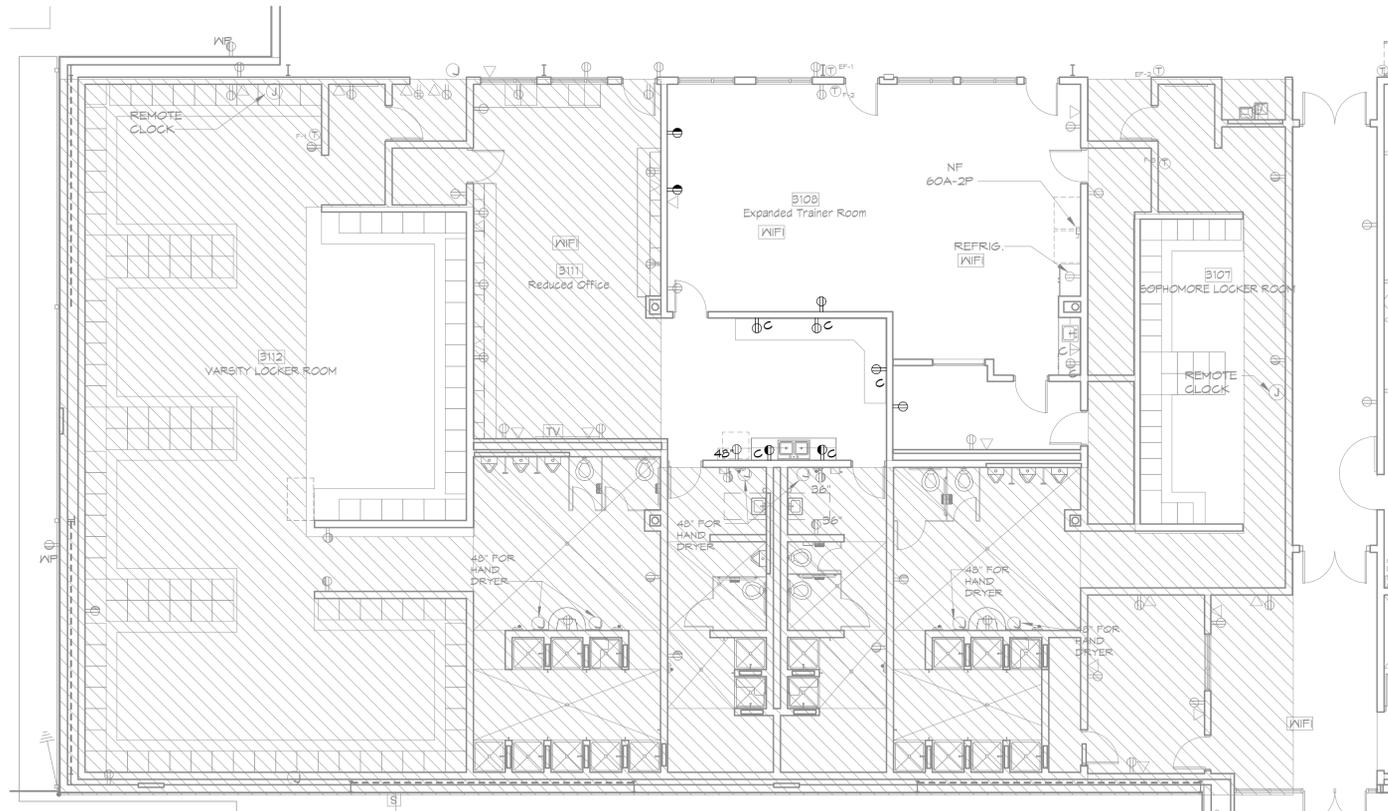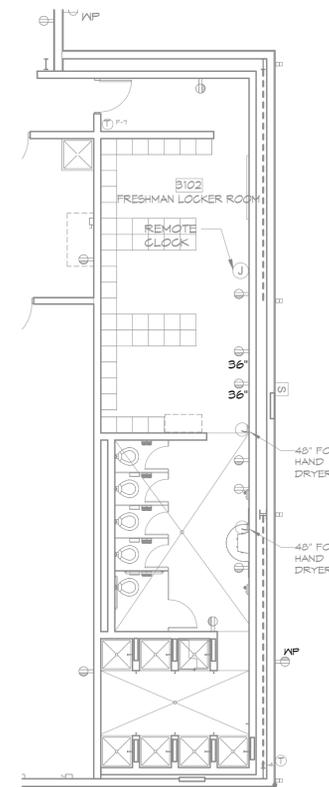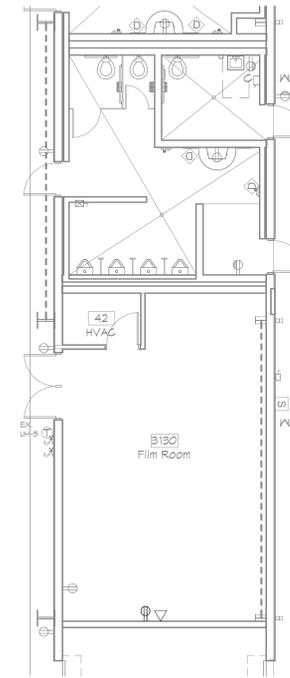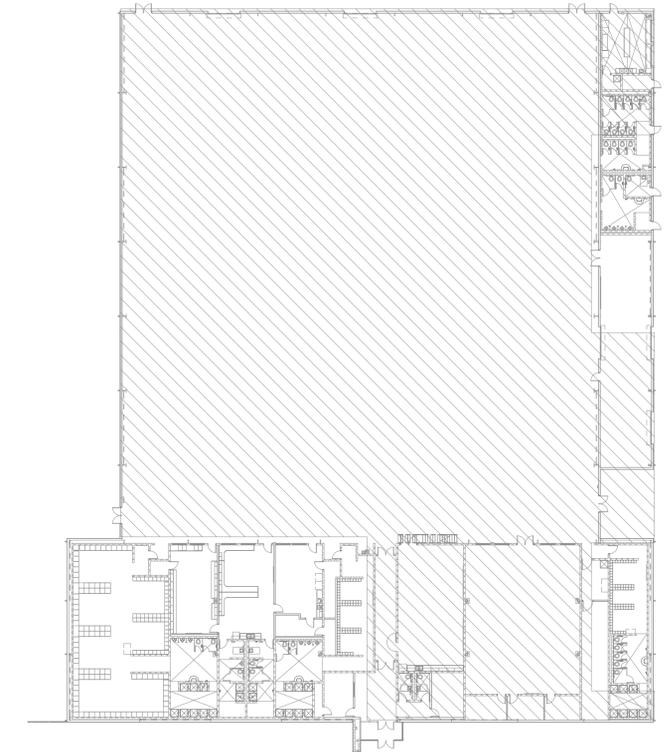

1 POWER PLAN - AREA "A"
1/8" = 1'-0"

2 POWER PLAN - AREA "B"
1/8" = 1'-0"

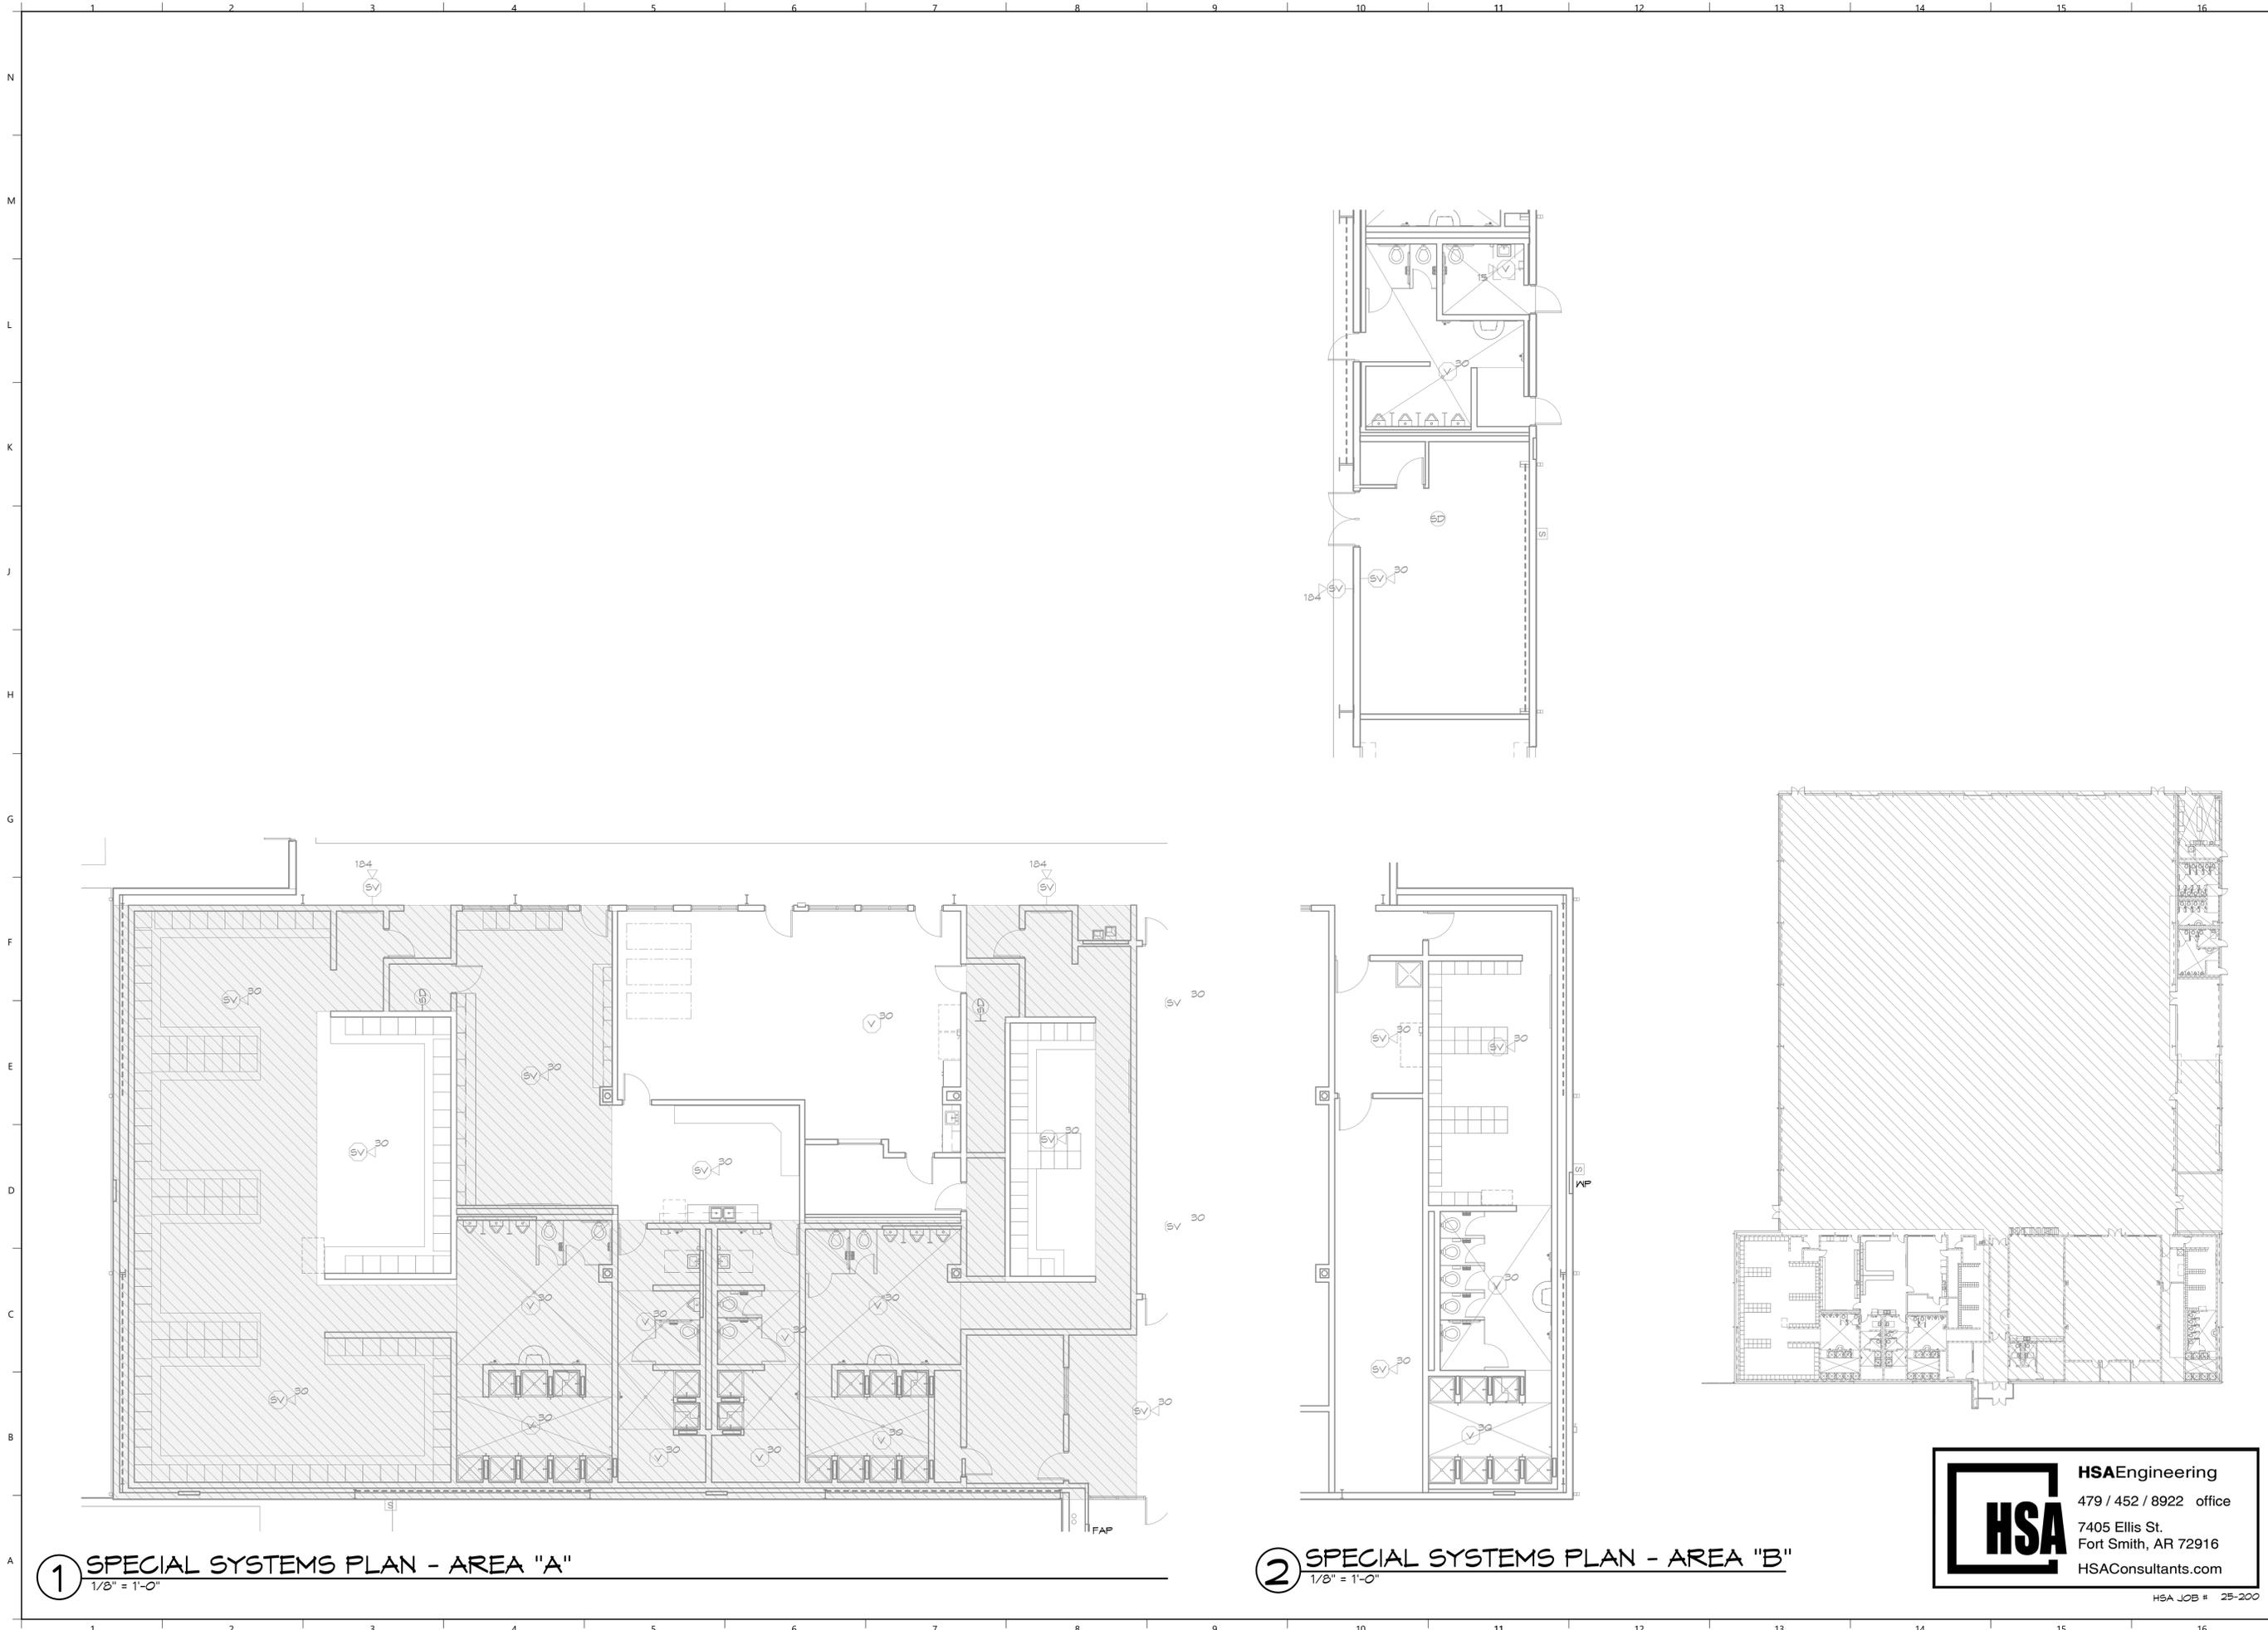

1 SPECIAL SYSTEMS PLAN - AREA "A"
1/8" = 1'-0"

2 SPECIAL SYSTEMS PLAN - AREA "B"
1/8" = 1'-0"

HSA Engineering
 479 / 452 / 8922 office
 7405 Ellis St.
 Fort Smith, AR 72916
 HSAConsultants.com

REVIEW SET
30% REVIEW

Hight Jackson
ASSOCIATES
 5201 W Village Parkway, Suite 300 | Rogers, Arkansas 72768 | (479) 464-4965 | www.hjarch.com

BENTONVILLE SCHOOL DISTRICT #6
BWFH - DEN Remodel
 1355 GAMBLE ROAD, CENTERTON, ARKANSAS

DRAWN BY: GS
 CHECK BY: CER
 ISSUE DATE: 2/2/2026

PROJECT NO: 2421

REVISION DATES

SPECIAL SYSTEMS PLAN

SHEET
E.2.3

COPYRIGHT 2026
 THESE DRAWINGS AND SPECIFICATIONS ARE
 THE EXCLUSIVE PROPERTY OF
 HIGHT JACKSON ASSOCIATES P.A.
 USE OR REPRODUCTION IS PROHIBITED
 WITHOUT WRITTEN CONSENT

HSA JOB # 25-200