



Hight Jackson
ASSOCIATES
5201 W Village Parkway, Suite 3001 Rogers, Arkansas 72768 | (479) 464-4965 | www.hjarch.com

A RESTORATION FOR
RPS Administration Building
500 W Walnut St. Rogers AR 72756

DRAWN BY:
AS
CHECK BY:
MR
ISSUE DATE
11/25/2025

PROJECT NO.
2534

REVISION DATES
12/17/2025

ELECTRICAL DETAILS
SHEET
E3.1

COPYRIGHT 2025
THESE DRAWINGS AND SPECIFICATIONS ARE THE EXCLUSIVE PROPERTY OF HIGHT JACKSON ASSOCIATES P.A. USE OR REPRODUCTION IS PROHIBITED WITHOUT WRITTEN CONSENT.


HSA JOB # 25-155

RISER LEGEND


- EXISTING TO BE DEMOLISHED
- EXISTING TO REMAIN
- NEW

RISER NOTES

1. ALL DOWN TIME OF ELECTRICAL SERVICE TO THE BUILDING IS TO BE KEPT TO A MINIMUM AND BE OUT OF THE NORMAL WORKING HOURS. COORDINATE ALL DOWN TIME WITH THE OWNER.
2. COORDINATE ELECTRICAL SERVICE INSTALLATION WITH SNEPCO. ATTENTION CHRIS ANDREOLLI AT 479.225.0813
3. ELECTRICAL CONTRACTOR IS RESPONSIBLE FOR THE COST ASSOCIATED WITH THE ELECTRICAL SERVICE. COORDINATE WITH SNEPCO.
4. ELECTRICAL CONTRACTOR IS RESPONSIBLE FOR ALL CUTTING/PATCHING OF HARD SURFACES, TRENCHING, BACKFILL, ETC FOR ELECTRICAL SERVICE INSTALLATION.

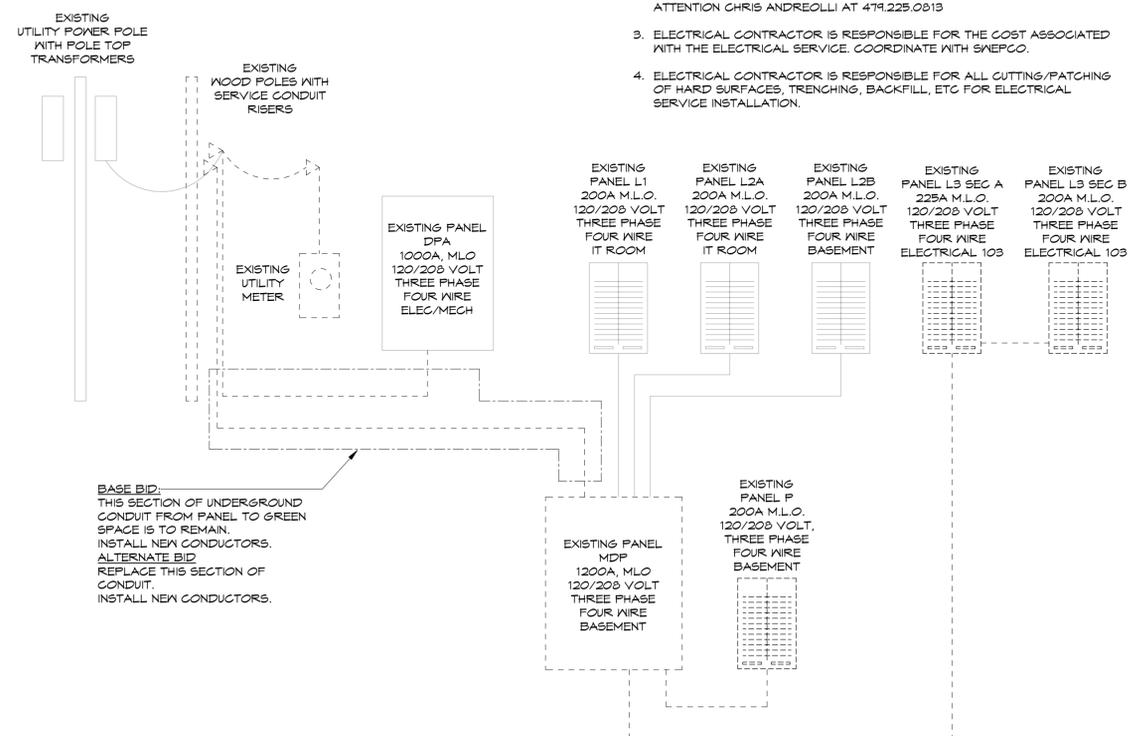

1 DEMO ELECTRICAL RISER DIAGRAM
N.T.S.

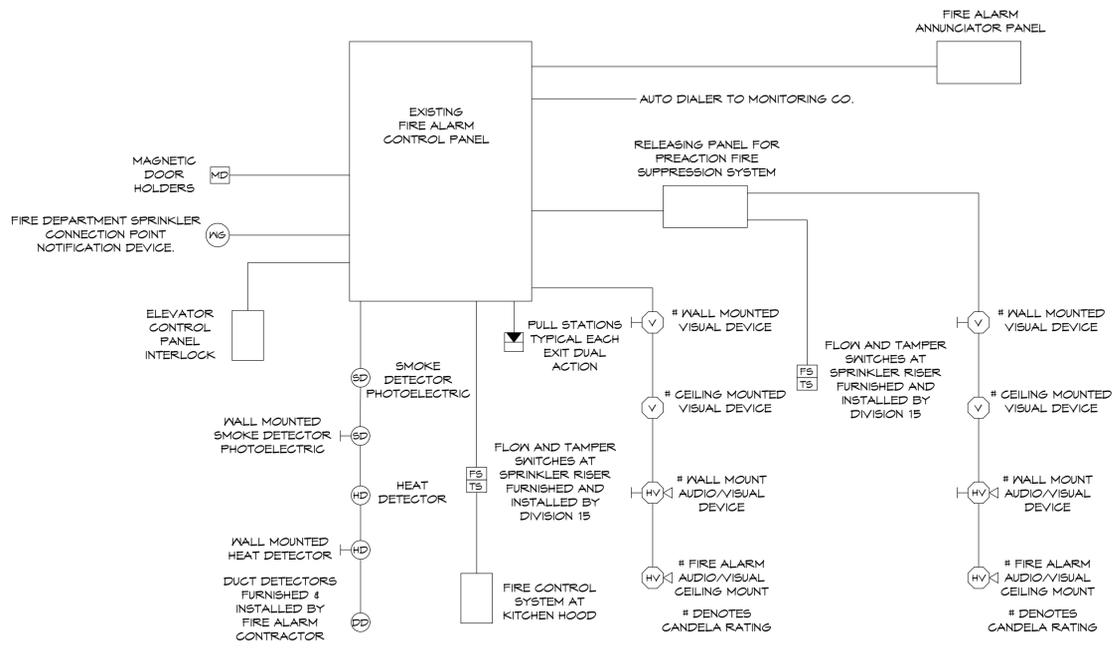


- NOTE:**
1. INSTALL WIRING TO ALL DUCT DETECTORS. REFER TO SPECIAL SYSTEMS PLANS.
 2. COORDINATE WITH THE MECHANICAL DRAWINGS.
 3. COORDINATE WITH THE LOCAL "A.H.J." PRIOR TO BIDDING THIS PROJECT.
 4. FIRE ALARM CONTRACTOR TO MODIFY AS NECESSARY FOR SYSTEM PROVIDED.
 5. FIRE ALARM CONTRACTOR TO PROVIDE DETECTION AND RELEASE OF PRACTION FIRE SUPPRESSION SYSTEM. COORDINATE WITH FIRE SUPPRESSION CONTRACTOR TO PROVIDE ALL COMPONENTS FOR A COMPLETE AND WORKING SYSTEM

3 FIRE ALARM SYSTEM RISER DIAGRAM
N.T.S.

FEEDER SCHEDULE

- 1 3 SETS: 4-300 MCM, 1-#1/0 GRD; 3" CONDUIT EACH
- 2 4-#1/0, 1-#6 GRD; 2" CONDUIT
- 3 4-#3/0, 1-#6 GRD; 2" CONDUIT
- 4 2 SETS: 4-500 MCM, 4" CONDUIT EACH
- 5 4 SETS: 4-500 MCM, 4" CONDUIT EACH

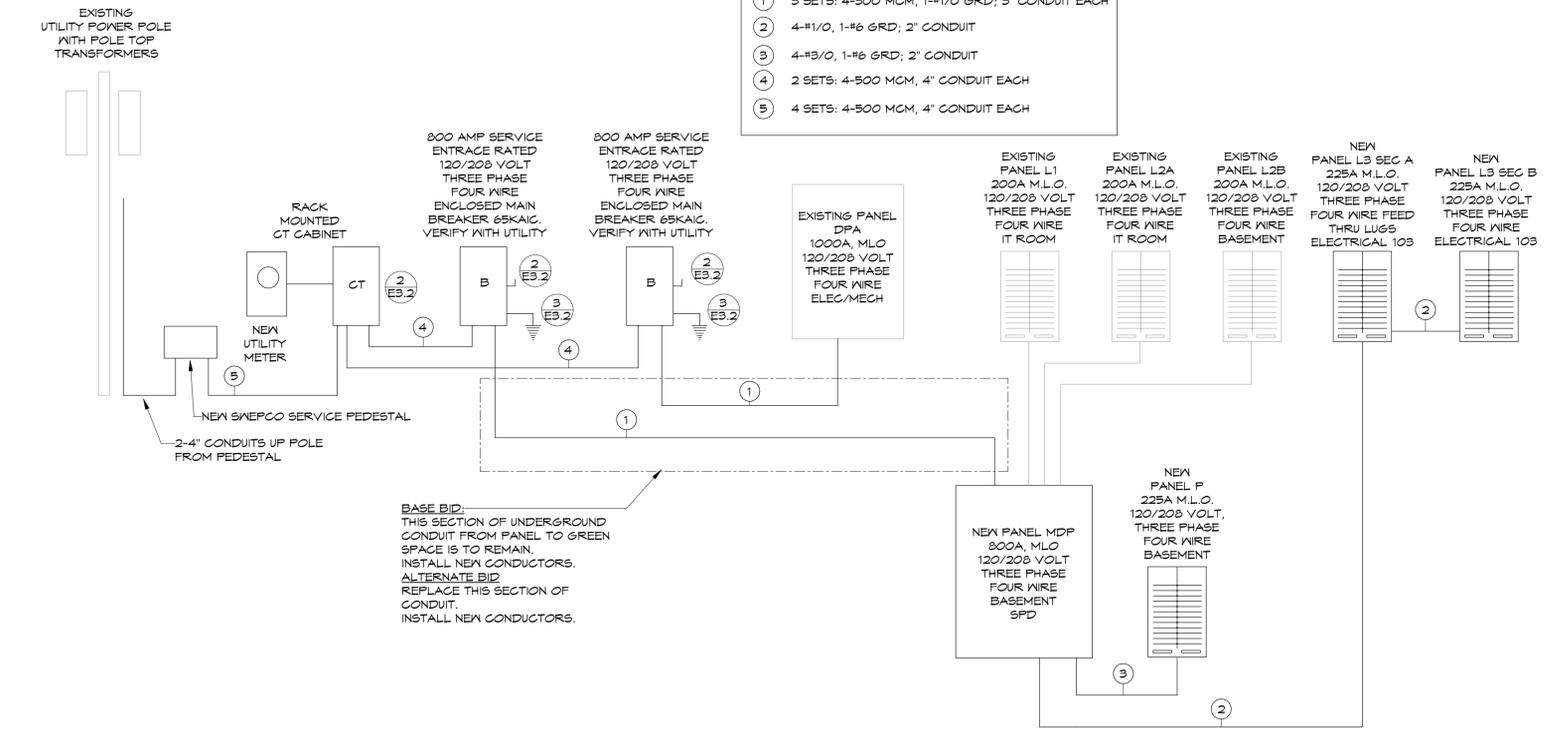

2 NEW ELECTRICAL RISER DIAGRAM
N.T.S.

HSA HSAEngineering
479 / 452 / 8922 office
7405 Ellis St.
Fort Smith, AR 72916
HSAConsultants.com