

Hight Jackson
ASSOCIATES
5201 W Village Parkway, Suite 3001 Rogers, Arkansas 72768 | (479) 464-4965 | www.hjarch.com

A RESTORATION FOR
RPS Administration Building
500 W Walnut St. Rogers AR 72756

DRAWN BY:
DCN
CHECK BY:
NEW
ISSUE DATE:
11/25/2025
PROJECT NO:
2534
REVISION DATES:
12/17/2025

PHASE 3 - MECHANICAL
DEMO PLAN

SHEET



M2.0

COPYRIGHT 2025
THESE DRAWINGS AND SPECIFICATIONS ARE
THE EXCLUSIVE PROPERTY OF
HIGHT JACKSON ASSOCIATES P.A.
USE OR REPRODUCTION IS PROHIBITED
WITHOUT WRITTEN CONSENT

HSA JOB # 25-155

DEMOLITION NOTES


- 1 DEMO EXISTING VAV BOX WITH ASSOCIATED DUCTWORK AND CONTROL VALVES.
- 2 DEMO EXISTING T-STAT
- 3 DEMO EXISTING ROOF EXHAUST FAN WITH ASSOCIATED DUCTWORK.
- 4 DEMO EXISTING ROOF OPENING AND CURB FRAMING, DECK INFILL AND ROOF REPAIR BY GC AND ROOFING CONTRACTOR.

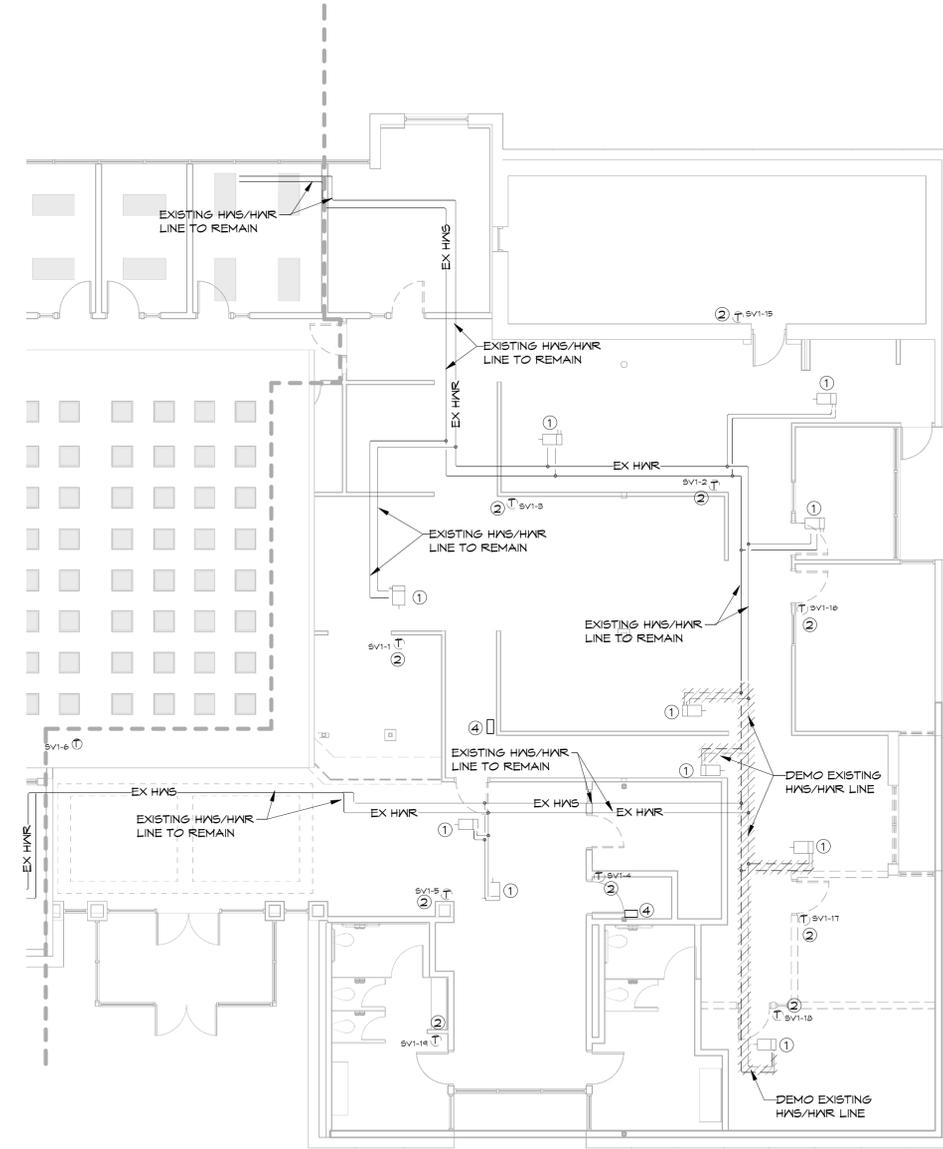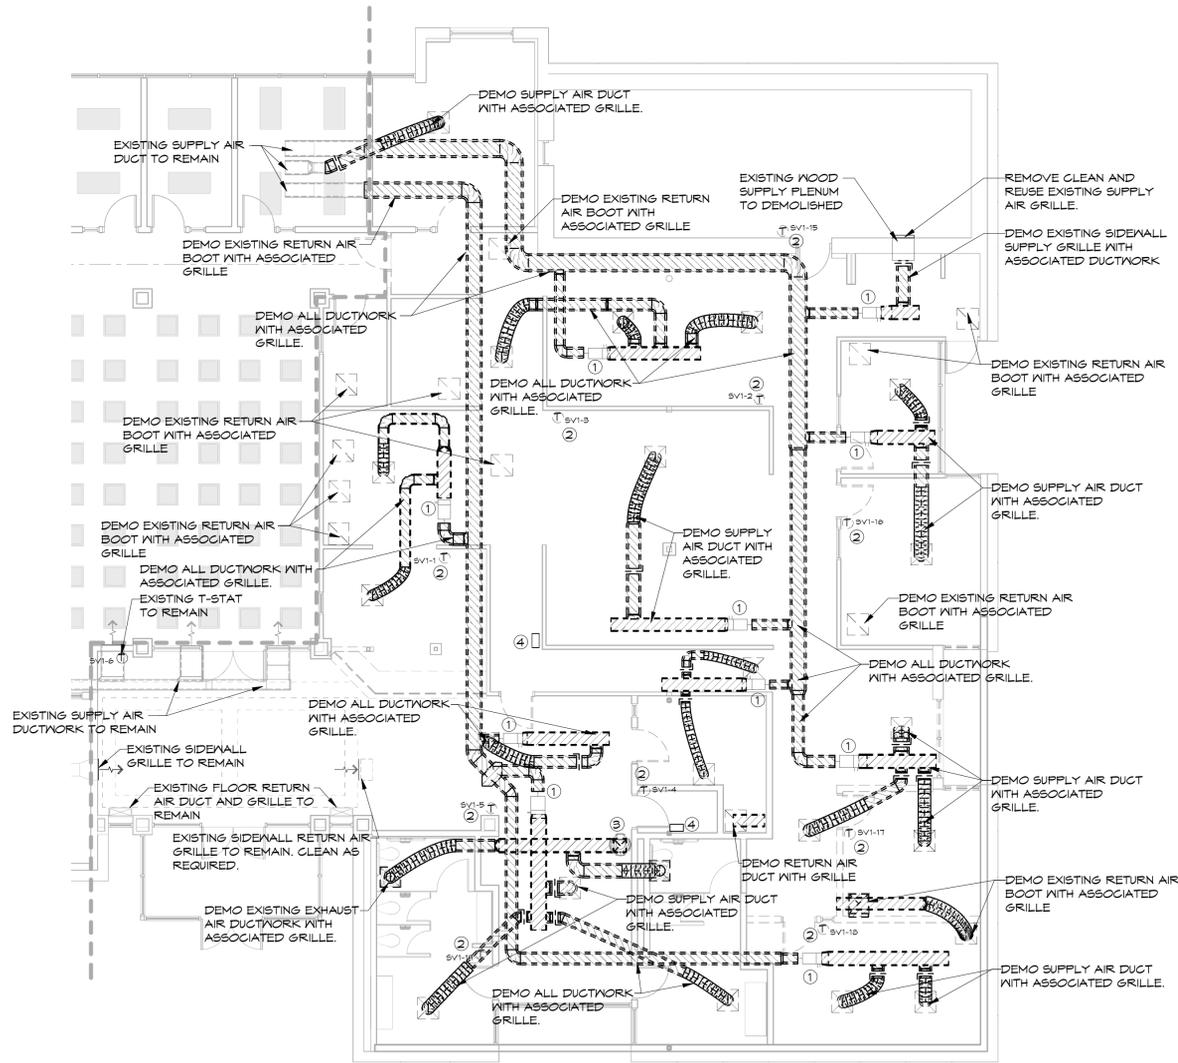

1 PHASE 3 - FIRST FLOOR HVAC DEMOLITION PLAN
1/8" = 1'-0"



2 PHASE 3 - FIRST FLOOR MECH PIPING DEMOLITION PLAN
1/8" = 1'-0"

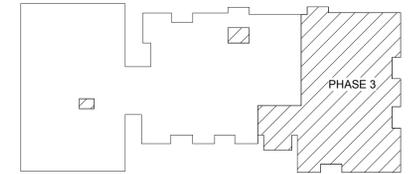

KEYPLAN

NOTES:
REFER TO SHEET M1.1 FOR HVAC NOTES, LEGEND AND SCHEDULES
REFER TO SHEET M2.0 FOR HVAC DEMO PLANS
REFER TO SHEET M2.1 FOR HVAC PLANS.
REFER TO SHEET M3.1 FOR HVAC DETAILS.

HSA HSAEngineering
479 / 452 / 8922 office
7405 Ellis St.
Fort Smith, AR 72916
HSAConsultants.com