


Hight Jackson
ASSOCIATES
5201 W Village Parkway, Suite 300 | Rogers, Arkansas 72761 | (479) 464-4965 | www.hjarch.com


A RESTORATION FOR
RPS Administration Building
500 W Walnut St. Rogers AR 72756

DRAWN BY:
DCN
CHECK BY:
NEW
ISSUE DATE:
11/25/2025
PROJECT NO:
2534
REVISION DATES:
12/17/2025


PHASE 3 - FIRST FLOOR
HVAC PLAN
SHEET
M2.1
COPYRIGHT 2025
THESE DRAWINGS AND SPECIFICATIONS ARE
THE EXCLUSIVE PROPERTY OF
HIGHT JACKSON ASSOCIATES, P.A.
USE OR REPRODUCTION IS PROHIBITED
WITHOUT WRITTEN CONSENT

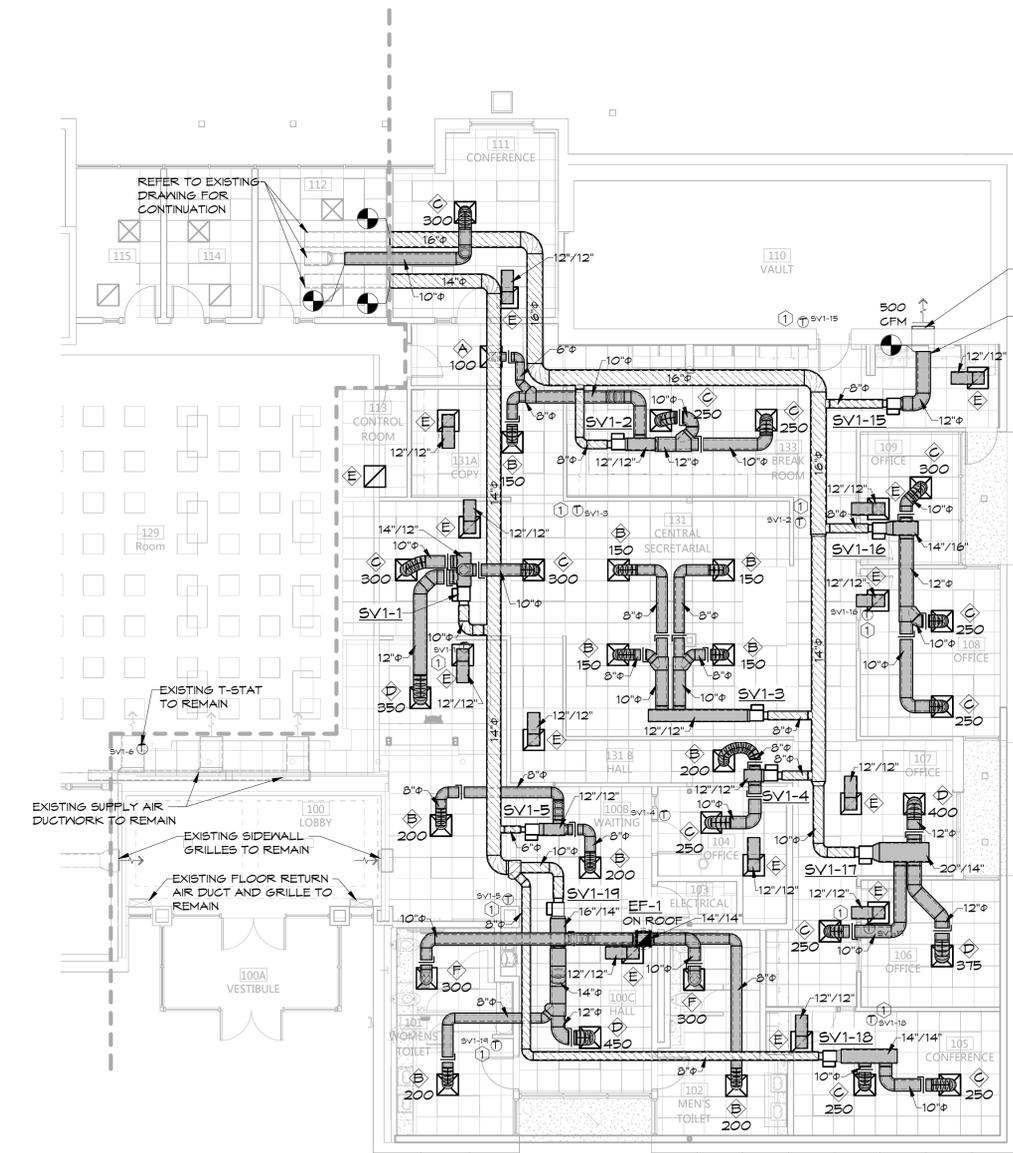

1 PHASE 3 - FIRST FLOOR HVAC PLAN
1/8" = 1'-0"

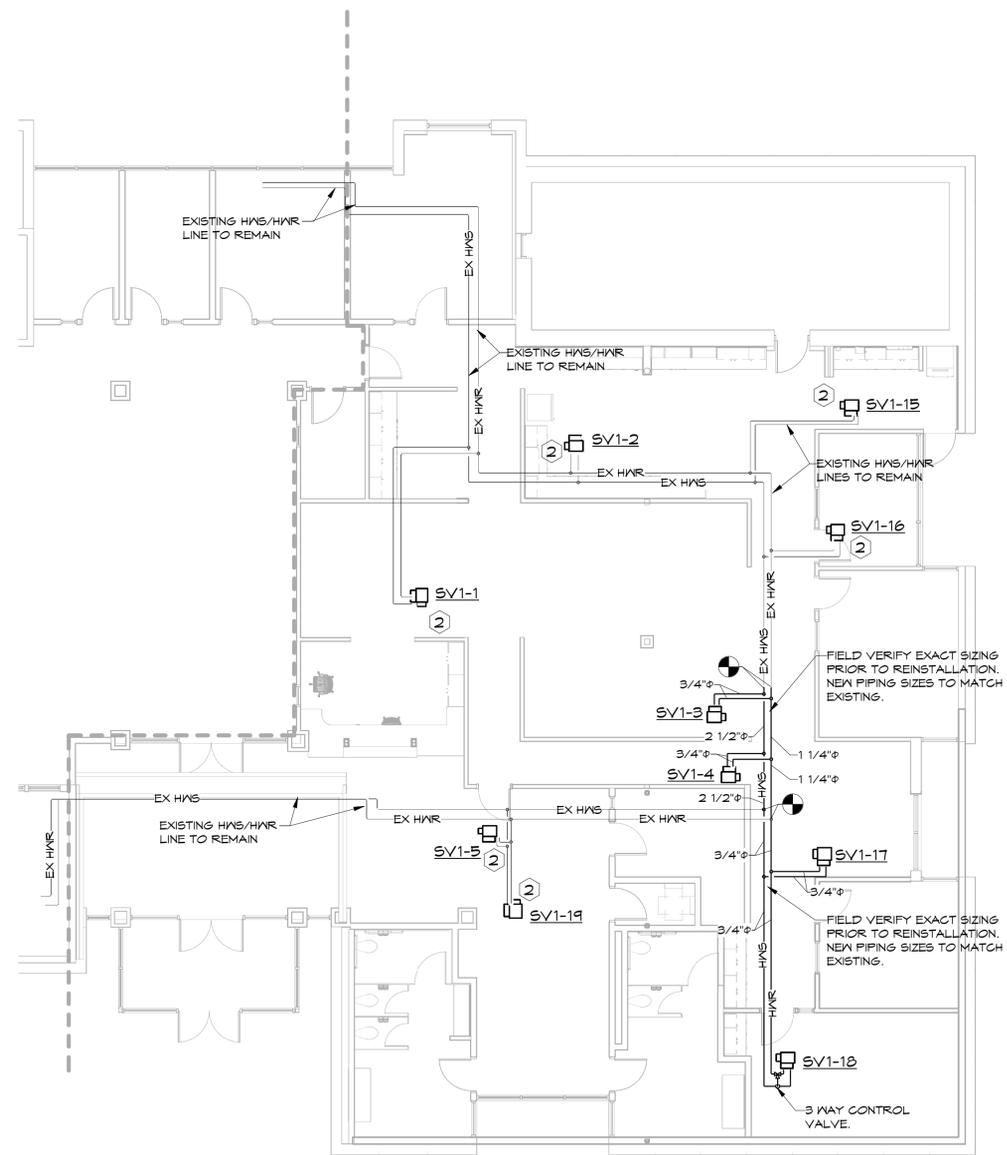

3 PHASE 3 - FIRST FLOOR MECH PIPING PLAN
1/8" = 1'-0"

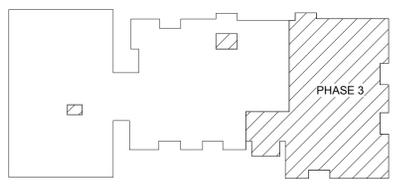

KEYPLAN

NOTES:
REFER TO SHEET M1.1 FOR HVAC NOTES, LEGEND AND SCHEDULES
REFER TO SHEET M2.0 FOR HVAC DEMO PLANS
REFER TO SHEET M2.1 FOR HVAC PLANS.
REFER TO SHEET M3.1 FOR HVAC DETAILS.

HSA HSAEngineering
479 / 452 / 8922 office
7405 Ellis St.
Fort Smith, AR 72916
HSAConsultants.com