


**SC JOHNSON AR - STE 300
RENOVATION**

903 N. 47TH ST. STE 300
ROGERS, AR 72756

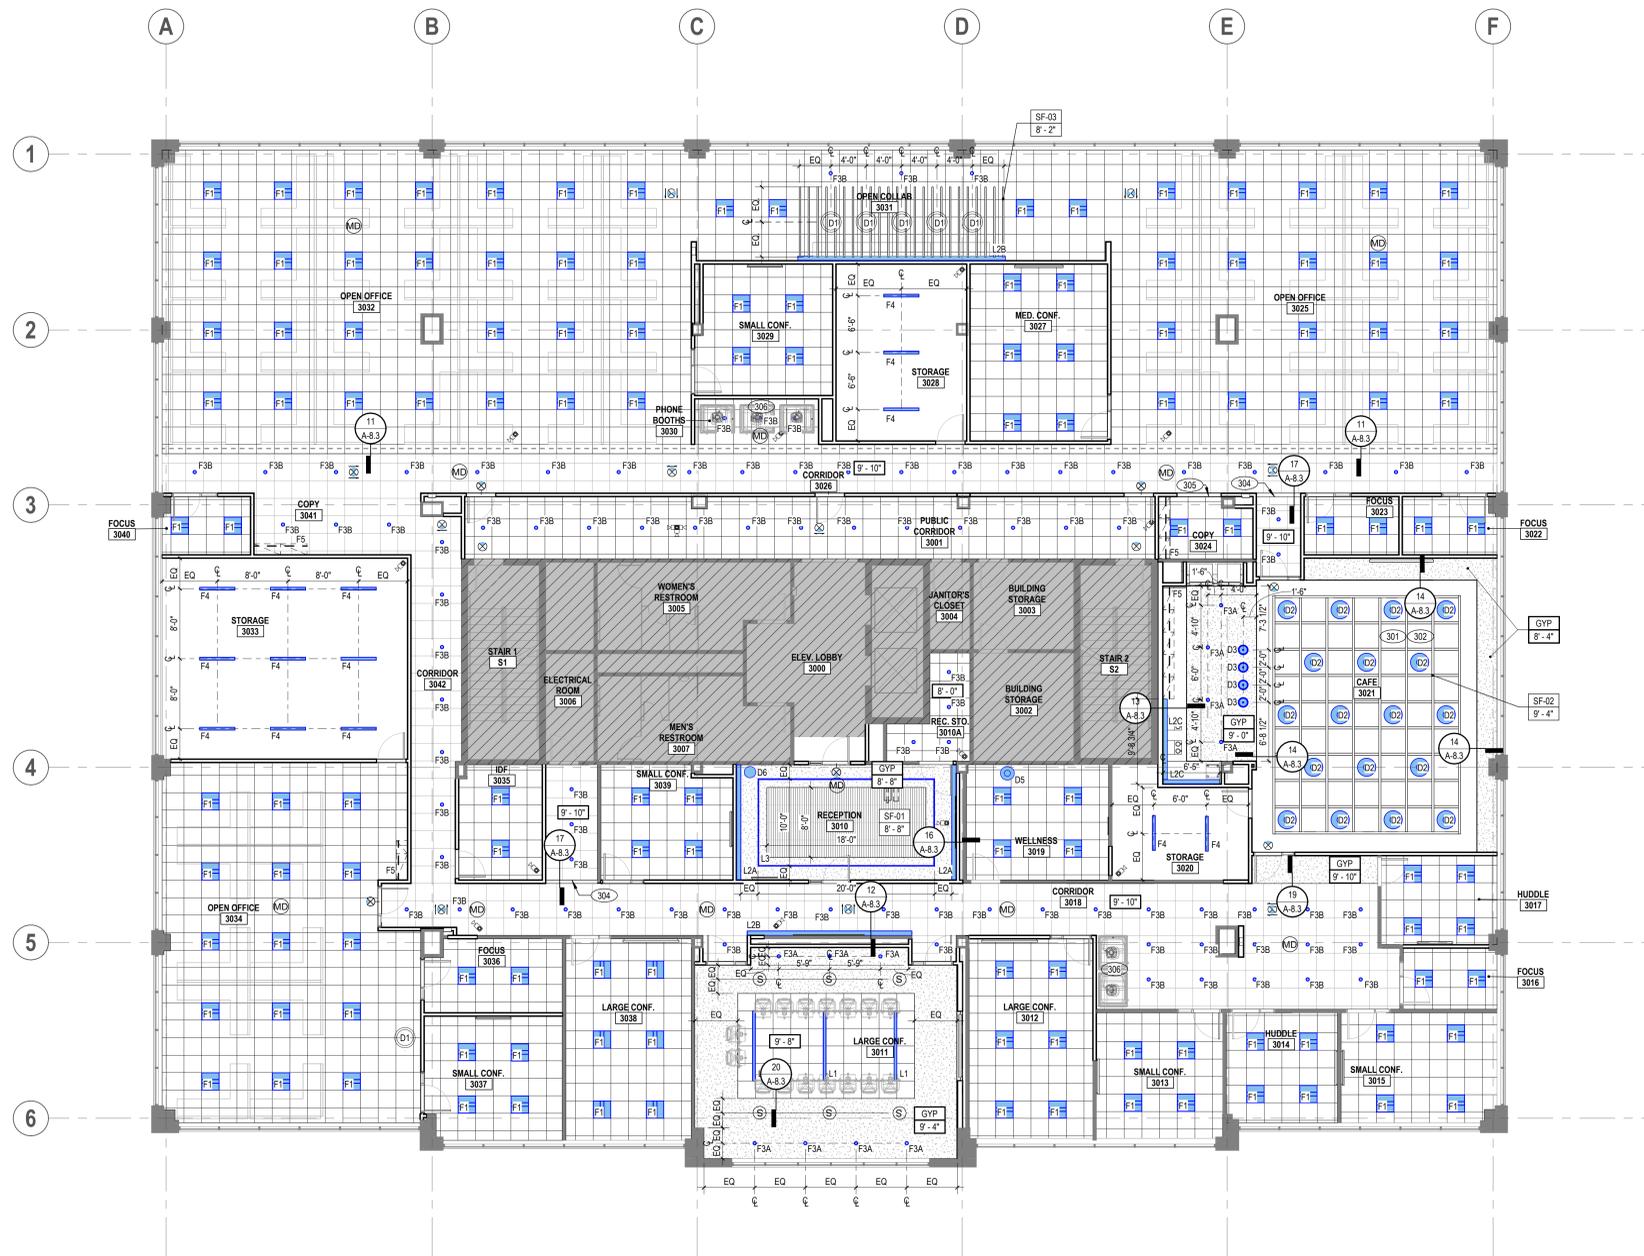

03 RCP
1/8" = 1'-0"



2	5	ISSUE FOR BID & PERMIT	01/07/2026
3		UPDATED IFE	12/08/2025
2		90% CD REVIEW	11/11/2025
1		ISSUE FOR ENGINEERING	10/21/2025

DELTA ISSUE DESCRIPTION DATE



NEW YORK
100 BROADWAY 12th FLOOR
NEW YORK CITY, NY 10005
TEL 212-682-6909

©2025 INTERIOR ARCHITECTS, P.C., A NEW YORK PROFESSIONAL SERVICES CORPORATION. ALL DRAWINGS AND WRITTEN MATERIAL HEREIN CONSTITUTE THE ORIGINAL AND UNPUBLISHED WORK OF THE ARCHITECT AND THE SAME MAY NOT BE REPRODUCED, USED, OR DISCLOSED WITHOUT THE WRITTEN CONSENT OF THE ARCHITECT.

Owner Approval
055CJIS.0037.000
Job No.

1/8" = 1'-0"
Scale

RCP LEGEND

	CEILING MOUNTED ONE SIDED EXIT SIGN		CEILING MOUNTED PENDANT
	CEILING MOUNTED TWO SIDED EXIT SIGN		CEILING MOUNTED SPECIALTY PENDANT
	WALL MOUNTED EXIT SIGN		CEILING MOUNTED WIRELESS NETWORK ROUTER
	LINEAR FLUORESCENT		SUSPENDED DIRECT/INDIRECT LINEAR FLUORESCENT LIGHTING FIXTURE
	LINEAR FLUORESCENT WALL WASHER		RECESSED FLUORESCENT LINEAR FIXTURE TRIMLESS AT GYP BD CEILING
	2X4 FLUORESCENT TROFFER FIXTURE		UNDER CABINET LED FIXTURE
	2X2 FLUORESCENT TROFFER FIXTURE		LED STRIP COVE LIGHTING
	RECESSED DOWNLIGHT		STEM MOUNTED LED SPOT LIGHT
	RECESSED SQUARE DOWNLIGHT		NEW TYP. CEILING GRID AT HIGHER ELEVATION
	RECESSED WALL WASHER		NEW TYP. CEILING GRID
	WALL MOUNTED SCONCE		EXISTING GWB CEILING / SOFFIT
	SECURITY CAMERA - COORDINATE W/ SECURITY VENDOR		NEW GWB CEILING / SOFFIT
	MOTION DETECTOR - COORDINATE W/ SECURITY VENDOR		OPEN TO DECK
	CEILING MOUNTED SPEAKERS - COORDINATE W/ AV VENDOR		

SHEET NOTES

- CONTRACTOR TO VERIFY AS-BUILT FIELD CONDITIONS FOR EXISTING AND COORDINATED NEW LOCATIONS OF PLUMBING, AUDIO VISUAL, HVAC DUCTWORK AND PIPING, STRUCTURAL FRAMING, ELECTRICAL BUS DUCT AND CONDUIT BANKS, ELECTRICAL PULL BOXES, FIRE PROTECTION LINES AND RELATED WORK TO DETERMINE AND COORDINATE BEST CEILING FRAMING, POINTS OF ACCESS AND CLEARANCES AS REQUIRED FOR NEW WORK.
- PROVIDE ACCESS PANELS IN GYP BD CEILINGS WHERE REQUIRED, INCLUDING, BUT NOT LIMITED TO LOCATIONS OF FIRE SMOKE DAMPERS, FIRE LIFE SAFETY J-BOXES, FAN COILS AND VAV BOXES, CONDUIT BANK PULL BOXES, CONTROL AND SHUTOFF VALVES. COORDINATE ALL ACCESS PANEL TYPES, LOCATIONS, AND FINISHES WITH ARCHITECT BEFORE START OF WORK. SEE PROJECT MANUAL.
- CEILING MOUNTED ELECTRICAL DEVICES SHALL BEAR UL-LABEL AND SHALL BE FREE OF DEFECTS IF RE-USED. REPLACE ALL NON-COMPLIANT DEVICES AFFECTING AREA OF WORK.
- AT EXPOSED STRUCTURE AREAS IN STEEL BUILDINGS WITH EXPOSED SPRAY FIREPROOFING, PROVIDE PROTECTIVE OVERSPRAY AT SPRAY FIREPROOFING TO PREVENT DUSTING WHERE PAINT IS SCHEDULED AT EXPOSED CONSTRUCTION. PROVIDE PRIMER/SEALER UNDERCOAT PER MANUFACTURER'S WRITTEN RECOMMENDATIONS.
- CONTRACTOR TO COORDINATE FIRE SPRINKLER AND FIRE ALARM DEVICE LOCATIONS, TYPES AND FINISHES WITH ARCHITECT PRIOR TO SUBMITTING FOR BID & PERMIT. CENTER SPRINKLER HEADS IN CEILING PANEL/TILE WHERE APPLICABLE. ALIGN SPEAKERS, SMOKE DETECTORS, MOTION SENSORS AND RELATED CEILING MOUNTED DEVICES WITH LIGHTING FIXTURE CENTERLINES AND CENTER OF CEILING PANEL/TILE. LOCATE HVAC AIR TERMINALS AND RETURN OPENING IN GYP BD CEILINGS AS SHOWN ON ARCHITECTURAL RCP. PROVIDE CONCEALED FIRE SPRINKLER COVER PLATES AT ALL GYP BD CEILINGS, UNLESS NOTED.
- LOCATE EXIT SIGNS VERTICALLY ABOVE THE FINISH FLOOR TO ENSURE SIGHT LINES ARE NOT BLOCKED BY LIGHT FIXTURES, BEAMS, SOFFITS, DROPPED CEILINGS, DUCTWORK, CONDUIT BANKS, PIPING AND RELATED OVERHEAD WORK. COORDINATE MOUNTING HEIGHT WITH ARCHITECT PRIOR TO START OF WORK.
- SEE FINISH SCHEDULE FOR SPECIFIC PRODUCT FOR ALL ARCHITECTURAL FINISHES, INCLUDING BUT NOT LIMITED TO PAINT, SPRAY APPLIED FINISHES, ACOUSTICAL CEILINGS AND SPECIALTY CEILINGS.
- CONTRACTOR TO COORDINATE COLOR SELECTION FOR ALL VISIBLE CEILING DEVICES WITH ARCHITECT BEFORE START OF WORK, INCLUDING, BUT NOT LIMITED TO COVER PLATES FOR LIGHTING CONTROL DEVICES, SENSORS, FIRE ALARM DEVICES, SPRINKLER ESCUTCHIONS, CONDUIT, AND ACCESS PANELS. COLOR TO MATCH SPECIFIED CEILING FINISH UNLESS NOTED.
- ALL CEILING HEIGHT DIMENSIONS PROVIDED ARE ABOVE FINISHED FLOOR UNLESS NOTED.
- TYPICAL CEILING HEIGHT IS 9'-4" AFF. UNLESS NOTED.
- ALL GYPSUM BOARD CEILINGS AND SOFFITS TO BE PAINTED PA-01, UNLESS NOTED.
- SUSPENDED CEILINGS TO BE CS-01, UNLESS NOTED.

KEYNOTES

NO.	DESCRIPTION
301	COORDINATE LIGHTING WITH SPECIALTY CEILING.
302	LIGHTING TO BE CENTERED IN SPECIALTY CEILING GRID.
304	ALTERNATE BID: REMOVE GYPSUM BULKHEAD TRANSITION AND ADJUST CEILING GRID TO ACCOMMODATE TRANSITION BETWEEN BOTH ACT CEILINGS.
305	OPENING HEADER TO ALIGN WITH DOOR OPENINGS
306	SPRINKLER HEADS TO BE PROVIDED IN CLOSELY SPACED PHONE BOOTHS.

REFLECTED CEILING PLAN

A-3.0