

GENERAL MECHANICAL POWER NOTES

1. ALL HVAC EQUIPMENT IS EXISTING TO REMAIN, TYPICAL OF ALL UNLESS OTHERWISE NOTED.

KEYED MECHANICAL POWER NOTES


① NEW LOCATION FOR RELOCATED MINI SPLIT, INTERCEPT AND EXTEND EXISTING CONDUITS TO NEW LOCATION. REFER TO THE HVAC DRAWING FOR EXISTING LOCATION.

**SC JOHNSON AR - STE 300
RENOVATION**

903 N. 47TH ST. STE 300
ROGERS, AR 72756



01/07/2026

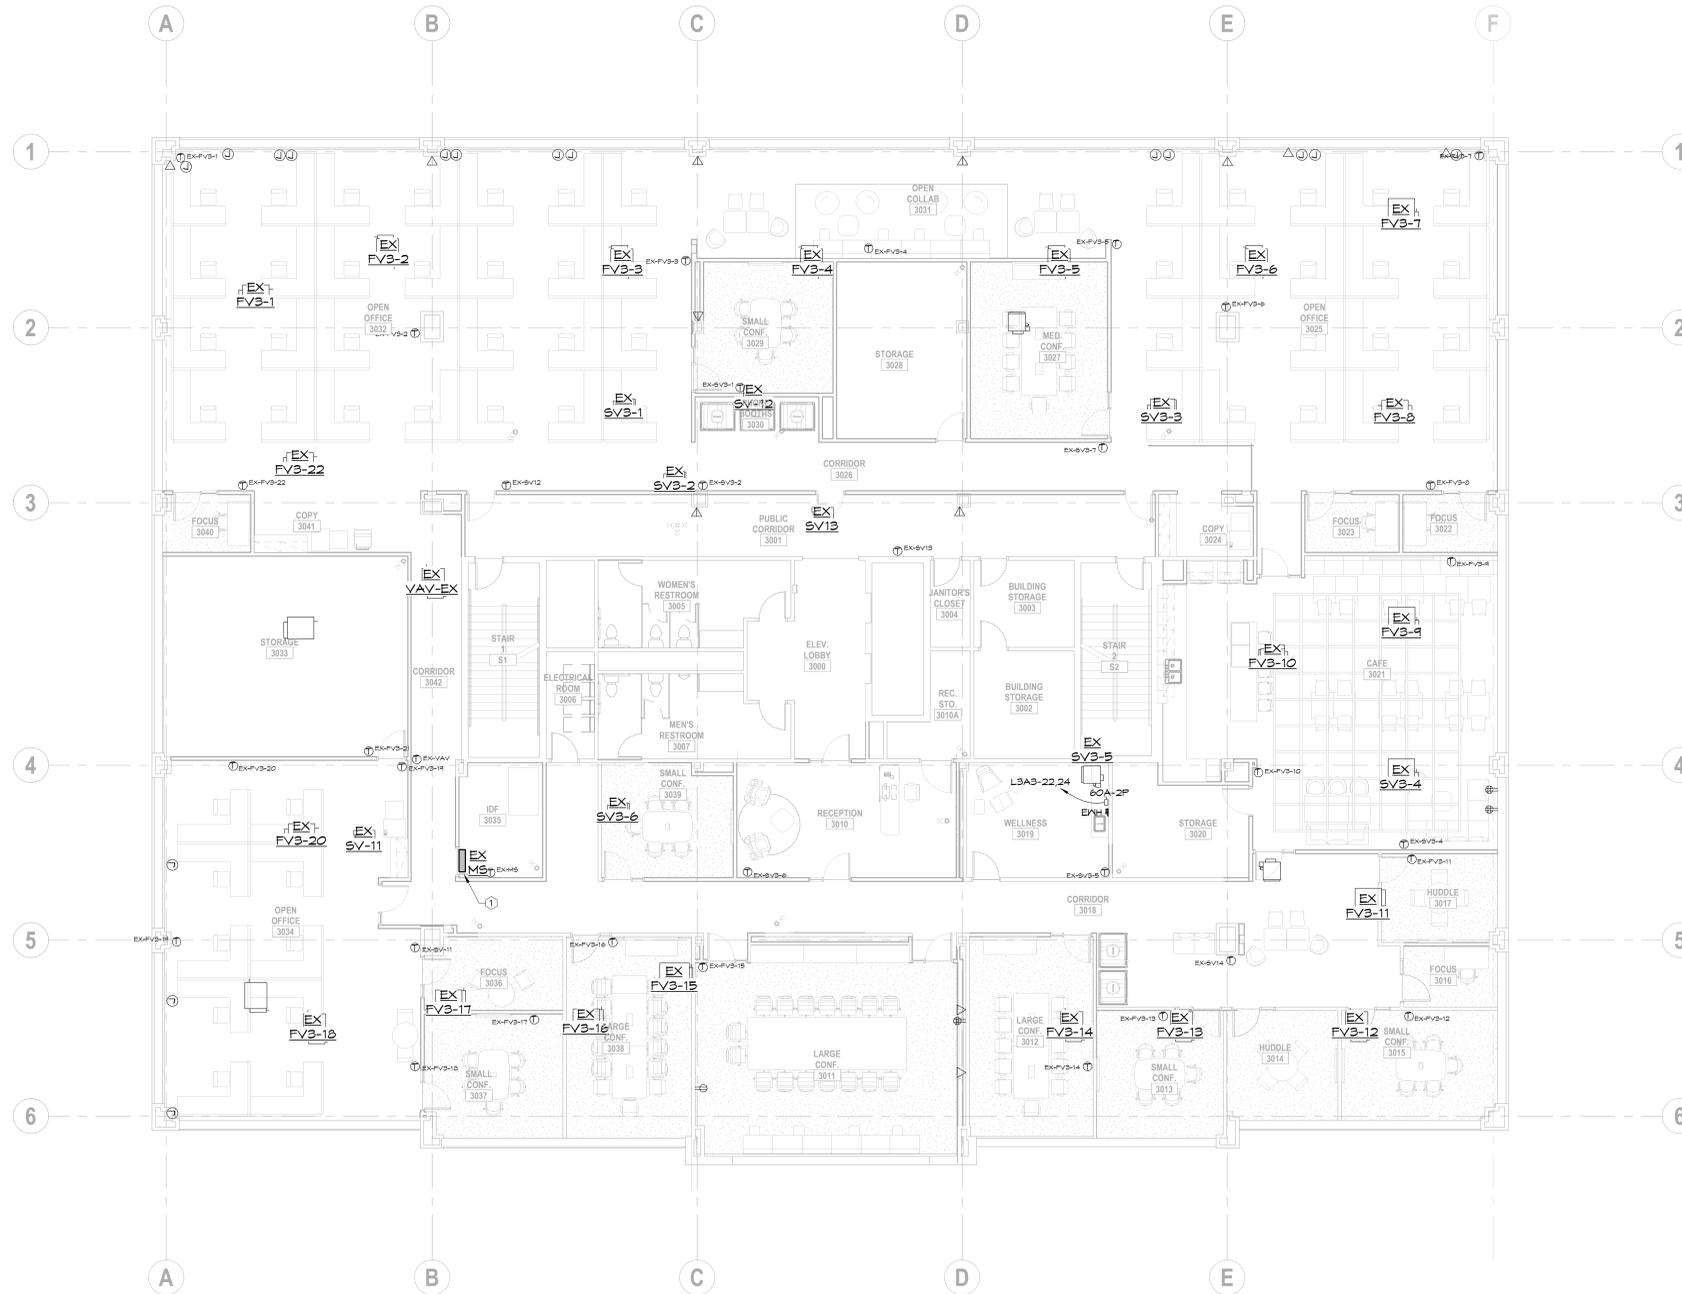

① MECHANICAL POWER PLAN
1/8" = 1'-0"



HSA Engineering
501 / 327 / 5757 office
515 Locust Avenue
Conway, Arkansas 72034
HSAConsultants.com

**MECHANICAL POWER
PLAN
E2.3**

DELTA	ISSUE	DESCRIPTION	DATE

IA INTERIOR ARCHITECTS

NEW YORK
100 BROADWAY 12th FLOOR
NEW YORK CITY, NY 10005
TEL 212-682-6909

©2025 INTERIOR ARCHITECTS, P.C. A NEW YORK PROFESSIONAL SERVICES CORPORATION.
ALL DRAWINGS AND WRITTEN MATERIALS HEREIN CONSTITUTE THE ORIGINAL AND UNPUBLISHED WORK
OF THE ARCHITECT, AND THE SAME MAY NOT BE DUPLICATED, USED, OR DISCLOSED WITHOUT THE
WRITTEN CONSENT OF THE ARCHITECT.

Owner Approval _____
05SCJS.0037.000 1/8" = 1'-0"
Job No. Scale