

**SC JOHNSON AR - STE 300
RENOVATION**

903 N. 47TH ST. STE 300
ROGERS, AR 72756



01/07/2026

DELTA	ISSUE	DESCRIPTION	DATE

IA INTERIOR ARCHITECTS

NEW YORK
100 BROADWAY 12th FLOOR
NEW YORK CITY, NY 10005
TEL 212-682-6909

©2025 INTERIOR ARCHITECTS, P.C., A NEW YORK PROFESSIONAL SERVICES CORPORATION.
ALL DRAWINGS AND WRITTEN MATERIALS HEREIN CONSTITUTE THE ORIGINAL AND UNPUBLISHED WORK
OF THE ARCHITECT, AND THE SAME MAY NOT BE DUPLICATED, USED, OR DISCLOSED WITHOUT THE
WRITTEN CONSENT OF THE ARCHITECT.

Owner Approval _____
05SCJS.0037.000 1/8" = 1'-0"
Job No. _____ Scale _____


SPECIAL SYSTEMS PLAN
E2.4

GENERAL SPECIAL SYSTEMS NOTES

1. REFER TO THE AV DRAWINGS FOR ALL INFRASTRUCTURE REQUIREMENTS, INCLUDING JUNCTION BOX SIZES, CONDUIT SIZES, MOUNTING HEIGHTS, ETC. AT THE NFB (WALL BOX) DETAILS/ELEVATIONS, ETC. POWER CONDUITS ARE NOT SHOWN. ALL POWER CONDUITS SHALL BE BY THE ELECTRICAL CONTRACTOR AS REQUIRED. MINIMUM 3/4" C.
2. REFER TO THE ARCHITECTURAL DRAWINGS FOR ALL INFRASTRUCTURE REQUIREMENTS, INCLUDING ALL DEVICE LOCATIONS, SIZES, MOUNTING HEIGHTS, ETC.
3. REFER TO ARCHITECTURAL DRAWINGS FOR ALL FULL HEIGHT PARTITIONS THAT GO TO THE DECK. PROVIDE SLEEVES AT THESE LOCATIONS.
4. FLOOR MOUNTED CONNECTRAC SURFACE RACEWAY SYSTEM FURNISHED BY AV INSTALLER. POWER CONDUITS TO UNDER THE TABLE SHALL BE ROUTED IN THIS SURFACE RACEWAYS. TYPICAL.
5. REFER TO DRAWING AN5.0 FOR A PARTIAL RESPONSIBILITY MATRIX.
6. ELECTRICAL CONTRACTOR SHALL CONTRACT WITH THE LANDLORD'S PREFERRED FIRE ALARM VENDOR. ALL NEW FIRE ALARM DEVICES SHALL CONNECT TO THE EXISTING LANDLORD FIRE ALARM SYSTEM. VERIFY IN THE FIELD MANUFACTURER AND LOCATION OF CONTROL PANEL.

KEYED SPECIAL SYSTEMS NOTES

- 1 APPROXIMATE LOCATION OF SPEAKERS FURNISHED AND INSTALLED BY THE AV INSTALLER. ELECTRICAL CONTRACTOR SHALL PROVIDE EMPTY CONDUIT WITH PULLSTRING FROM SPEAKER TO SPEAKER. COORDINATE CONDUIT SIZE WITH THE AV INSTALLER. REFER TO AV412.1. TYPICAL.
- 2 PROVIDE EMPTY CONDUIT WITH PULLSTRING AND ROUTE CONDUIT BACK TO THE AV RACK AT IDF 3035. COORDINATE CONDUIT SIZE WITH THE AV INSTALLER.
- 3 PROVIDE PUSHBUTTON FOR DOOR RELEASE. PROVIDE EMPTY CONDUIT TO DOOR TO BE CONTROLLED. COORDINATE WITH THE ARCHITECT AND OWNER FOR DOORS TO BE CONTROLLED.
- 4 FOR ROOM SCHEDULER, PSE, FURNISHED BY OTHERS. ELECTRICAL CONTRACTOR SHALL PROVIDE EMPTY 3/4" CONDUIT WITH PULLSTRING TO NEAREST ACCESSIBLE LAY-IN CEILING. REFER TO AV412.2. TYPICAL.
- 5 FOR CEILING MOUNTED MICROPHONE. ELECTRICAL CONTRACTOR SHALL PROVIDE EMPTY 3/4" CONDUIT WITH PULLSTRING FOR EACH, TO NEAREST ACCESSIBLE LAY-IN CEILING. REFER TO AV412.1. TYPICAL.
- 6 PRE-ACTION FIRE SUPPRESSION SYSTEM TO BE INSTALLED IN IDF ROOM. ELECTRICAL CONTRACTOR IS RESPONSIBLE FOR INTERCONNECTION WITH THE EXISTING FIRE ALARM SYSTEM.

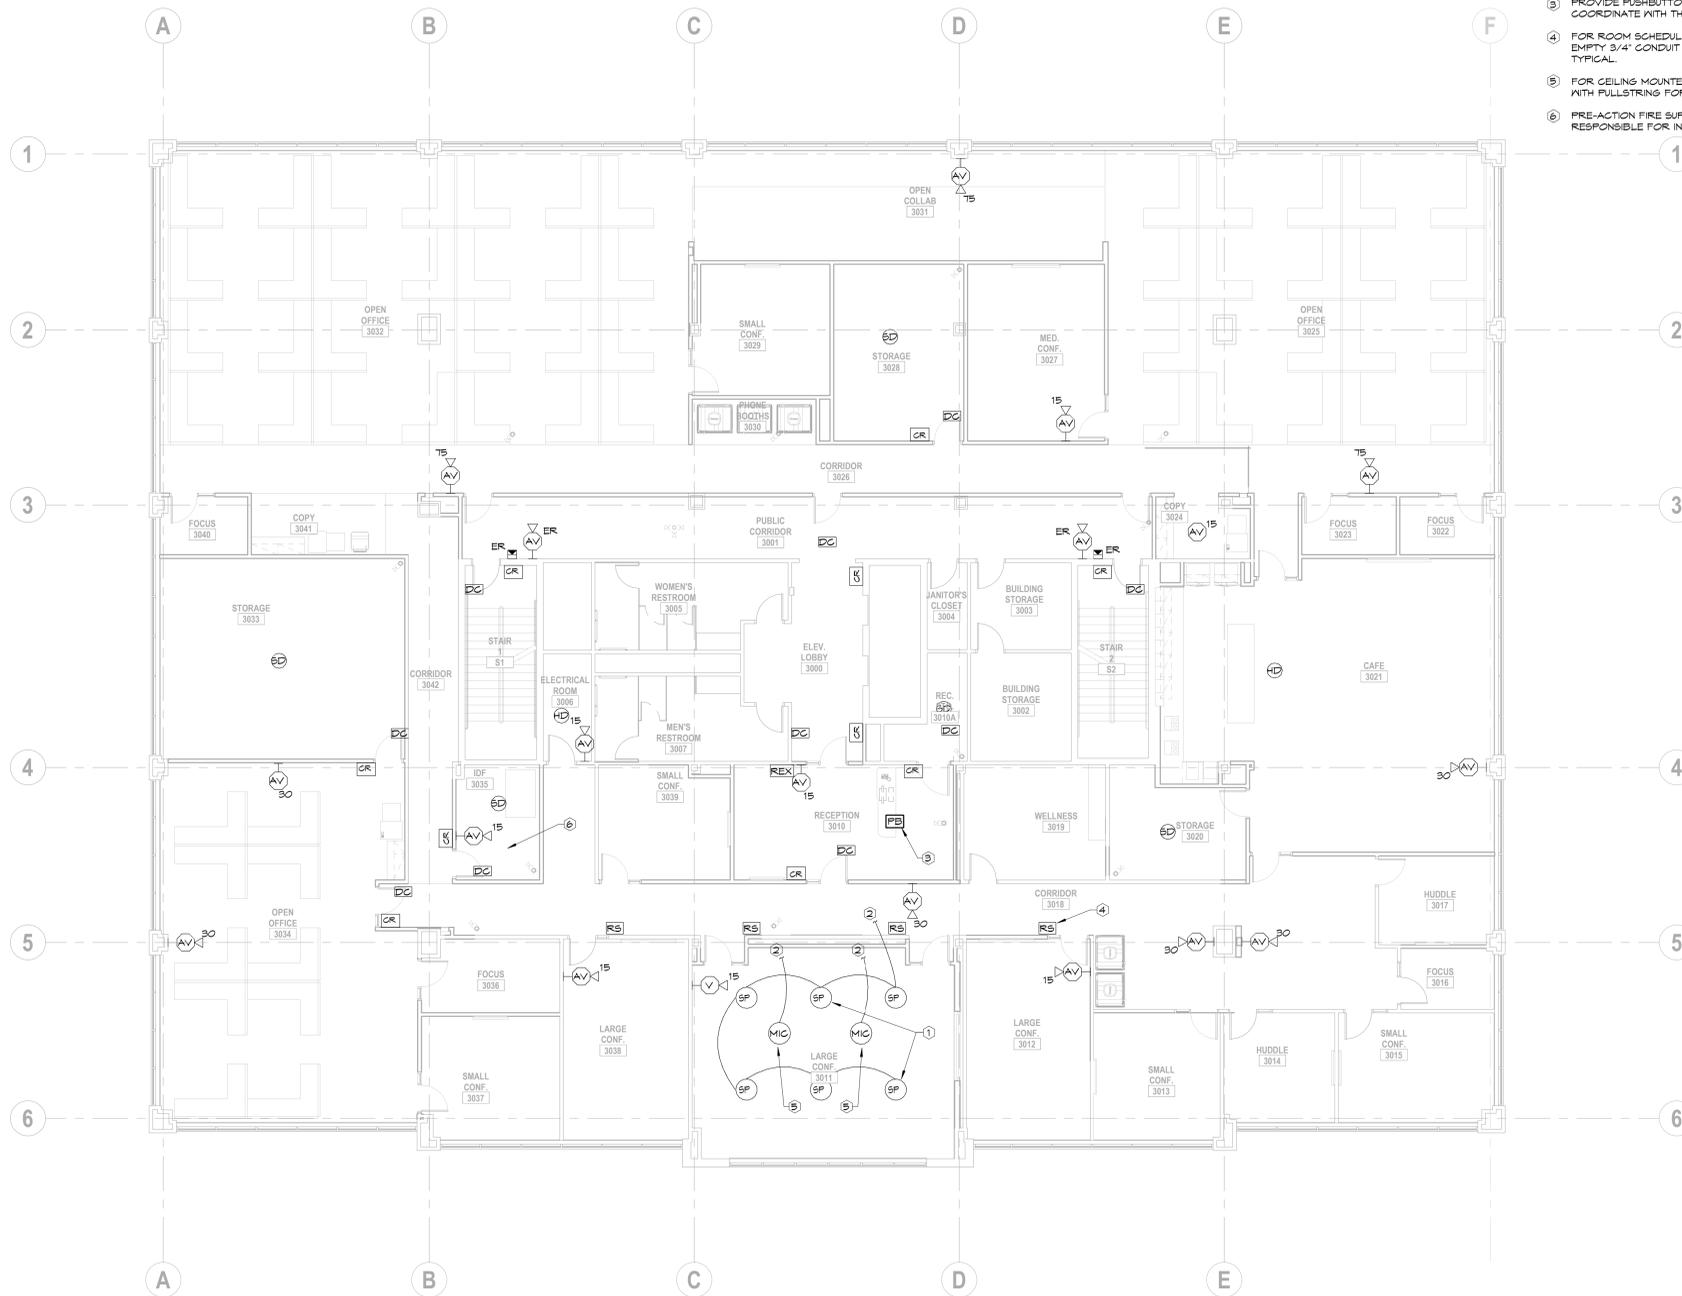

1 SPECIAL SYSTEMS PLAN
1/8" = 1'-0"



HSA Engineering
501 / 327 / 5757 office
515 Locust Avenue
Conway, Arkansas 72034
HSAConsultants.com

HSA JOB #25-178