


**SC JOHNSON AR - STE 300
RENOVATION**

903 N. 47TH ST. STE 300
ROGERS, AR 72756

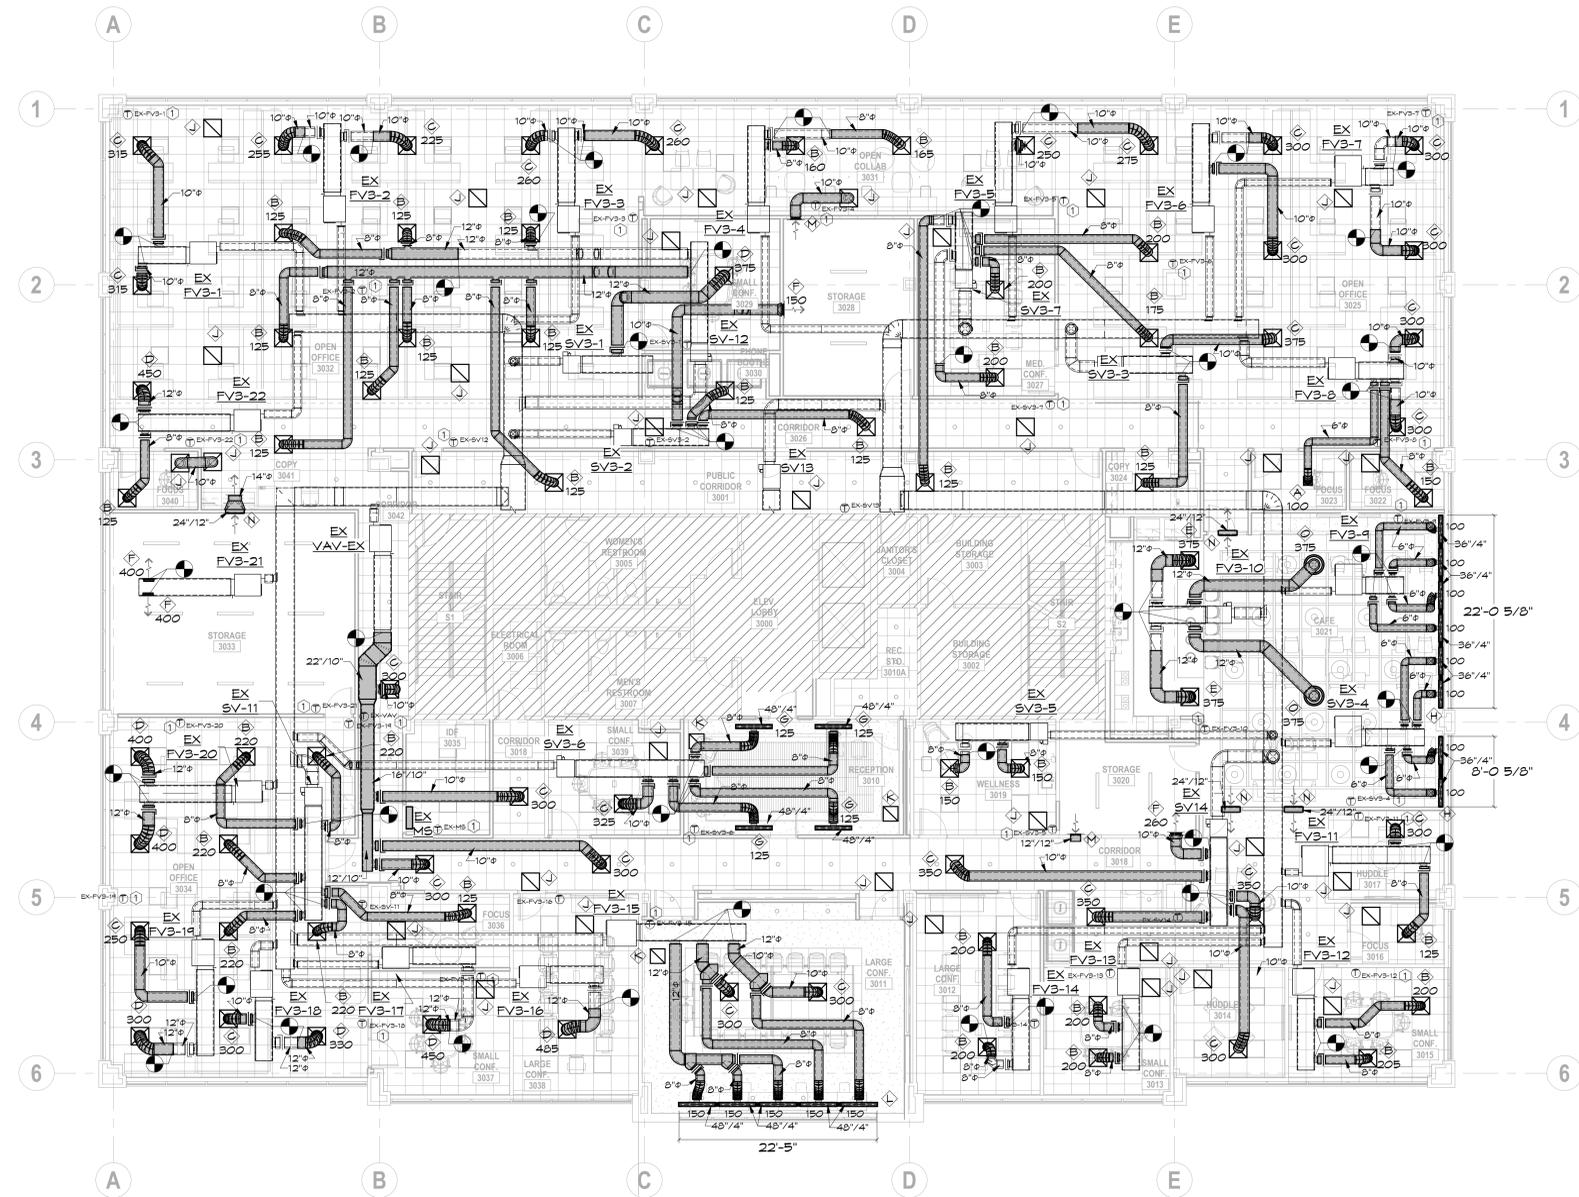

1 HVAC PLAN
1/8" = 1'-0"



NOTES:
REFER TO SHEET M1.1 FOR HVAC LEGEND, SCHEDULE, DETAILS, GENERAL AND KEYED NOTES.
REFER TO SHEETS M2.1 FOR HVAC PLANS.
REFER TO SHEETS MD2.1 FOR HVAC DEMOLITION PLANS.

HSA Engineering
501 / 327 / 5757 office
515 Locust Avenue
Conway, Arkansas 72034
HSAConsultants.com

DELTA	ISSUE	DESCRIPTION	DATE



NEW YORK
100 BROADWAY 12th FLOOR
NEW YORK CITY, NY 10005
TEL 212-682-6909

©2025 INTERIOR ARCHITECTS, P.C. A NEW YORK PROFESSIONAL SERVICES CORPORATION.
ALL DRAWINGS AND WRITTEN MATERIALS HEREIN CONSTITUTE THE ORIGINAL AND UNPUBLISHED WORK
OF THE ARCHITECT, AND THE SAME MAY NOT BE REPRODUCED, COPIED, OR DISCLOSED WITHOUT THE
WRITTEN CONSENT OF THE ARCHITECT.

Owner Approval _____
05SCJS.0037.000 1/8" = 1'-0"
Job No. Scale

**HVAC PLAN
M2.1**