


**SC JOHNSON AR - STE 300  
RENOVATION**

903 N. 47TH ST. STE 300  
ROGERS, AR 72756

**NOT FOR  
CONSTRUCTION**

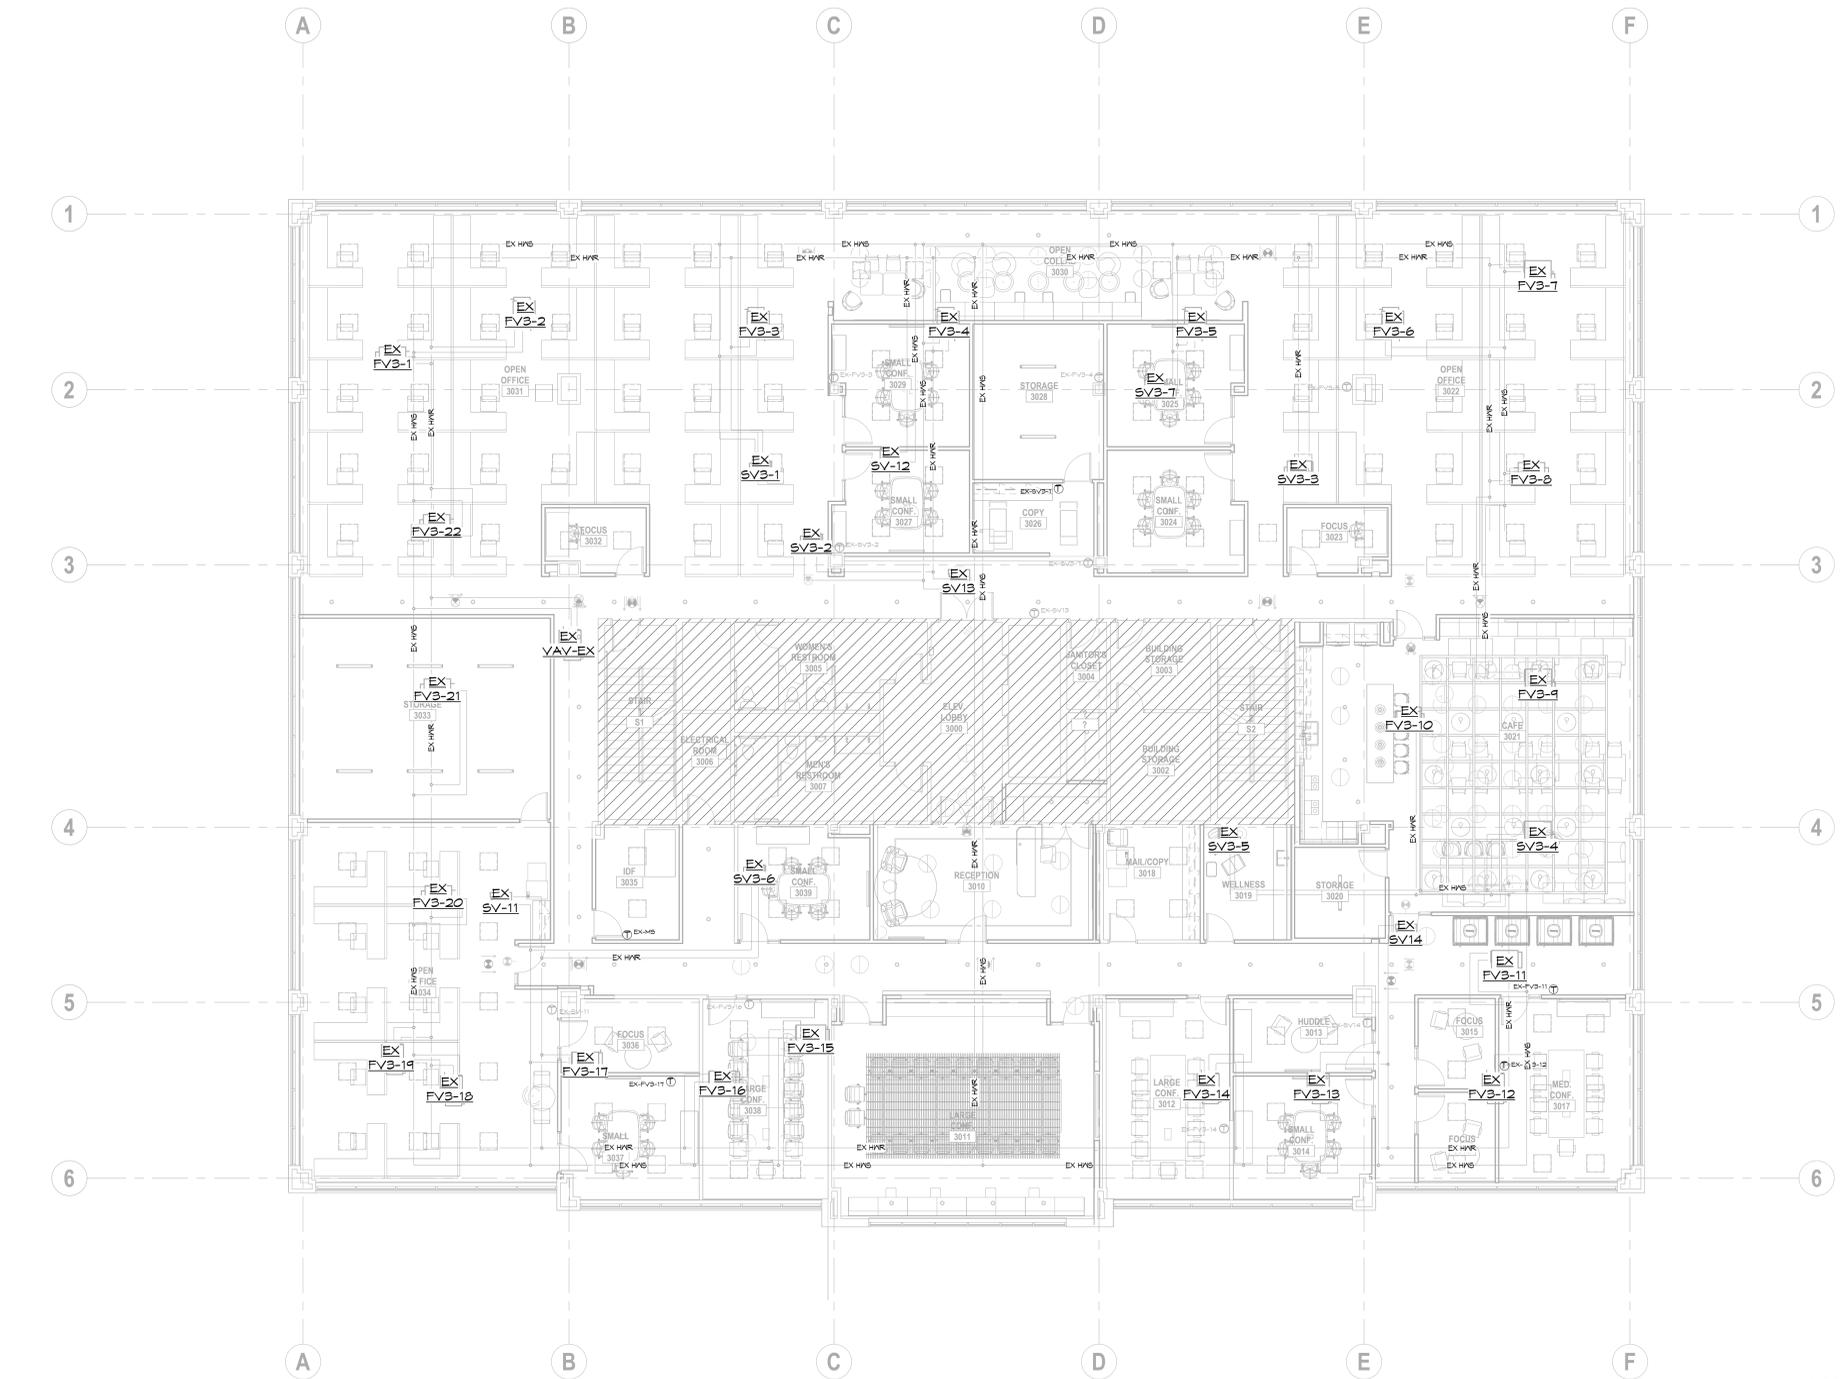

**1 MECHANICAL PIPING PLAN**  
1/8" = 1'-0"



DELTA	ISSUE	DESCRIPTION	DATE

**IA** INTERIOR ARCHITECTS

**NEW YORK**  
100 BROADWAY 12th FLOOR  
NEW YORK CITY, NY 10005  
TEL 212-682-6909

©2025 INTERIOR ARCHITECTS, P.C., A NEW YORK PROFESSIONAL SERVICES CORPORATION.  
ALL DRAWINGS AND WRITTEN MATERIALS HEREIN CONSTITUTE THE ORIGINAL AND UNPUBLISHED WORK  
OF THE ARCHITECT, AND THE SAME MAY NOT BE DUPLICATED, USED, OR DISCLOSED WITHOUT THE  
WRITTEN CONSENT OF THE ARCHITECT.

Owner Approval \_\_\_\_\_  
05SCJIS.0037.000 1/8" = 1'-0"  
Job No. Scale

**HSA** HSAEngineering  
501 / 327 / 5757 office  
515 Locust Avenue  
Conway, Arkansas 72034  
HSAConsultants.com

**MECHANICAL PIPING PLAN  
M2.2**

**NOTES:**  
REFER TO SHEET M1.1 FOR HVAC LEGEND, GENERAL AND KEYED NOTES.  
REFER TO SHEET M3.1 FOR HVAC DETAILS. REFER TO SHEET M5.1 FOR HVAC SCHEDULES.