
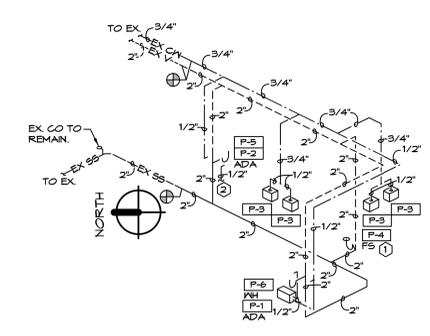


**PLUMBING KEYED NOTES**

- 1 INSTALL AN APPROVED TRAP GUARD PRODUCT THAT CONFORMS TO NSF-14, CSA B602-89 AND CSA B711-84.
- 2 CONNECT NEW STAINLESS STEEL SINK (P-2) TO THE EXISTING HOT WATER FROM THE DEMOED EXISTING STAINLESS SINK. COORDINATE ALL REPAIRS WITH GENERAL CONTRACTOR.

**SC JOHNSON AR - STE 300  
RENOVATION**

**903 N. 47TH ST. STE 300  
ROGERS, AR 72756**

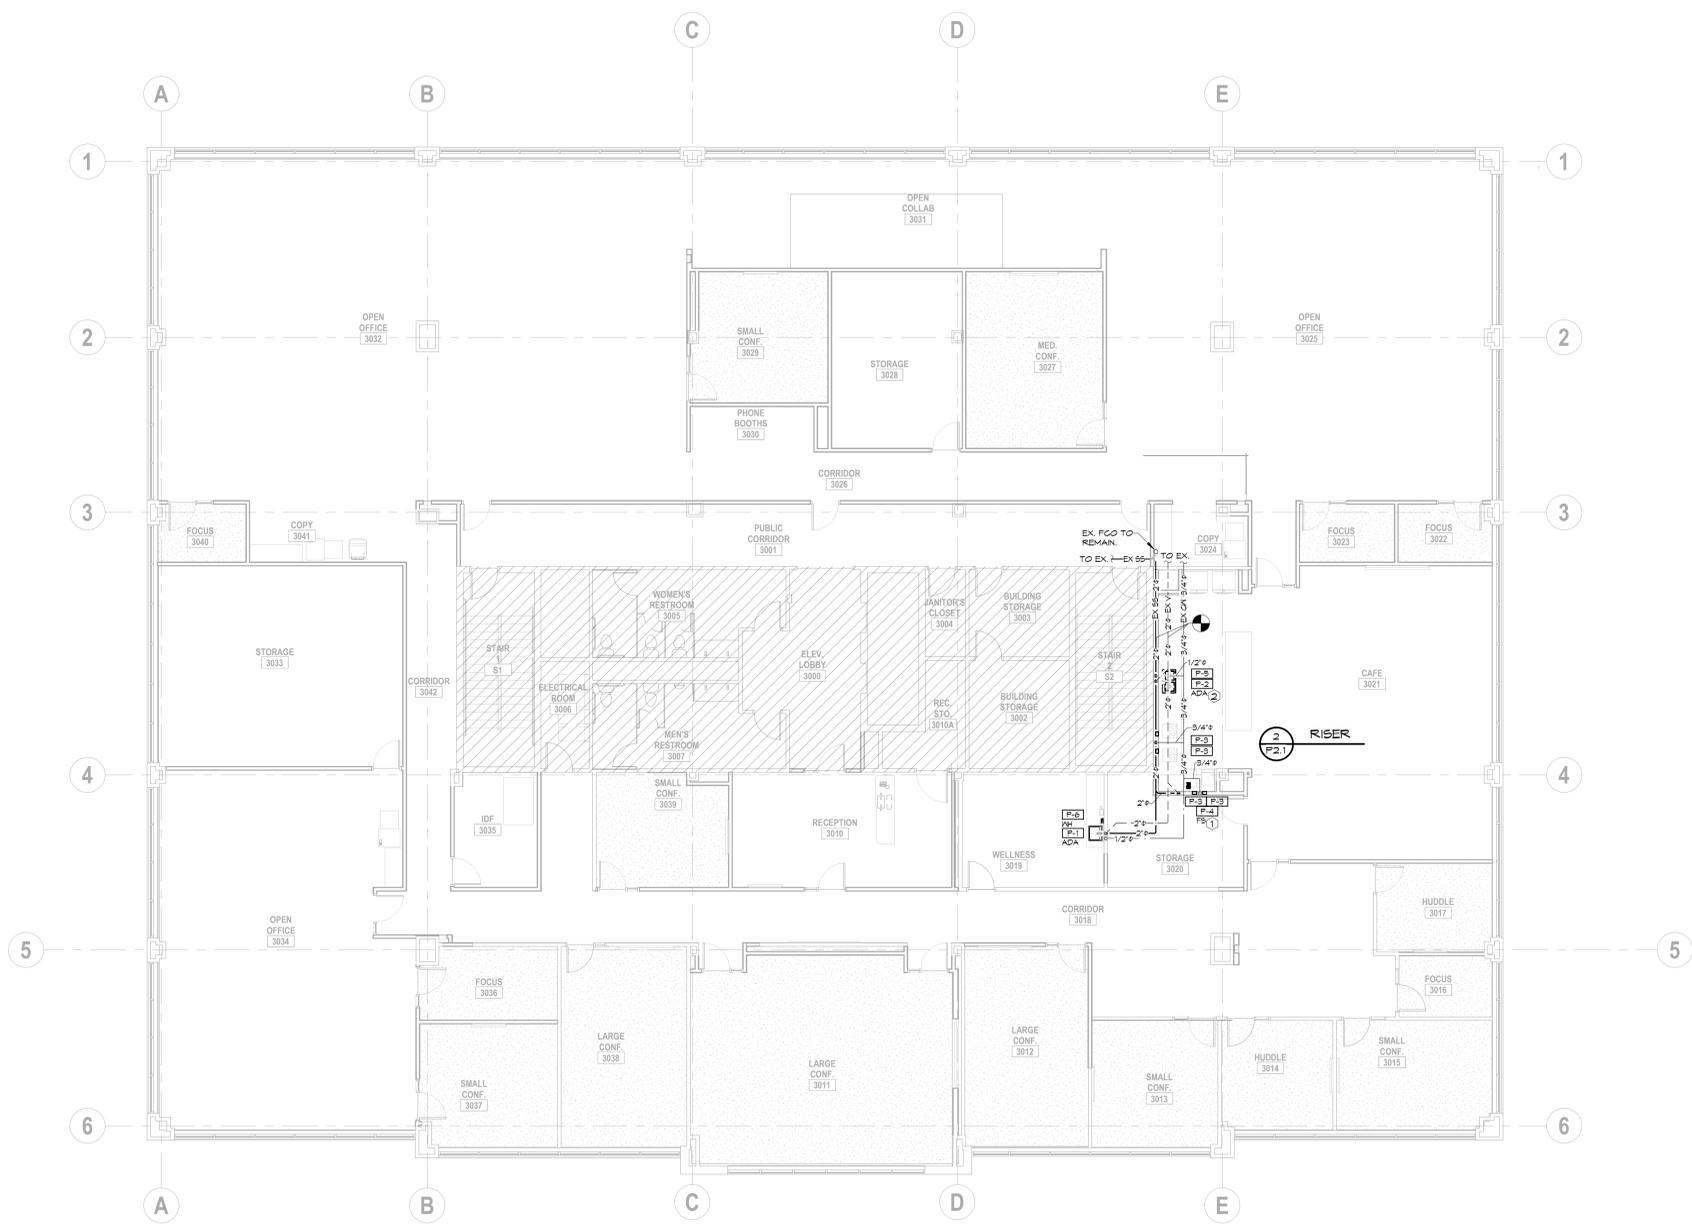

**2** RISER  
NTS

**1** PLUMBING PLAN  
1/8" = 1'-0"

DELTA	ISSUE	DESCRIPTION	DATE

**IA** INTERIOR ARCHITECTS

**NEW YORK**  
100 BROADWAY 12th FLOOR  
NEW YORK CITY, NY 10005  
TEL 212-682-6909

©2025 INTERIOR ARCHITECTS, P.C. A NEW YORK PROFESSIONAL SERVICES CORPORATION.  
ALL DRAWINGS AND WRITTEN MATERIALS HEREIN CONSTITUTE THE ORIGINAL AND UNPUBLISHED WORK  
OF THE ARCHITECT AND THE SAME MAY NOT BE DUPLICATED, USED, OR DISCLOSED WITHOUT THE  
WRITTEN CONSENT OF THE ARCHITECT.

Owner Approval	NTS
05SCJIS.0037.000	Scale
Job No.	

**HSA** Engineering  
501 / 327 / 5757 office  
515 Locust Avenue  
Conway, Arkansas 72034  
HSAConsultants.com

**PLUMBING PLAN. RISER &  
KEYED NOTES**  
**P2.1**