

NOT FOR CONSTRUCTION


CORPORATE SEAL

ENGINEER SEAL


CLINTON SUSTAINABLE ENERGY DISTRICT - PACKAGE 2
CLINTON FOUNDATION
1200 PRESIDENT CLINTON AVE LITTLE ROCK, ARKANSAS

KEYED NOTES:


- ① RETROFIT EXISTING COOLING TOWER HOT WATER BASIN DISTRIBUTION NOZZLES AND CUPS FOR HIGH TURNDOWN.

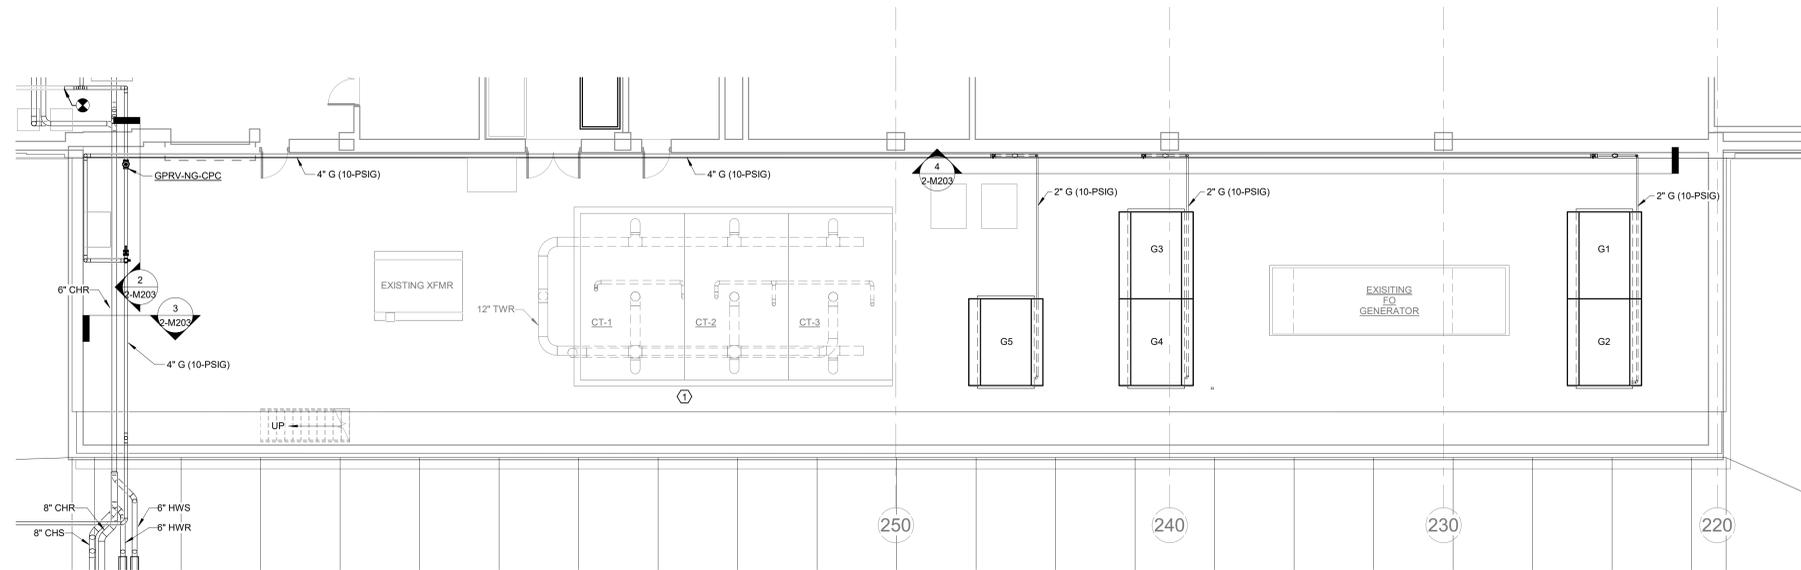


① **WILLIAM J. CLINTON CENTRAL UTILITY PLANT - TOWER YARD PLAN - MECHANICAL** $\frac{1}{8"} = 1'-0"$

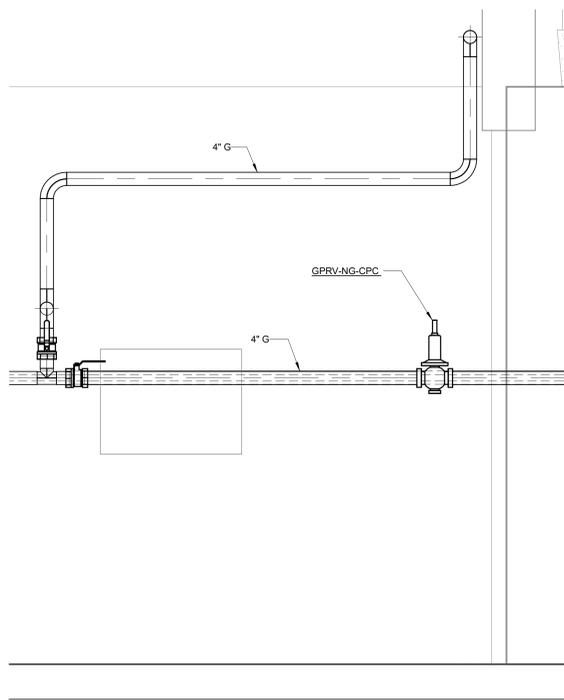


② **WILLIAM J. CLINTON - TOWER YARD - NG PRV - SECTION VIEW** $\frac{1}{2"} = 1'-0"$

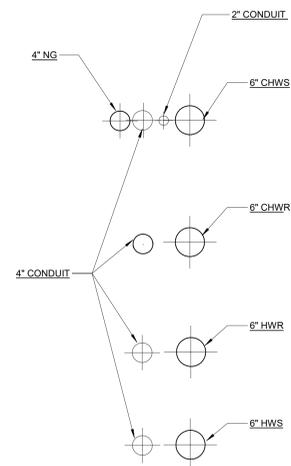

③ **WILLIAM J. CLINTON UTILITY PLANT - TOWER YARD - STRUCTURAL FRAM PIPE LAYOUT - SECTION VIEW** $\frac{3}{4"} = 1'-0"$

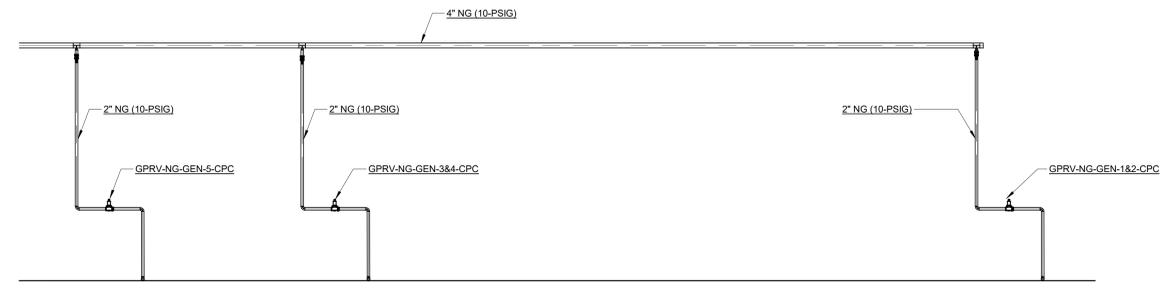

④ **WILLIAM J. CLINTON UTILITY PLANT - TOWER YARD - NATURAL GAS - SECTION VII** $\frac{3}{16"} = 1'-0"$

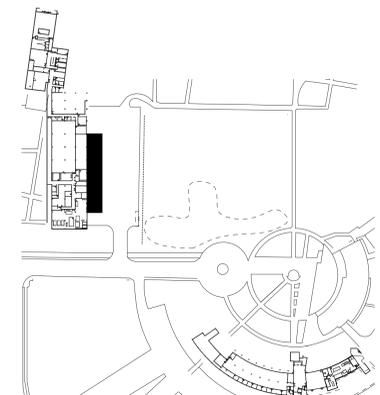

MARK	DATE	DESCRIPTION
ISSUE DATE:	11-20-2025	
PROJECT NUMBER:	561470540	
SHEET TITLE:		
WILLIAM J. CLINTON, CENTRAL UTILITY PLANT - TOWER YARD PLAN - MECHANICAL		

SHEET NUMBER:

M203