

**WILLIAM J. CLINTON
PRESIDENTIAL
CENTER**

LITTLE ROCK, ARKANSAS

Architect

POLSHEK PARTNERSHIP LLP
320 West 13th Street
New York, New York 10014
212.807.7171

Coordinating Architects

POLK STANLEY YEARY ARCHITECTS Ltd
700 South Schiller Street
Little Rock, Arkansas 72201
501.378.0878

WITSELL EVANS RASCO
901 West Third Street
Little Rock, Arkansas 72201
501.374.5300

WOODS CARADINE ARCHITECTS
2200 South Main Street
Little Rock, Arkansas 72206
501.374.4060

Landscape Architects

HARGREAVES ASSOCIATES
118 Magazine Street
Cambridge, Massachusetts 02139
617.661.0070

LANDSCAPE ARCHITECTURE, Inc.
2300 Cottondale Lane Suite 202
Little Rock, Arkansas 72202
501.374.5810

Structural Engineer

LESLIE E. ROBERTSON ASSOC., RLLP
30 Broad Street, 47th Floor
New York, New York 10004
212.750.9000

MEP Engineers

FLACK + KURTZ, Inc.
475 Fifth Avenue
New York, New York 10017
212.532.9600

CROMMELL ARCHITECTS ENGINEERS


101 South Spring Street
Little Rock, Arkansas 72201
501.372.2900

Curtainwall Consultant

R. A. HEINTGES ARCHITECTS
126 Fifth Avenue, 9th Floor
New York, New York 10011
212.652-2968

Seal

100% Construction Documents	09/27/02
90% Progress Printing	08/30/02
100% Struct./ CD Progress	07/01/02
Bridge Bldg. Substructure	06/14/02
100% Steel & Concrete CD	05/15/02
& Architectural CD Progress	
100% Design Development	03/01/02
Issue	Date

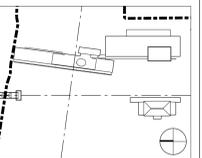


Job No.	9908
Scale	1:80
Date	September 27, 2002
Title	

SITE PLAN

Sheet No.

A002

FOR SITE INFORMATION REFER TO HARGREAVES ASSOCIATES' CONSTRUCTION DOCUMENTS PACKAGE ISSUED SEPTEMBER 27, 2002
FOR PROJECT SURVEY REFER TO DRAWINGS V102-V105 IN HARGREAVES ASSOCIATES' CONSTRUCTION DOCUMENTS PACKAGE ISSUED SEPTEMBER 27, 2002
FOR UTILITY RELOCATION REFER TO MOLELLAN CONSULTING ENGINEERS DUCT BANK CONSTRUCTION DRAWINGS ISSUED DECEMBER 2001, REVISED JANUARY 10, 2002
FOR BUILDING LOCATION WORKPOINTS REFER TO SLAB PLAN S100b.1 AND S101b.1

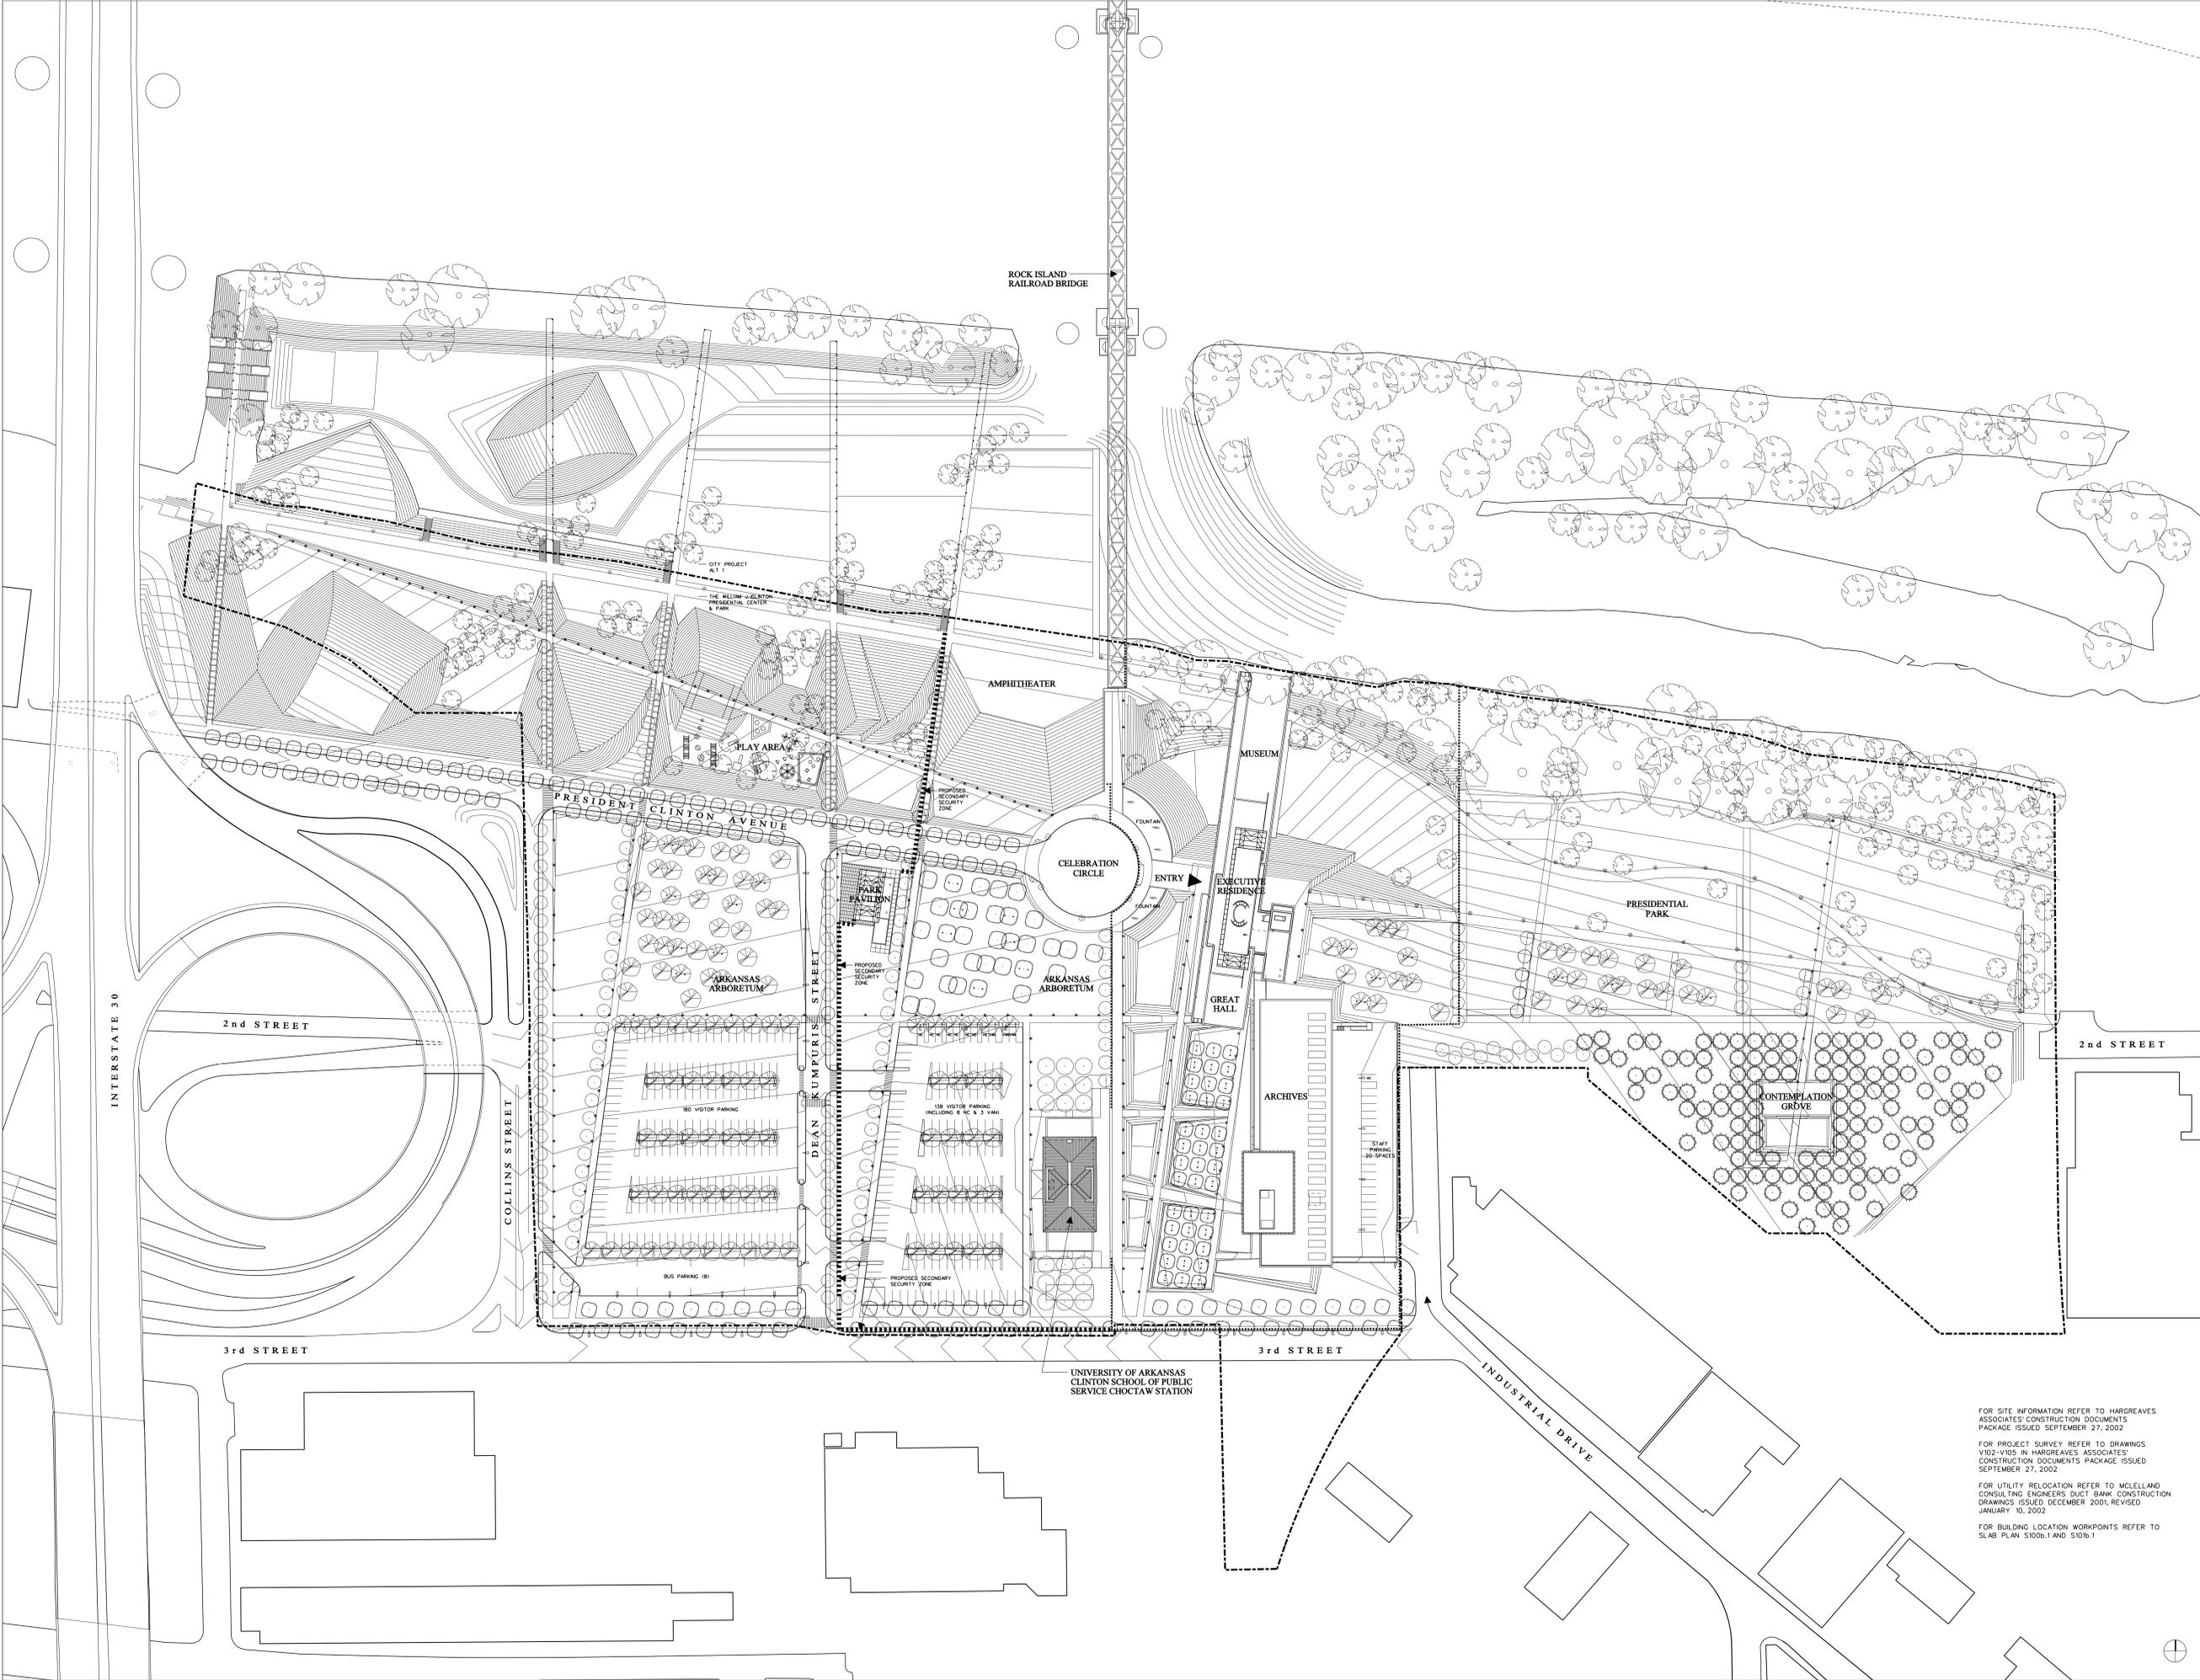

FOR OFFICIAL USE ONLY