

**WILLIAM J. CLINTON
PRESIDENTIAL
CENTER**

LITTLE ROCK, ARKANSAS

Architect
POLSHKE PARTNERSHIP LLP
320 West 13th Street
New York, New York 10014
212.807.7171

Coordinating Architects
POLK STANLEY YEARY ARCHITECTS LTD
700 South Schiller Street
Little Rock, Arkansas 72201
501.378.0878

WITSELL EVANS RASCO
901 West Third Street
Little Rock, Arkansas 72201
501.374.5300

WOODS CARADINE ARCHITECTS
2200 South Main Street
Little Rock, Arkansas 72206
501.374.4960

Landscape Architects
HARGREAVES ASSOCIATES
118 Magazine Street
Cambridge, Massachusetts 02139
617.661.0070

LANDSCAPE ARCHITECTURE, Inc.
2300 Cottondale Lane Suite 202
Little Rock, Arkansas 72202
501.374.5810

Structural Engineer
LESLIE E. ROBERTSON ASSOC., RLLP
30 Broad Street, 47th Floor
New York, New York 10004
212.750.9000


MEP Engineers
FLACK + KURTZ, Inc.
475 Fifth Avenue
New York, New York 10017
212.532.9600

CROMWELL ARCHITECTS ENGINEERS
101 South Spring Street
Little Rock, Arkansas 72201
501.372.2900

Curtainwall Consultant
R. A. HEINTGES ARCHITECTS
126 Fifth Avenue, 9th Floor
New York, New York 10011
212.652.2968

Seal

ASI #32	04/09/04
ASI #29	03/05/04
ASI #25	12/19/03
ASI #24	10/24/03
ASI #20	06/06/03
ASI #19	05/07/03
ASI #18	04/18/03
100% Construction Documents	09/27/02
90% Progress Printing	08/30/02
100% Struct./CD Progress	07/01/02
Bridge Bldg. Substructure	06/14/02
100% Steel & Concrete CD	05/15/02
& Architectural CD Progress	
100% Design Development	03/01/02
Issue	Date

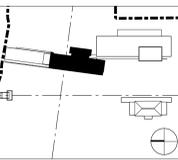

Job No. 9908

Scale 1/8" = 1'-0"

Date September 27, 2002


Title

**GROUND LEVEL
PARTIAL REFLECTED
CEILING PLAN**

Sheet No.

A601b

NOTE: FOR LOCATION OF LIGHTS, SPRINKLERS, AND DEVICES IN COMPOSITE METAL PANEL CEILING REFER TO DRAWINGS A330 AND A331 FOR TRUE DIMENSIONS.

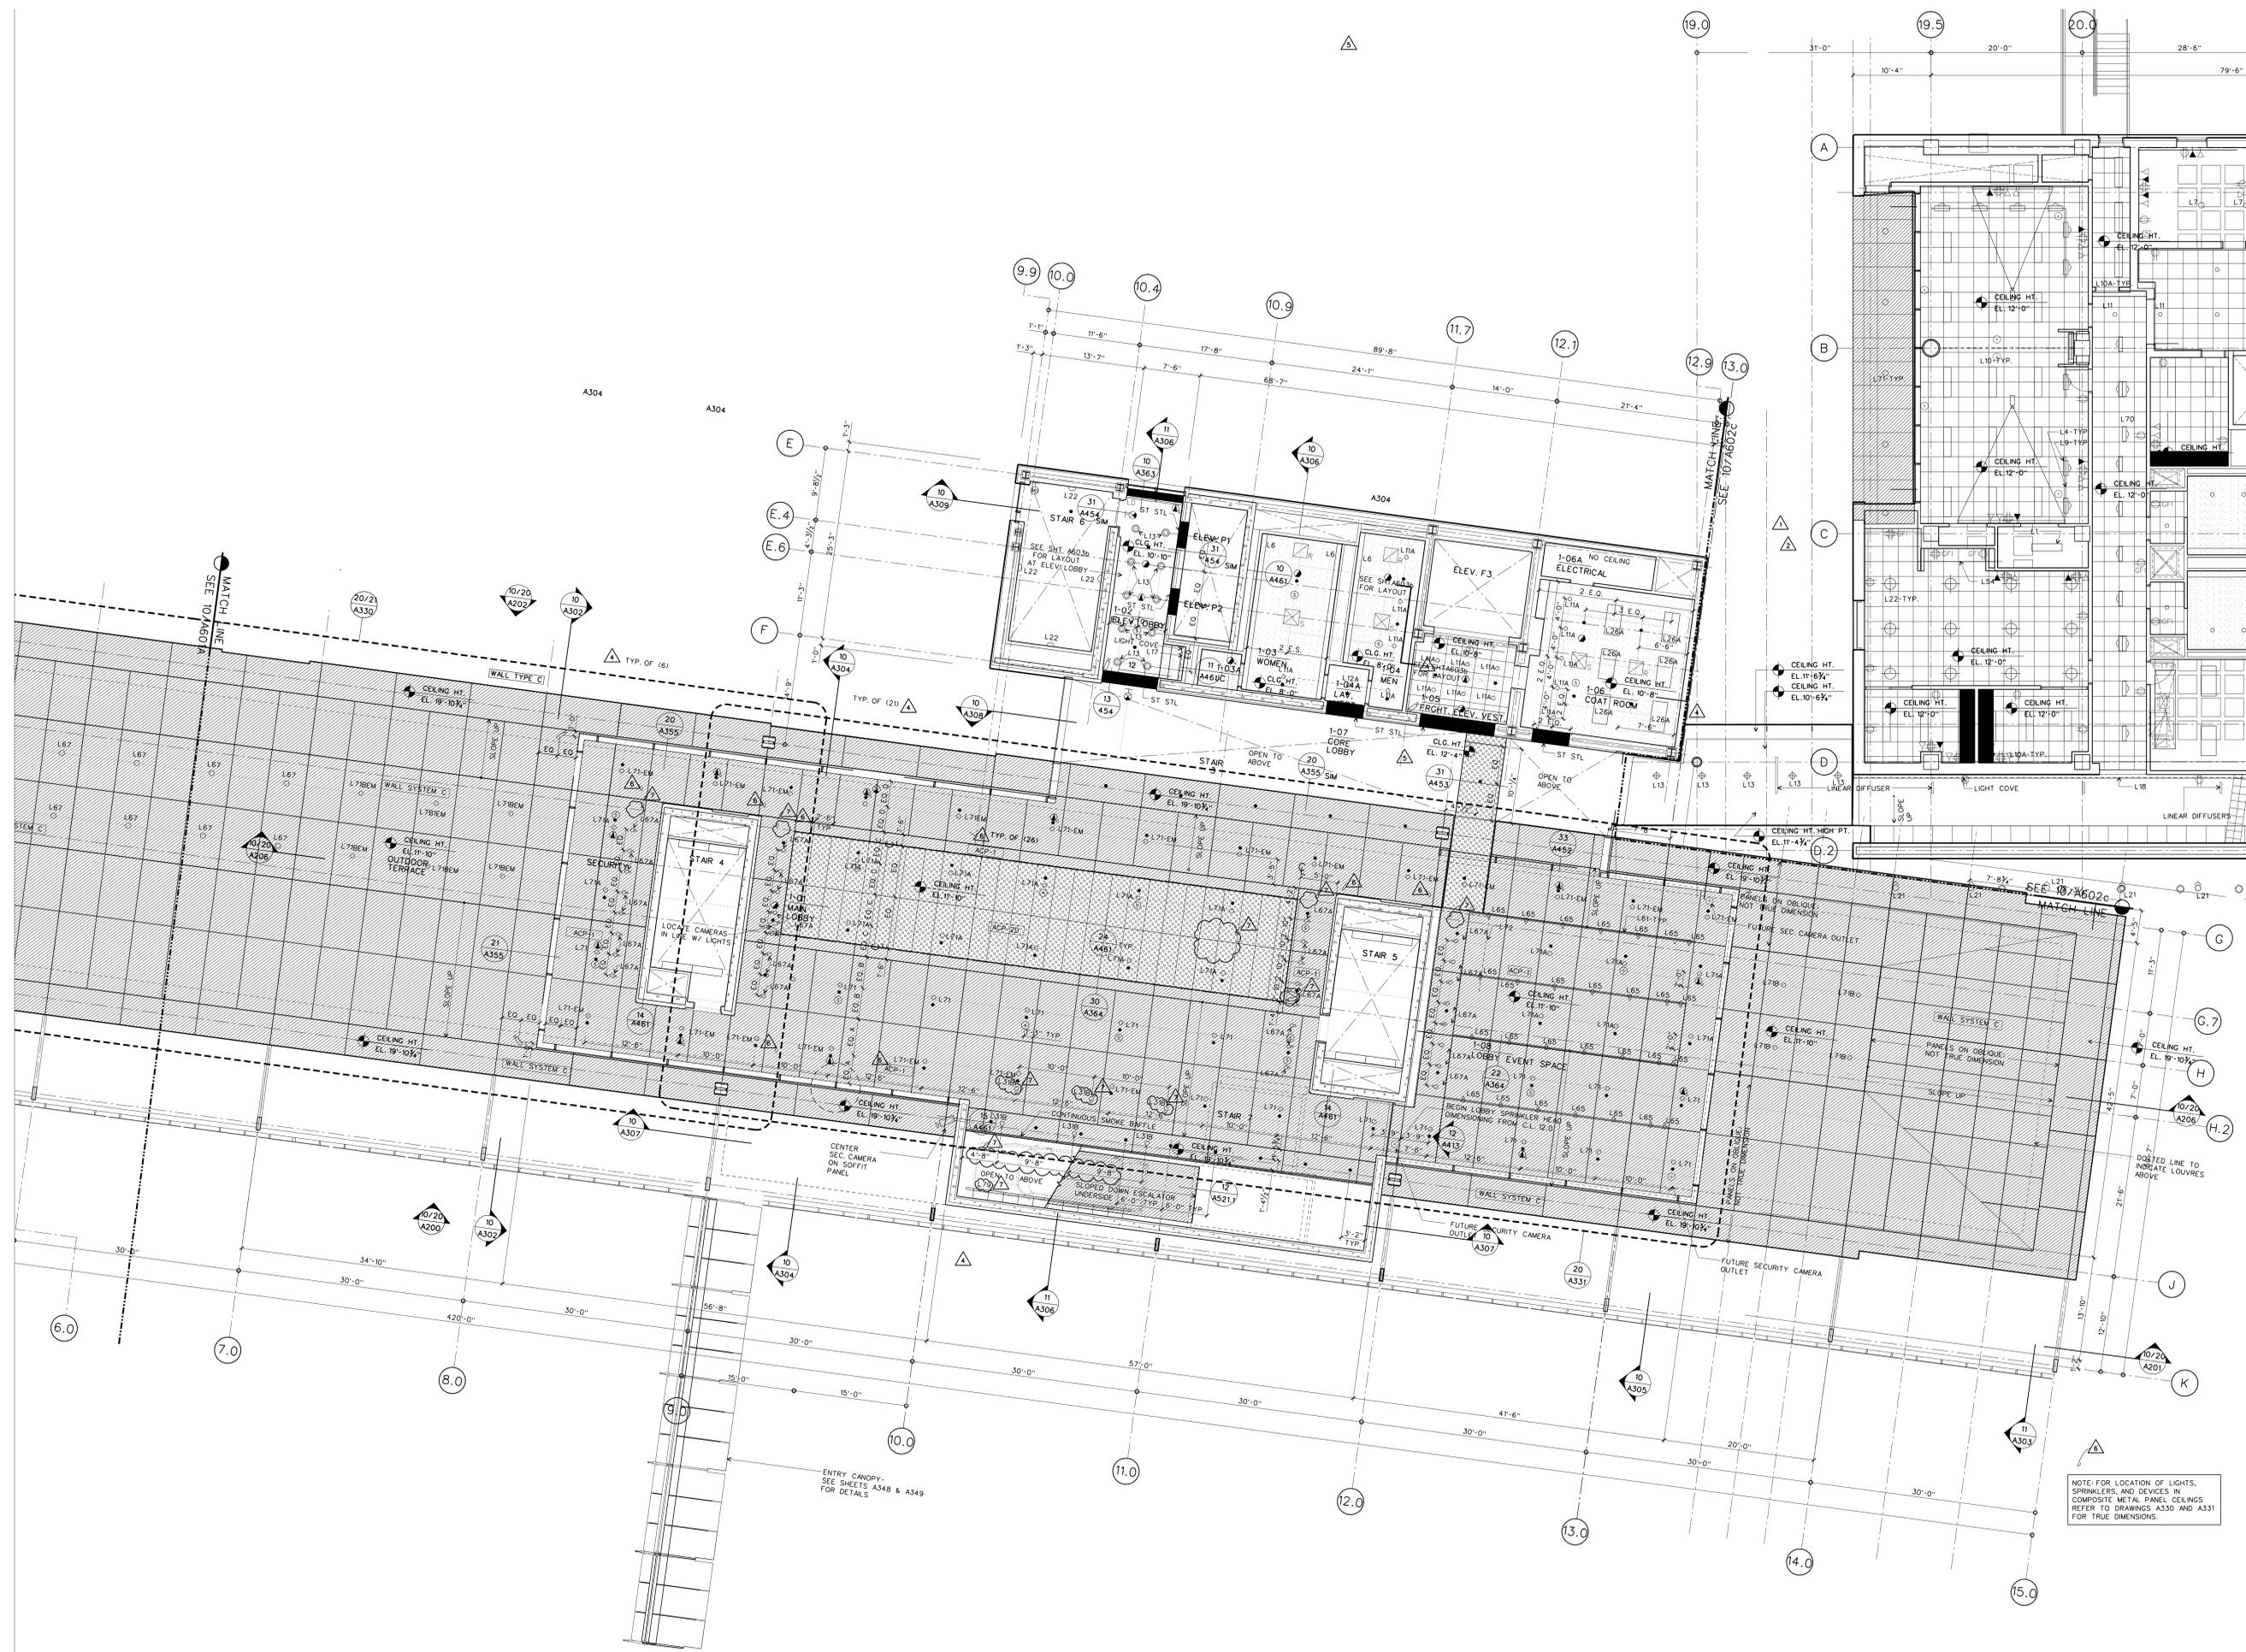

GROUND LEVEL REFLECTED CEILING PLAN B

SCALE: 1/8" = 1'-0"

RCP-01.DGN 10

FOR OFFICIAL USE ONLY