


LEGEND

- 6 C110 JUNCTION BOX
- ▽ 8 C110 CURB INLET
- 7 C110 CURB GRATE INLET
- 9 C110 GRATE INLET
- 10 C110 DITCH GRATE
- 11 C110 HEADWALL
- 13 C110 STORM DRAINAGE
- 12 C110 SLOT DRAIN
- 3 C110 PERFORATED SUBSURFACE DRAINAGE
- 5 C110 TURF DRAINAGE
- 2 C110 FOUNDATION / ROOF DRAINAGE

→ ARKANSAS RIVER →

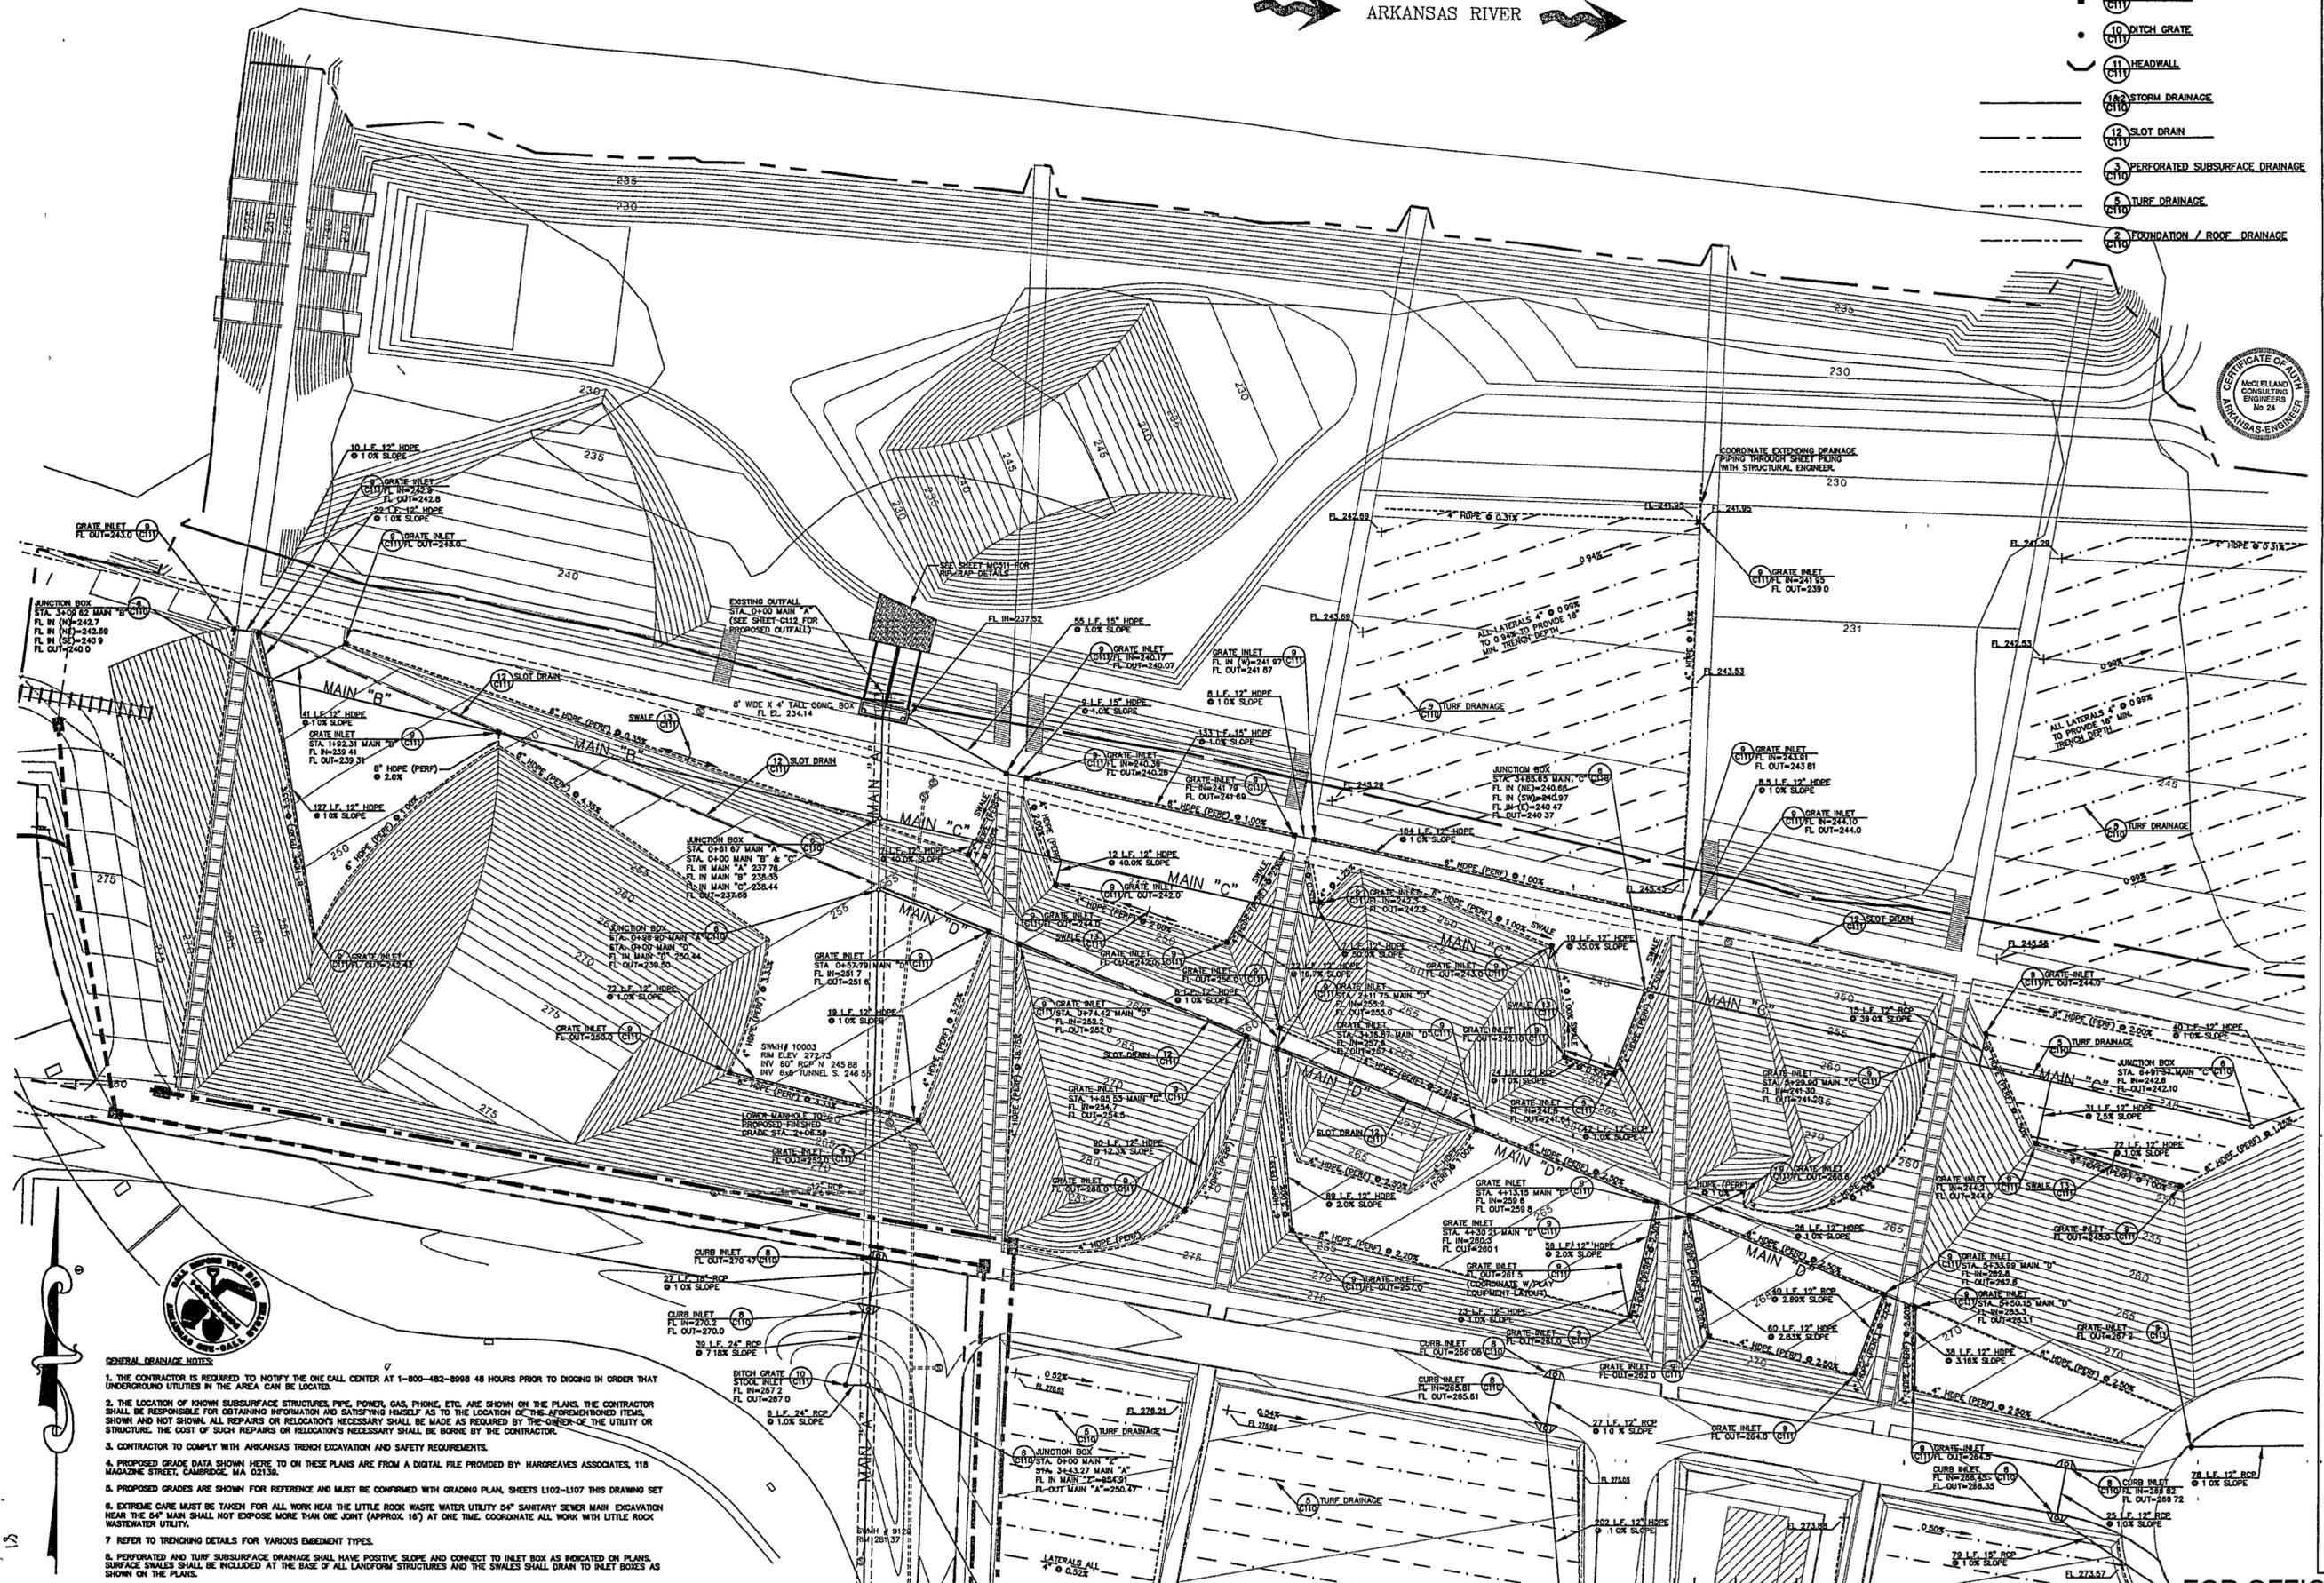

- GENERAL NOTES:**
1. THE CONTRACTOR IS REQUIRED TO NOTIFY THE ONE CALL CENTER AT 1-800-482-8998 48 HOURS PRIOR TO DIGGING IN ORDER THAT UNDERGROUND UTILITIES IN THE AREA CAN BE LOCATED.
 2. THE LOCATION OF KNOWN SUBSURFACE STRUCTURES, PIPE, POWER, GAS, PHONE, ETC. ARE SHOWN ON THE PLANS. THE CONTRACTOR SHALL BE RESPONSIBLE FOR OBTAINING INFORMATION AND SATISFYING HIMSELF AS TO THE LOCATION OF THE AFORESAID ITEMS. SHOWN AND NOT SHOWN. ALL REPAIRS OR RELOCATIONS NECESSARY SHALL BE MADE AS REQUIRED BY THE OWNER OF THE UTILITY OR STRUCTURE. THE COST OF SUCH REPAIRS OR RELOCATIONS NECESSARY SHALL BE BORNE BY THE CONTRACTOR.
 3. CONTRACTOR TO COMPLY WITH ARKANSAS TRENCH EXCAVATION AND SAFETY REQUIREMENTS.
 4. PROPOSED GRADE DATA SHOWN HERE TO ON THESE PLANS ARE FROM A DIGITAL FILE PROVIDED BY HARGREAVES ASSOCIATES, 118 MAGAZINE STREET, CAMBRIDGE, MA 02138.
 5. PROPOSED GRADES ARE SHOWN FOR REFERENCE AND MUST BE CONFIRMED WITH GRADING PLAN, SHEETS L102-L107 THIS DRAWING SET.
 6. EXTREME CARE MUST BE TAKEN FOR ALL WORK NEAR THE LITTLE ROCK WASTE WATER UTILITY 54" SANITARY SEWER MAIN EXCAVATION NEAR THE 54" MAIN SHALL NOT EXPOSE MORE THAN ONE JOINT (APPROX. 18') AT ONE TIME. COORDINATE ALL WORK WITH LITTLE ROCK WASTEWATER UTILITY.
 7. REFER TO TRENCHING DETAILS FOR VARIOUS EMBEDMENT TYPES.
 8. PERFORATED AND TURF SUBSURFACE DRAINAGE SHALL HAVE POSITIVE SLOPE AND CONNECT TO INLET BOX AS INDICATED ON PLANS. SURFACE SWALES SHALL BE INCLUDED AT THE BASE OF ALL LANDFORM STRUCTURES AND THE SWALES SHALL DRAIN TO INLET BOXES AS SHOWN ON THE PLANS.

**WILLIAM J. CLINTON
PRESIDENTIAL
CENTER & PARK**

LITTLE ROCK, ARKANSAS

Architect
POLSHKE PARTNERSHIP LLP
320 West 13th Street
New York, New York 10014
212 607 7171

Landscape Architect
HARGREAVES ASSOCIATES
118 Magazine Street
Cambridge Massachusetts 02139
617 551 0070
617 551 0064 f

Coordinating Landscape Architect
LANSCAPE ARCHITECTURE, INC
2300 Cottondale Lane, Suite 202
Little Rock, Arkansas 72202
501 374 5510



Civil Engineer
McCLELLAND CONSULTING ENGINEERS
900 W Markham Street
Little Rock Arkansas 72201
501 374 0272


Electrical Engineer
CROMWELL ARCHITECTS ENGINEERS
101 South Spring Street
Little Rock, Arkansas 72201
501 372 2500

Manne + Structural Engineers
MOFFATT & NICHOL ENGINEERS
1818 East Millbrook Road, Suite 160
Raleigh, North Carolina 27609
919 781 4828


Fountain
DAN EUSER WATERARCHITECTURE INC.
58 Mackeize Drive West
Richmond Hill, Ontario L4C 3S2
CANADA
905 884 4176

Playground Design
PLAY SITE ARCHITECTURE
7 Fairway Road
Acton Massachusetts 01720
978.263 1050

Signage Design
POULIN + MORRIS
286 Spring Street, Sixth Floor
New York, New York 10013
212 675 1332

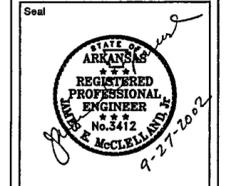

Issue	Date
05 100% Site Package 2 CD	09/27/02
04 90% Site Package 2 CD	08/16/02
03 50% Site Package 2 CD	06/29/02
02 100% Design Development	04/09/02
01 100% Site Package 1 CD	02/15/02

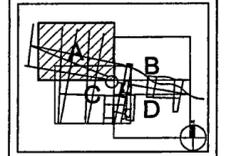

Job No PPA 9908
HA CPC0101

Scale 1" = 30'-0"

Date SEPTEMBER 27, 2002

Title **SITE PACKAGE 2
100% CONSTRUCTION DOCUMENTS
SITE DRAINAGE PLAN
AREA "A"**

Sheet No

C102

FOR OFFICIAL USE ONLY