



MAIN "A" EXISTING STORM DRAINAGE TUNNEL

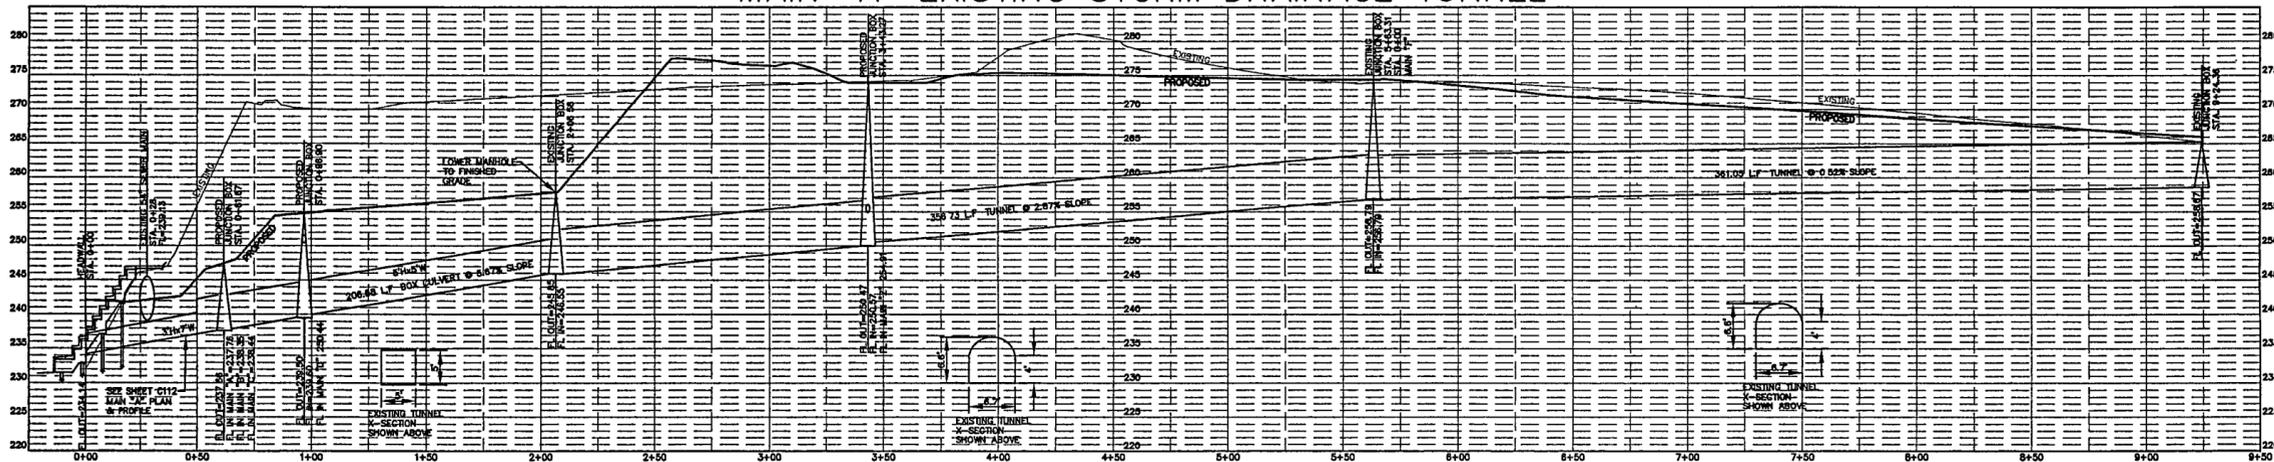


SCALE:
VERT: 1"=10'
HORZ: 1"=30'

MAIN "C"

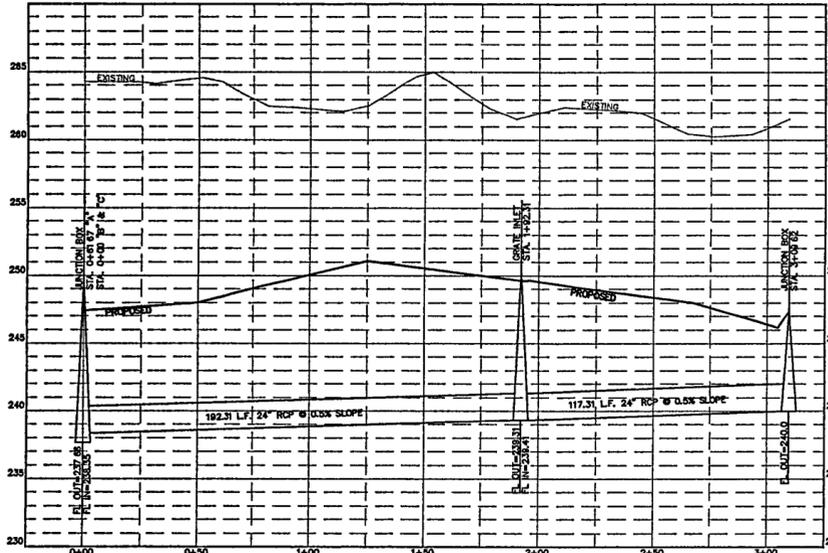


SCALE:
VERT: 1"=5'
HORZ: 1"=30'

MAIN "D"

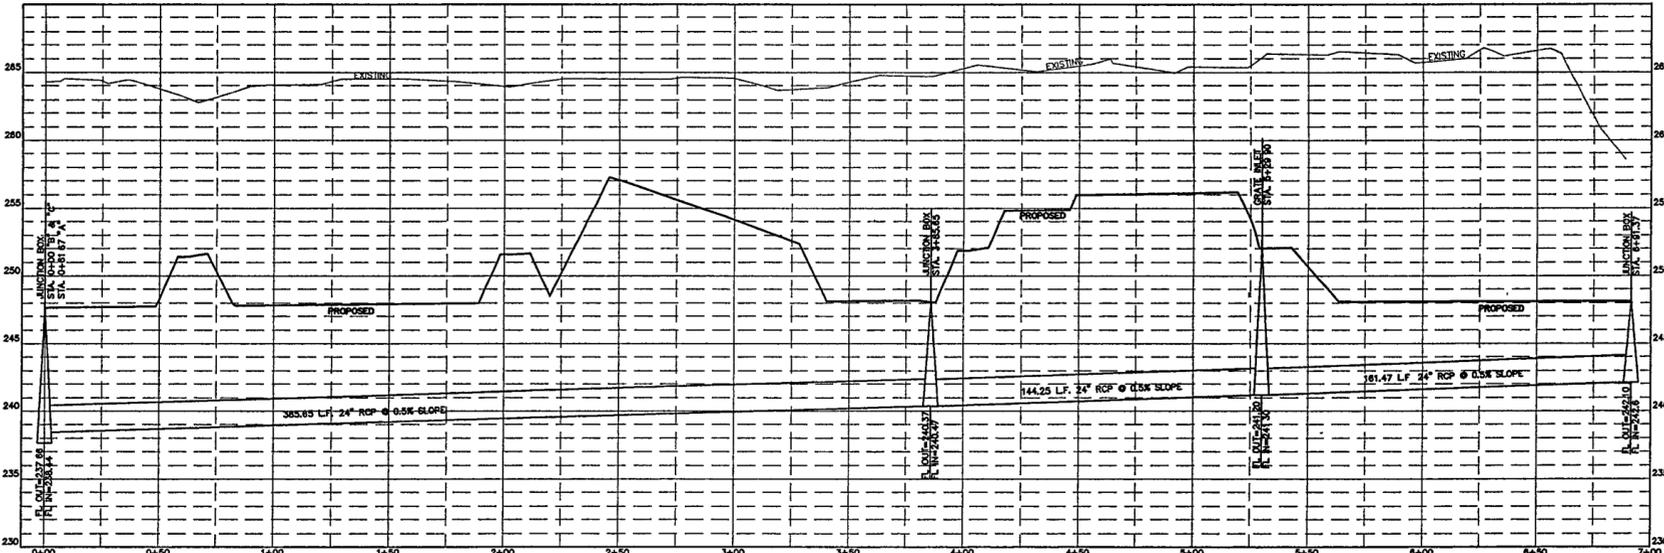

SCALE:
VERT: 1"=5'
HORZ: 1"=30'

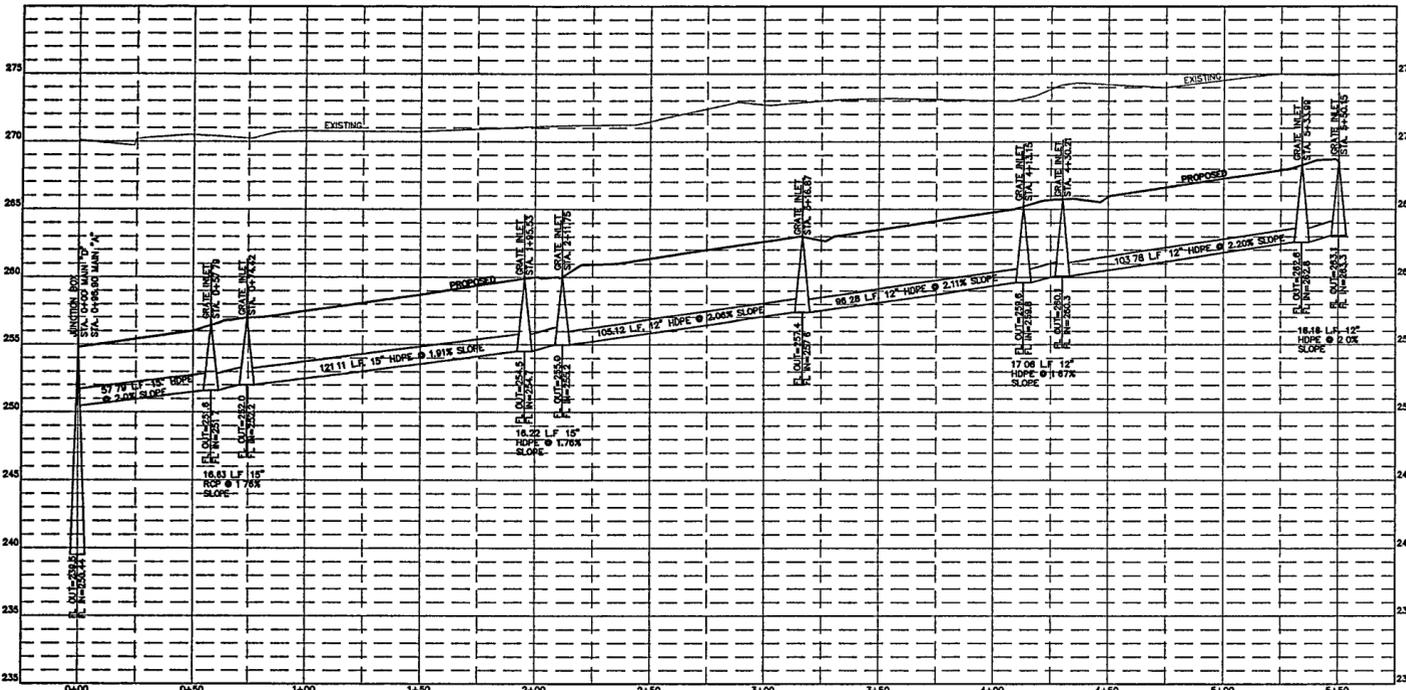

SCALE:
VERT: 1"=5'
HORZ: 1"=30'

NOTE:
PROPOSED GRADES ARE
SHOWN FOR REFERENCE
AND MUST BE CONFIRMED
WITH GRADING PLAN.

WILLIAM J. CLINTON
PRESIDENTIAL
CENTER & PARK

LITTLE ROCK, ARKANSAS

Architect
POLSHAK PARTNERSHIP LLP
320 West 13th Street
New York, New York 10014
212 607 7171

Landscape Architect

118 Magazine Street
Cambridge, Massachusetts 02139
617 661 0071
617 661 0641

Coordinating Landscape Architect
LANDSCAPE ARCHITECTURE, INC.
2300 Cottondale Lane, Suite 202
Little Rock, Arkansas 72202
501.374.5610

Civil Engineer

MCLELLAND CONSULTING ENGINEERS
800 W Markham Street
Little Rock, Arkansas 72201
501 371 0272

Electrical Engineer

CROMMELL ARCHITECTS ENGINEERS
101 South Spring Street
Little Rock, Arkansas 72201
501.372.2800

Marine + Structural Engineers

MOFFATT & NICHOL ENGINEERS
1816 East Millbrook Road, Suite 160
Raleigh, North Carolina 27609
919 781.4825

Fountain

DAN EUSER WATERARCHITECTURE INC.
58 Mackenzie Drive West
Richmond Hill, Ontario L4C 3S2
CANADA
905 884 4178

Playground Design


PLAY SITE ARCHITECTURE
7 Fairway Road
Acton, Massachusetts 01720
978.263.1090

Signage Design

POULIN + MORRIS
288 Spring Street, Sixth Floor
New York, New York 10013
212.675.1332



Issue	Date
05 100% Site Package 2 CD	09/27/02
04 90% Site Package 2 CD	08/16/02
03 60% Site Package 2 CD	06/29/02
02 100% Design Development	04/01/02
01 100% Site Package 1 CD	02/15/02

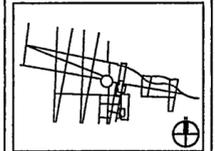

Job No PPA 8908
HA, CPC0101

Scale AS SHOWN

Date SEPTEMBER 27, 2002

Title SITE PACKAGE 2
100% CONSTRUCTION DOCUMENTS
DRAINAGE PROFILES

Sheet No

C106

FOR OFFICIAL USE ONLY