 


LITTLE ROCK, ARKANSAS

Architect
POLSHKE PARTNERSHIP LLP
320 West 13th Street
New York, New York 10014
212 807 7171

Landscape Architect



118 Magazine Street
Cambridge, Massachusetts 02139
617 861 0070
617 861 0084

Coordinating Landscape Architect
LANDSCAPE ARCHITECTURE, INC.
2300 Cottondale Lane, Suite 202
Little Rock, Arkansas 72202
501 374 5810

Civil Engineer
MCLELLAND CONSULTING ENGINEERS
900 W Markham Street
Little Rock, Arkansas 72201
501 371 0272


Electrical Engineer
CROMWELL ARCHITECTS ENGINEERS
101 South Spring Street
Little Rock, Arkansas 72201
501.372.2800

Manne + Structural Engineers
MOFFATT & NICHOL ENGINEERS
1516 East Millbrook Road, Suite 160
Raleigh, North Carolina 27609
919 781 4828


Fountain
DAN ELUSER WATERARCHITECTURE INC.
58 Mackenzie Drive West
Richmond Hill, Ontario L4C 3S2
CANADA
905 884-4176

Playground Design
PLAY SITE ARCHITECTURE
7 Fairway Road
Acton, Massachusetts 01720
978.283.1090

Signage Design
POULIN + MORRIS
285 Spring Street, Sixth Floor
New York, New York 10013
212 675 1332

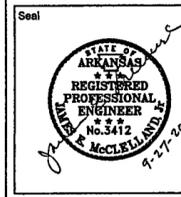

Issue	Date
05 100% Site Package 2 CD	09/27/02
04 80% Site Package 2 CD	08/16/02
03 60% Site Package 2 CD	06/29/02
02 100% Design Development	04/01/02
01 100% Site Package 1 CD	02/15/02

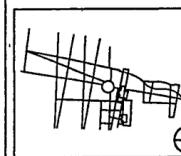

Job No PPA 6908
HA, CPG0101

Scale AS SHOWN

Date SEPTEMBER 27, 2002


Title SITE PACKAGE 2
100% CONSTRUCTION DOCUMENTS
DRAINAGE PROFILES

Sheet No.

C107


FOR OFFICIAL USE ONLY

MAIN "F"

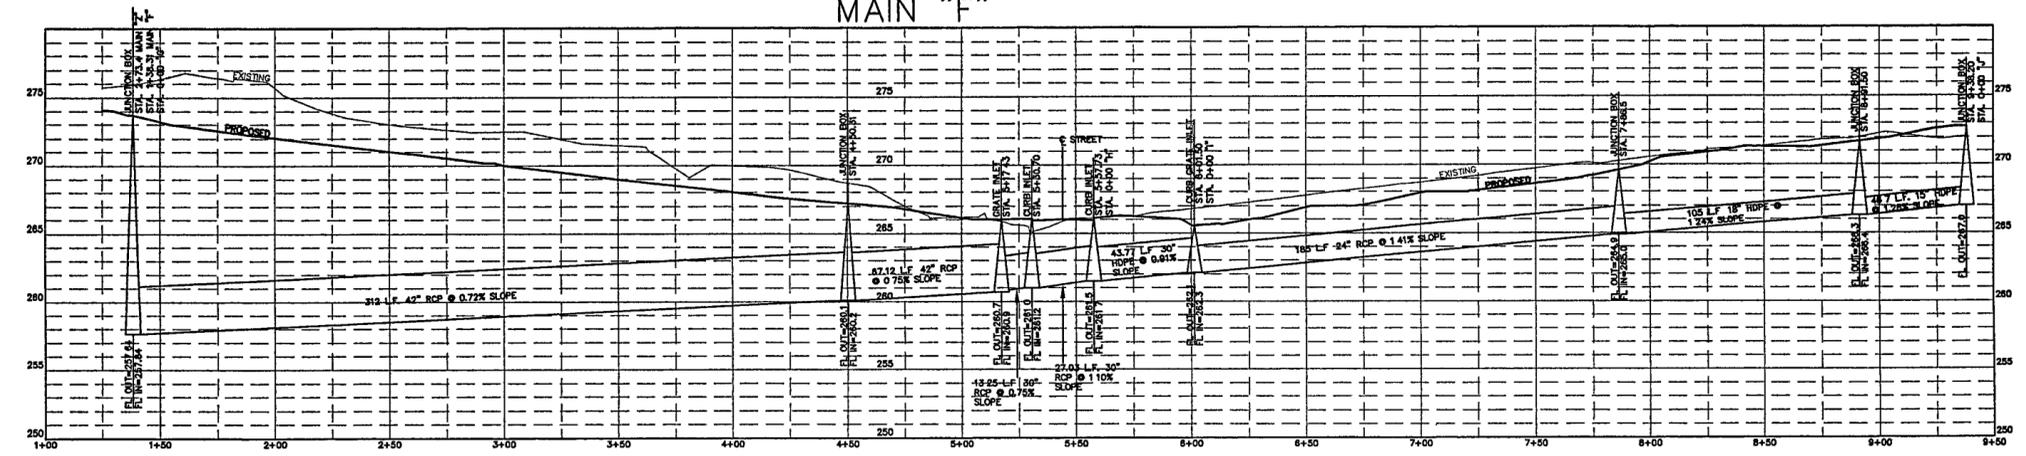


SCALE:
VERT: 1"=5'
HORZ: 1"=30'

MAIN "G"

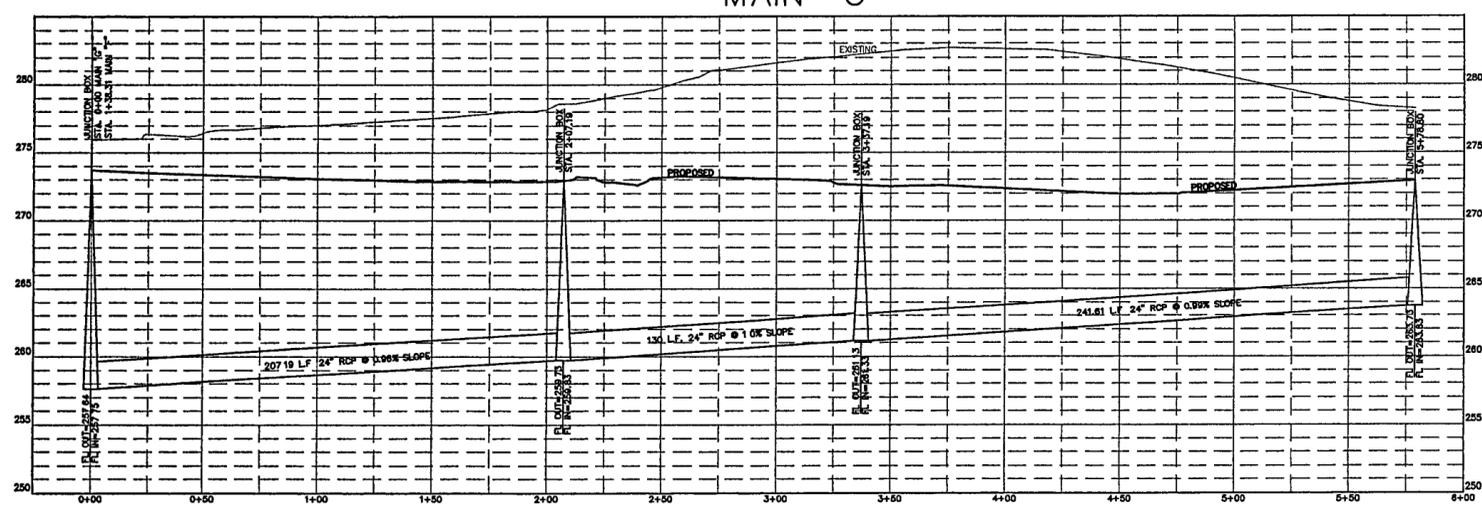


SCALE:
VERT: 1"=5'
HORZ: 1"=30'

MAIN "H"

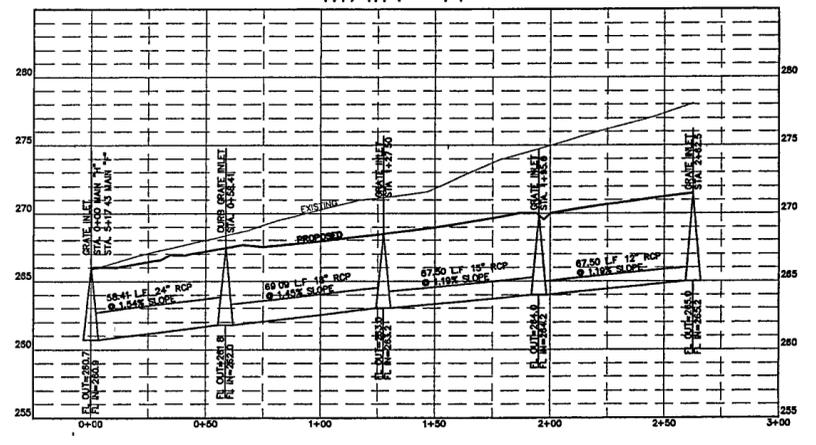


SCALE:
VERT: 1"=5'
HORZ: 1"=30'

MAIN "Z"

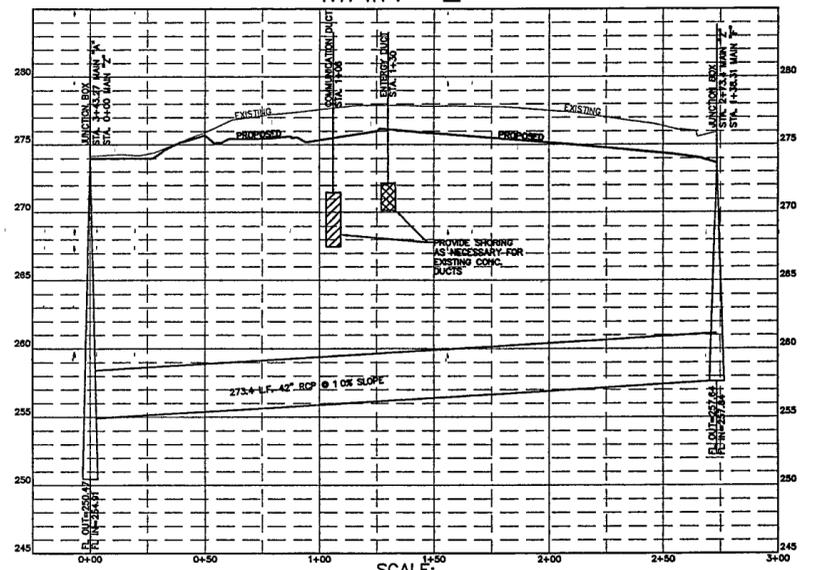


SCALE:
VERT: 1"=5'
HORZ: 1"=30'

MAIN "J"

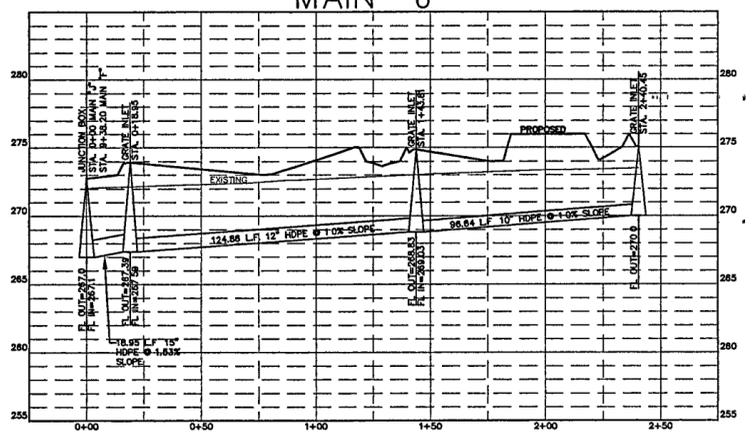

SCALE:
VERT: 1"=5'
HORZ: 1"=30'

MAIN "I"

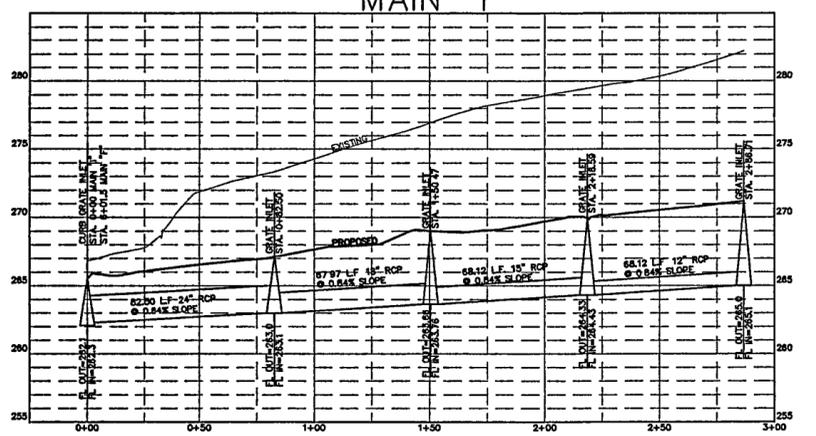

SCALE:
VERT: 1"=5'
HORZ: 1"=30'

NOTE:
PROPOSED GRADES ARE
SHOWN FOR REFERENCE
AND MUST BE CONFIRMED
WITH GRADING PLAN

NOTE:
REFER TO MAIN "I" ON THIS
SHEET FOR CONNECTION TO
EXISTING TUNNEL