



MAIN "K"

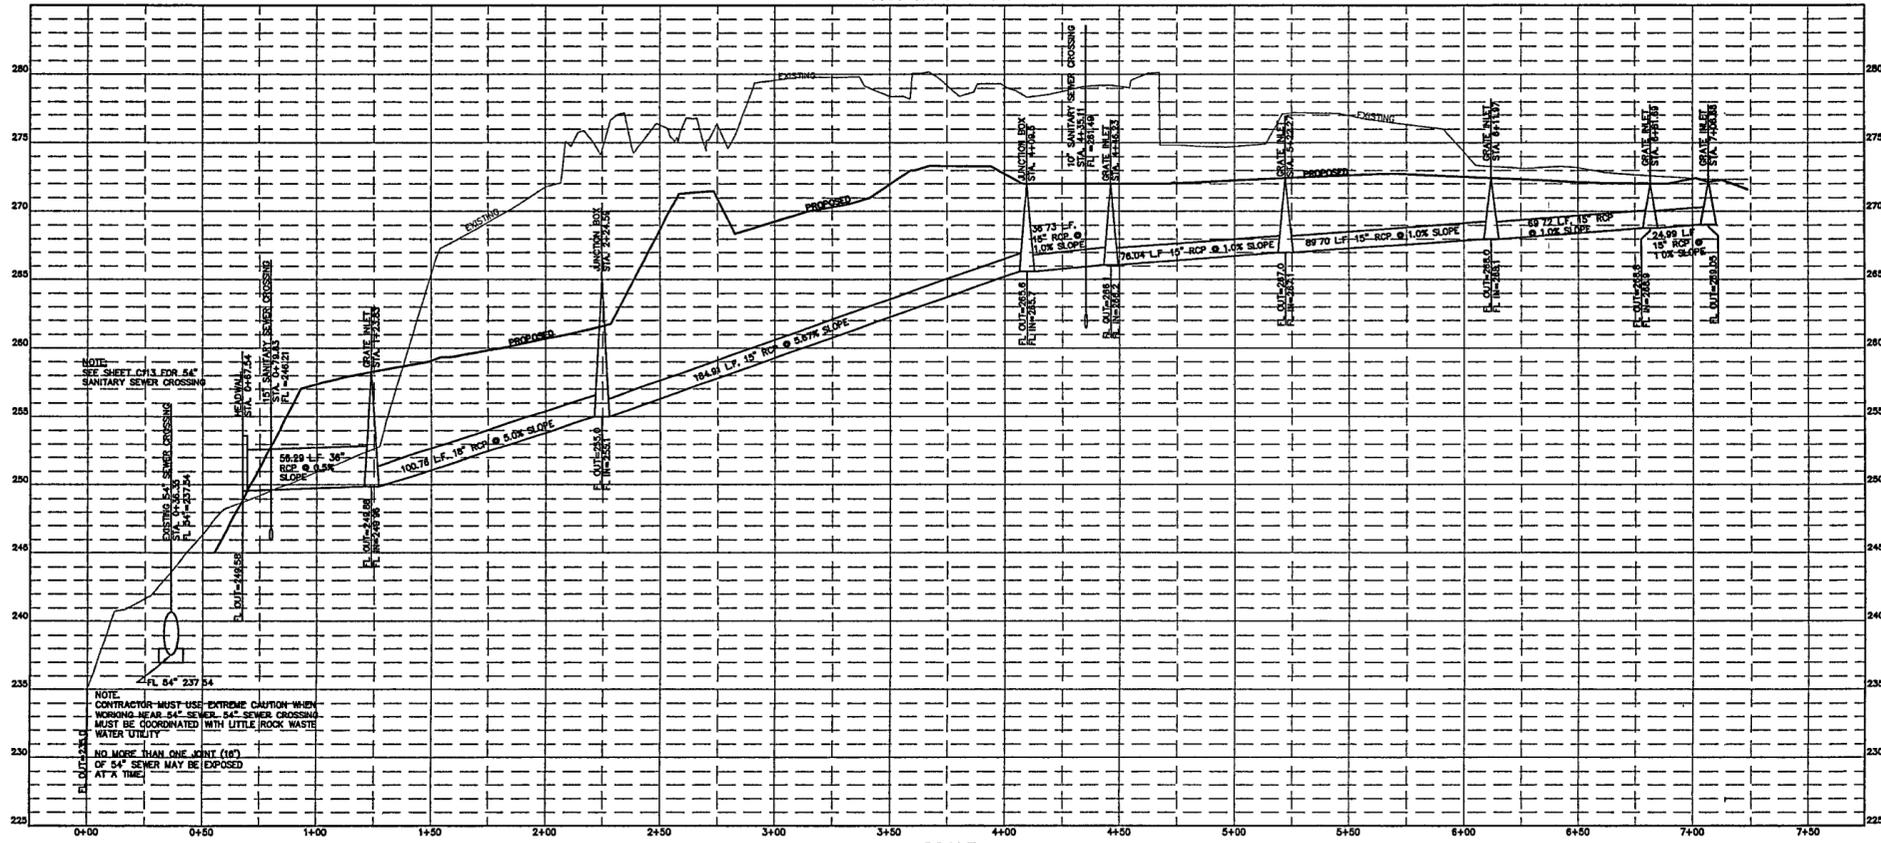

SCALE:  
VERT: 1"=5'  
HORIZ: 1"=30'

MAIN "L"

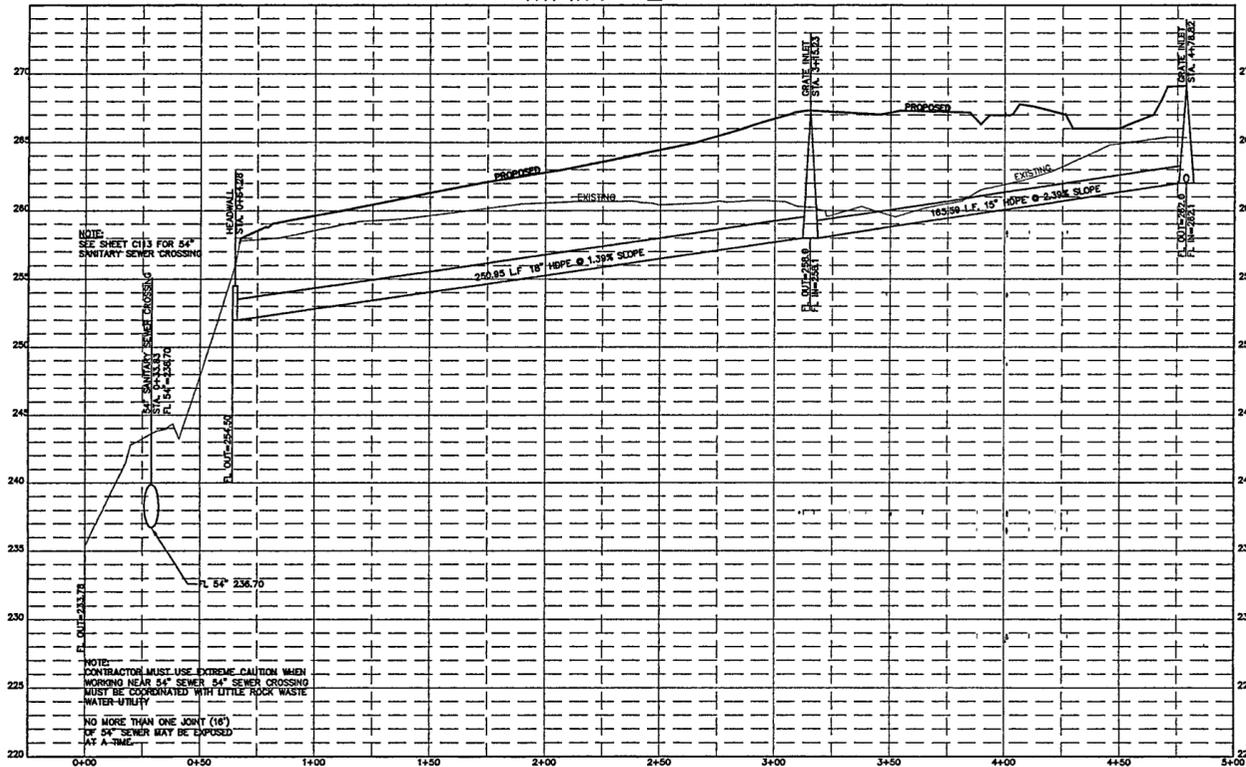

SCALE:  
VERT: 1"=5'  
HORIZ: 1"=30'


NOTE:  
PROPOSED GRADES ARE SHOWN FOR  
REFERENCE AND MUST BE CONFIRMED  
WITH FINAL GRADING PLAN.



WILLIAM J. CLINTON  
PRESIDENTIAL  
CENTER & PARK

LITTLE ROCK, ARKANSAS

Architect  
POLSHEK PARTNERSHIP LLP  
320 West 13th Street  
New York, New York 10014  
212.507.7171

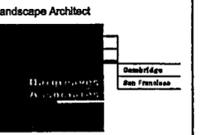

118 Magazine Street  
Cambridge, Massachusetts 02139  
617.661.0070  
617.661.0064

Coordinating Landscape Architect  
LANDSCAPE ARCHITECTURE, INC  
2300 Cottondale Lane, Suite 202  
Little Rock, Arkansas 72202  
501.374.5610

Civil Engineer  
McCLELLAND CONSULTING ENGINEERS  
900 W Markham Street  
Little Rock, Arkansas 72201  
501.371.0272


Electrical Engineer  
CROMWELL ARCHITECTS ENGINEERS  
101 South Spring Street  
Little Rock, Arkansas 72201  
501.372.2800

Manne + Structural Engineers  
MOFFATT & NICHOL ENGINEERS  
1616 East Millbrook Road, Suite 160  
Raleigh, North Carolina 27609  
919.781.4828


Fountain  
DAN EUSER WATERARCHITECTURE INC.  
58 Mackezio Drive West  
Richmond Hill, Ontario L4C 3S2  
CANADA  
905.884.4176

Playground Design  
PLAY SITE ARCHITECTURE  
7 Fairway Road  
Acton, Massachusetts 01720  
978.269.1090

Signage Design  
POULIN + MORRIS  
286 Spring Street, Sixth Floor  
New York, New York 10013  
212.675.1332

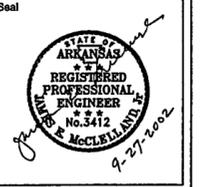

| Issue                      | Date     |
|----------------------------|----------|
| 05 100% Site Package 2 CD  | 09/27/02 |
| 04 90% Site Package 2 CD   | 08/16/02 |
| 03 80% Site Package 2 CD   | 08/28/02 |
| 02 100% Design Development | 04/01/02 |
| 01 100% Site Package 1 CD  | 02/15/02 |

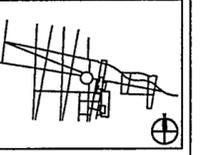

Job No PPA 8908  
HA, CPC0101

Scale AS SHOWN

Date SEPTEMBER 27, 2002

Title SITE PACKAGE 2  
100% CONSTRUCTION DOCUMENTS  
DRAINAGE PROFILES

Sheet No. C108

FOR OFFICIAL USE ONLY