



MAIN "M"

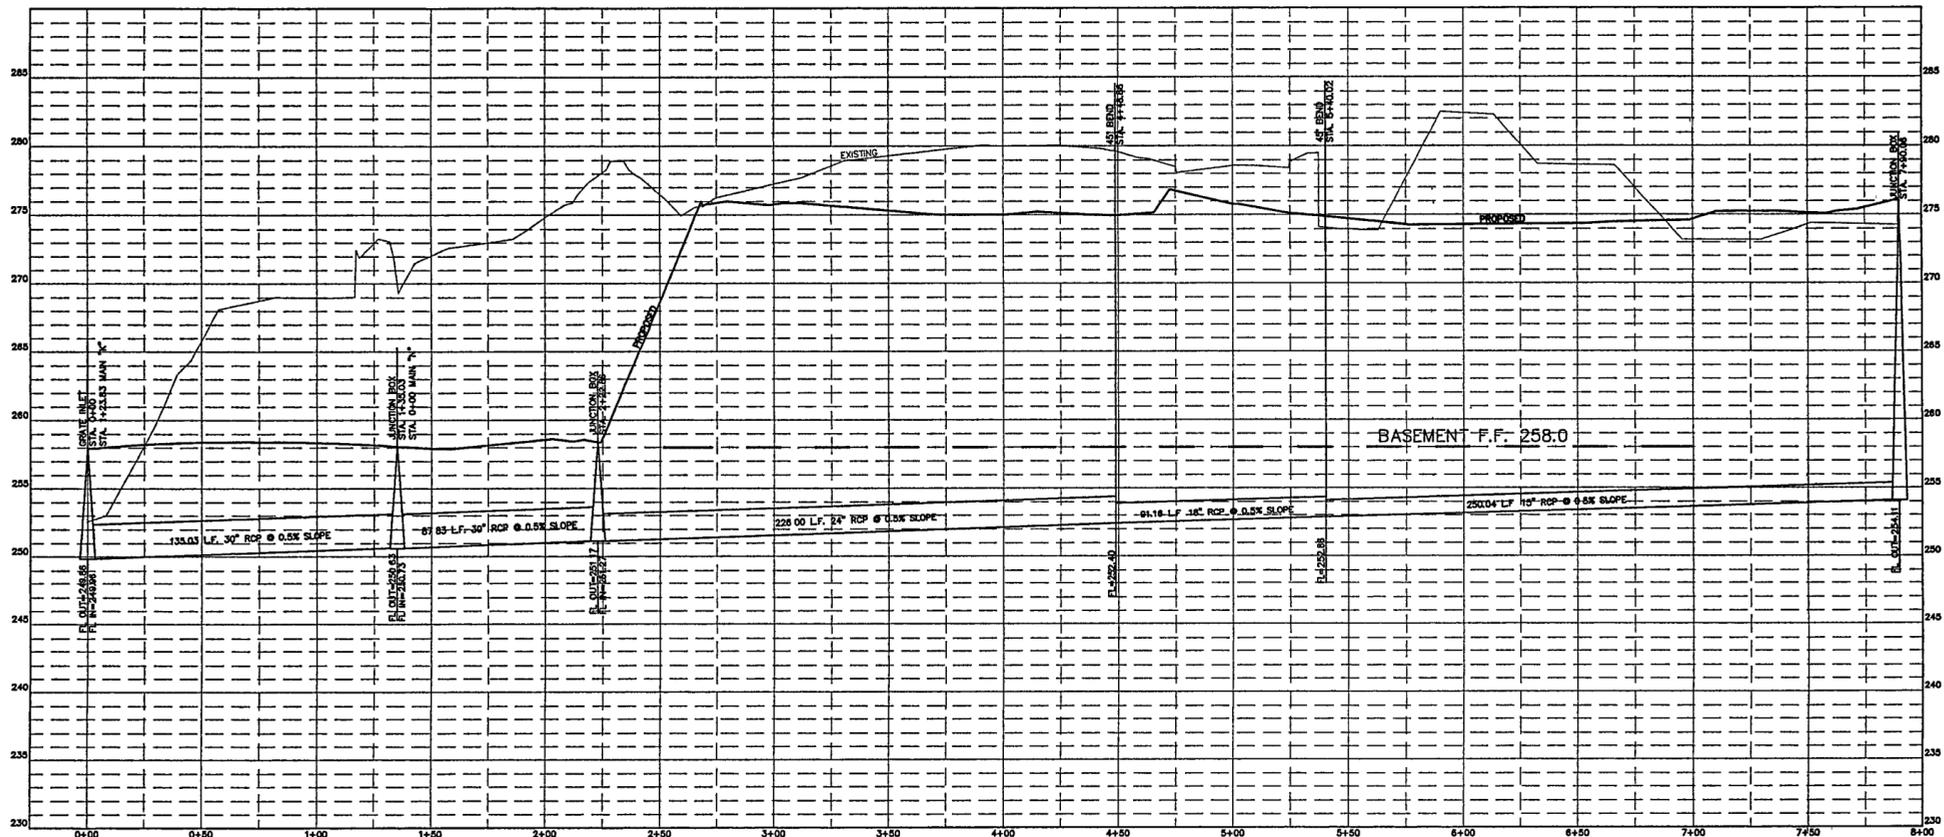

SCALE:
VERT: 1"=5'
HORIZ: 1"=30'

MAIN "N"

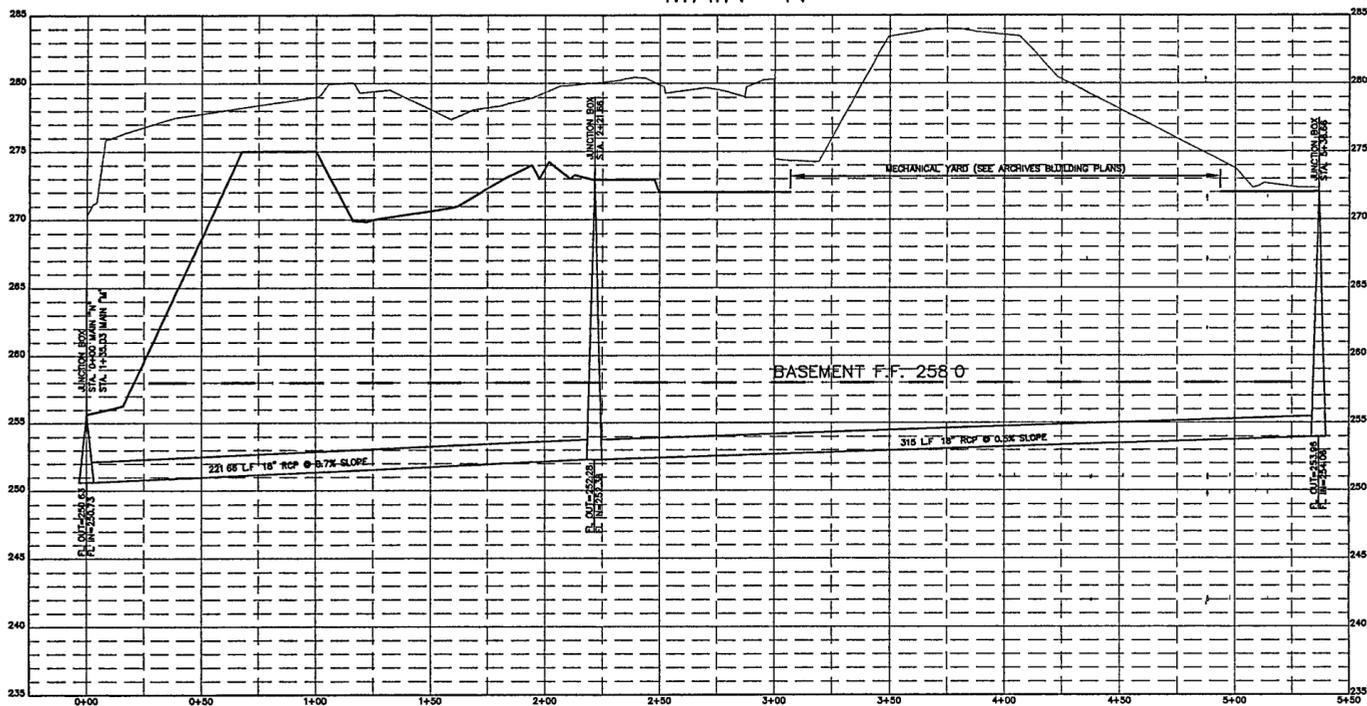

SCALE:
VERT: 1"=5'
HORIZ: 1"=30'

NOTE:
PROPOSED GRADES ARE SHOWN FOR
REFERENCE AND MUST BE CONFIRMED
WITH FINAL GRADING PLAN.



WILLIAM J. CLINTON
PRESIDENTIAL
CENTER & PARK

LITTLE ROCK, ARKANSAS

Architect
POLSHEK PARTNERSHIP LLP
330 West 13th Street
New York, New York 10014
212 807 7171

Landscape Architect

LANDSCAPE ARCHITECTURE, INC.
118 Magazine Street
Cambridge, Massachusetts 02139
617 861 0070
617 861 0064

Coordinating Landscape Architect
LANDSCAPE ARCHITECTURE, INC.
2300 Cottondale Lane, Suite 202
Little Rock, Arkansas 72202
501 374 5610

Civil Engineer
MCLELLAND CONSULTING ENGINEERS
900 W Markham Street
Little Rock, Arkansas 72201
501 571 0272

Electrical Engineer
CROMWELL ARCHITECTS ENGINEERS
101 South Spring Street
Little Rock, Arkansas 72201
501 372 2900


Marine + Structural Engineers
MOFFATT & NICHOL ENGINEERS
1818 East Millbrook Road, Suite 180
Raleigh, North Carolina 27609
919 851 4625

Fountain
DAN EUSER WATERARCHITECTURE INC.
55 Mackenzie Drive West
Richmond Hill, Ontario L4C 3S2
CANADA
905 884 4178

Playground Design
PLAY SITE ARCHITECTURE
7 Fairway Road
Acton, Massachusetts 01720
978 283 1090

Signage Design
POULIN + MORRIS
286 Spring Street, Sixth Floor
New York, New York 10013
212 675 1332

Issue	Date
05 100% Site Package 2 CD	09/27/02
04 90% Site Package 2 CD	08/16/02
03 60% Site Package 2 CD	08/29/02
02 100% Design Development	04/01/02
01 100% Site Package 1 CD	02/15/02

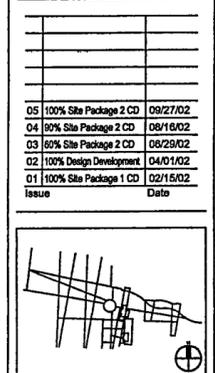

Job No PPA 8908
HA CPC0101

Scale AS SHOWN

Date SEPTEMBER 27, 2002

Title SITE PACKAGE 2
100% CONSTRUCTION DOCUMENTS
DRAINAGE PROFILES

Sheet No.

C109

FOR OFFICIAL USE ONLY