



SEWERLINE "A"

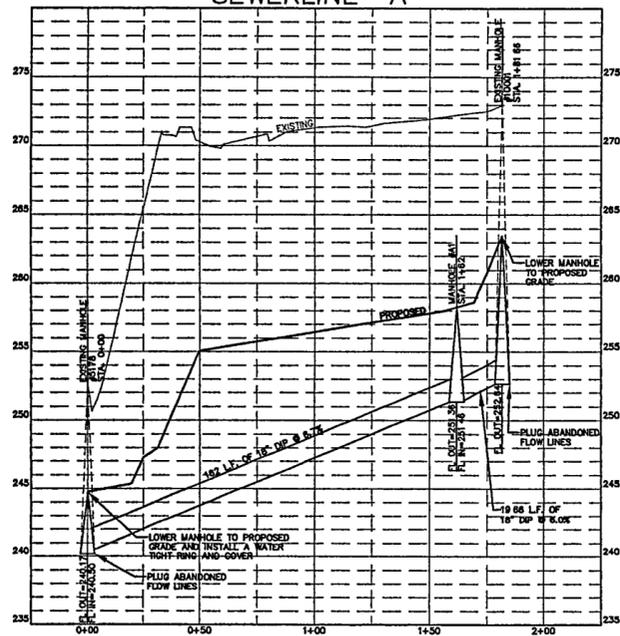

SCALE:
VERT: 1"=5'
HORZ: 1"=30'

NOTE:
PROPOSED GRADES ARE
SHOWN FOR REFERENCE
AND MUST BE CONFIRMED
WITH GRADING PLAN.


SEWERLINE "B"

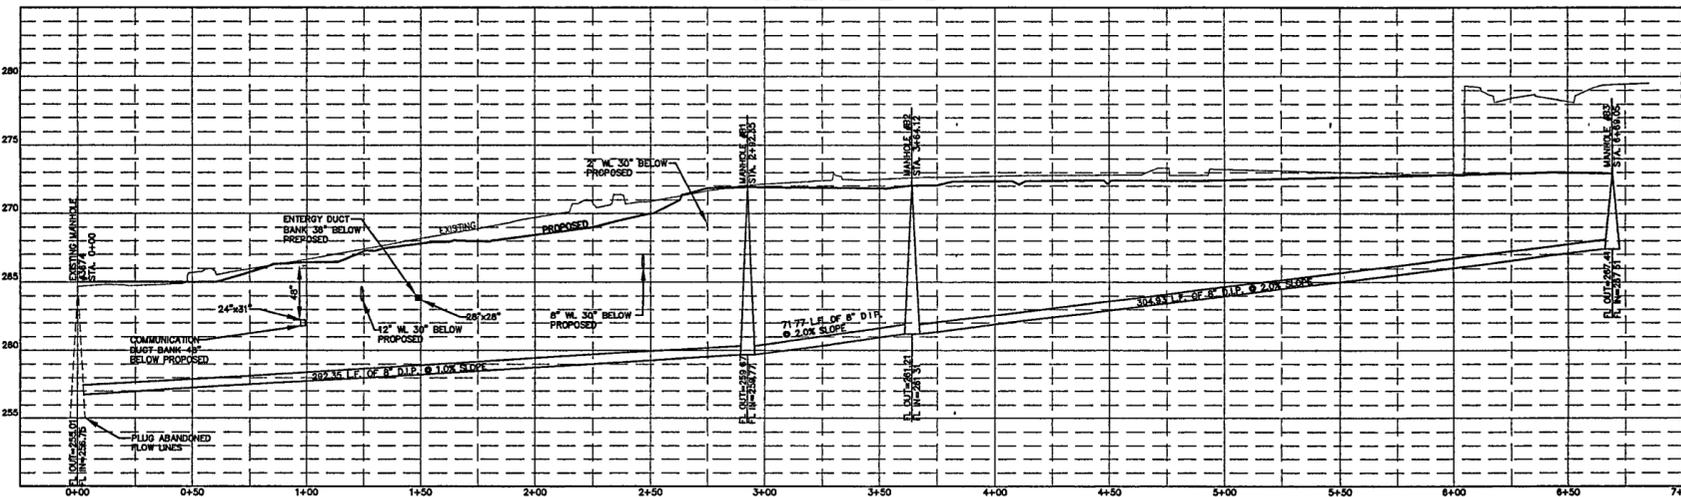

SCALE:
VERT: 1"=5'
HORZ: 1"=30'


NOTE:
PROPOSED GRADES ARE
SHOWN FOR REFERENCE
AND MUST BE CONFIRMED
WITH GRADING PLAN.

SEWERLINE "C"

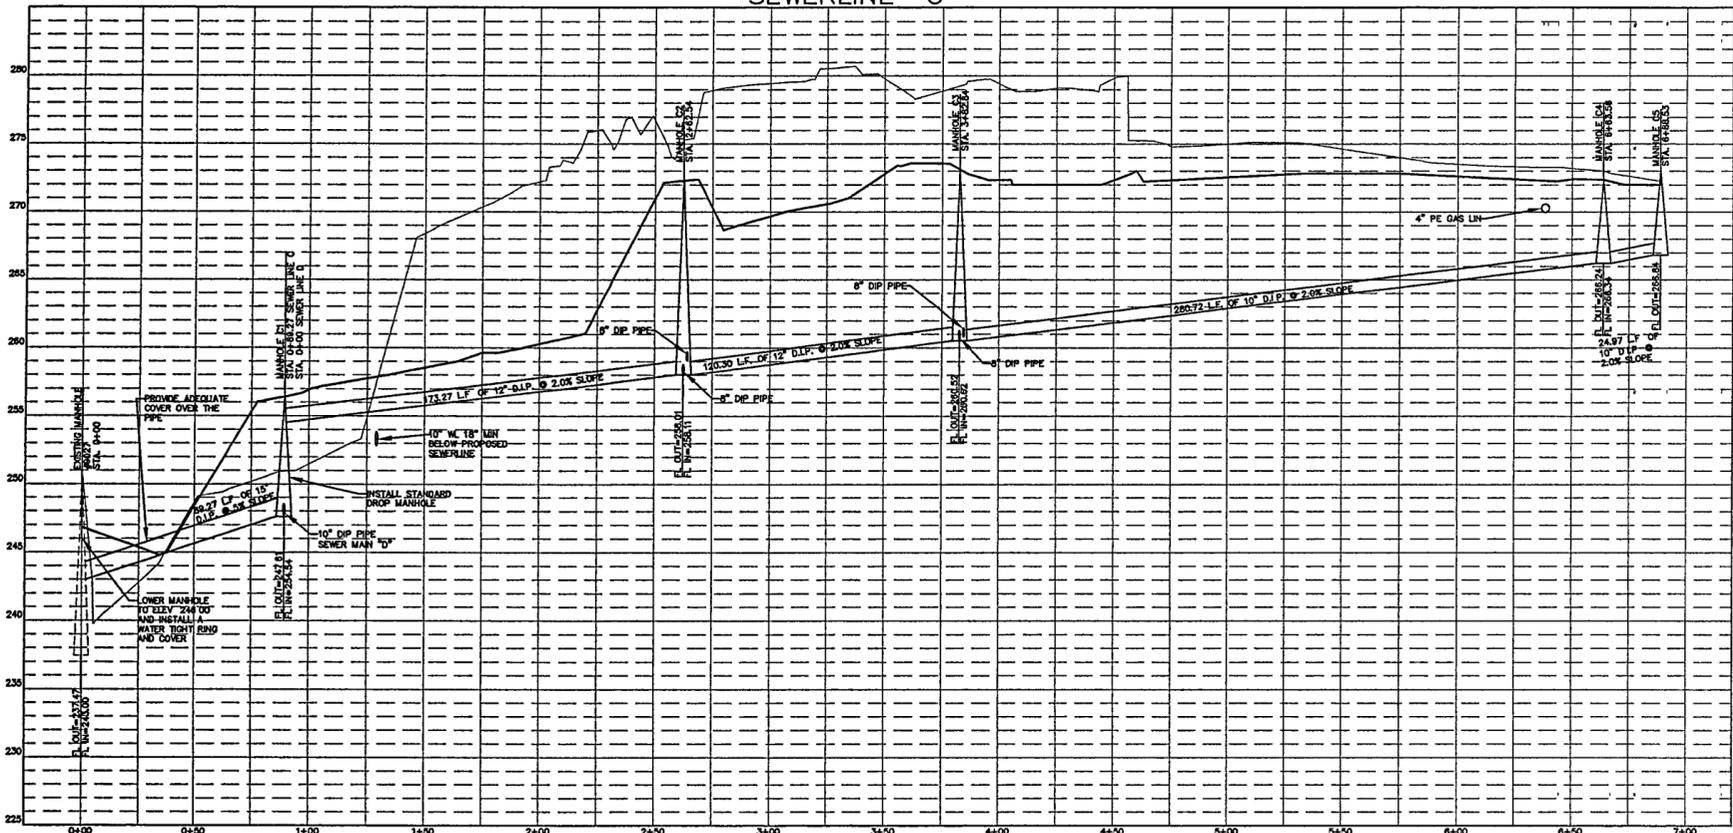

SCALE:
VERT: 1"=5'
HORZ: 1"=30'

SEWERLINE "D"

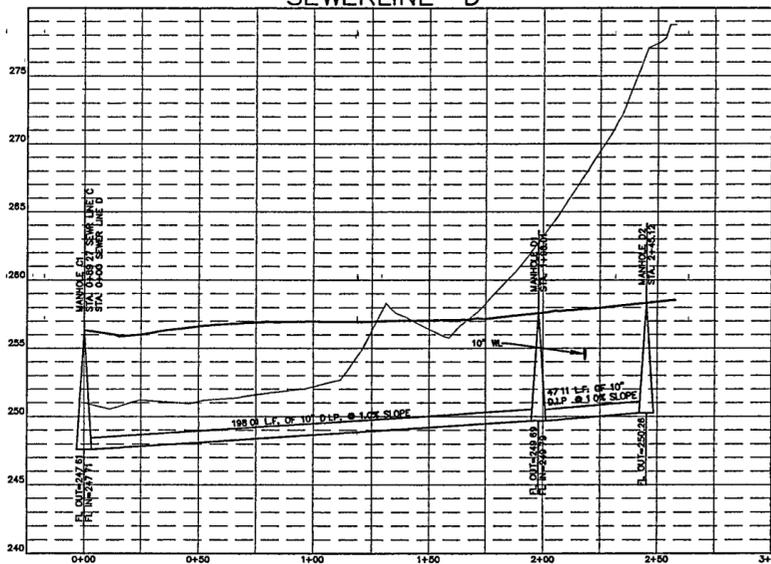

SCALE:
VERT: 1"=5'
HORZ: 1"=30'



WILLIAM J. CLINTON
PRESIDENTIAL
CENTER & PARK

LITTLE ROCK, ARKANSAS

Architect
POLSHEK PARTNERSHIP LLP
320 West 13th Street
New York, New York 10014
212.807.7171

Landscape Architect

118 Magazine Street
Cambridge, Massachusetts 02139
617.661.0070
617.661.0064

Coordinating Landscape Architect
LANDSCAPE ARCHITECTURE, INC.
2300 Cottondale Lane, Suite 202
Little Rock, Arkansas 72202
501.374.5610

Civil Engineer
MCLELLAND CONSULTING ENGINEERS
900 W. Markham Street
Little Rock, Arkansas 72201
501.371.0272


Electrical Engineer
CROMWELL ARCHITECTS ENGINEERS
101 South Spring Street
Little Rock, Arkansas 72201
501.372.2900

Marine + Structural Engineers
MOFFATT & NICHOL ENGINEERS
1616 East Millbrook Road, Suite 160
Raleigh, North Carolina 27609
919.761.4628


Fountain
DAN EUSER WATERARCHITECTURE INC.
58 Mackenzie Drive West
Richmond Hill, Ontario L4C 3S2
CANADA
905.884.4178

Playground Design
PLAY SITE ARCHITECTURE
7 Fairway Road
Acton, Massachusetts 01720
978.263.1080

Signage Design
POULIN + MORRIS
286 Spring Street, Sixth Floor
New York, New York 10013
212.676.1332

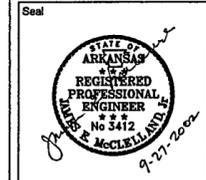

Issue	Date
05 100% Site Package 2 CD	09/27/02
04 90% Site Package 2 CD	08/18/02
03 80% Site Package 2 CD	08/29/02
02 100% Design Development	04/01/02
01 100% Site Package 1 CD	02/15/02

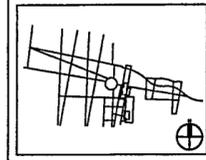

Job No PPA. 9908
HA. CPC0101

Scale 1"=30'-0"

Date SEPTEMBER 27, 2002

Title SITE PACKAGE 2
100% CONSTRUCTION DOCUMENTS
SEWER PROFILES

Sheet No

C306

FOR OFFICIAL USE ONLY