



2 RESERVOIR CONCRETE LAYOUT PLAN  
SCALE 1/4"=1'-0"

NOTE FOR ALL PIPE JET AND LIGHTING SIZES, LOCATIONS, DETAILS AND ANY ASSOCIATED/ADDITIONAL CONCRETE REQUIREMENTS - SEE WF SERIES MECHANICAL AND ELECTRICAL DRAWINGS

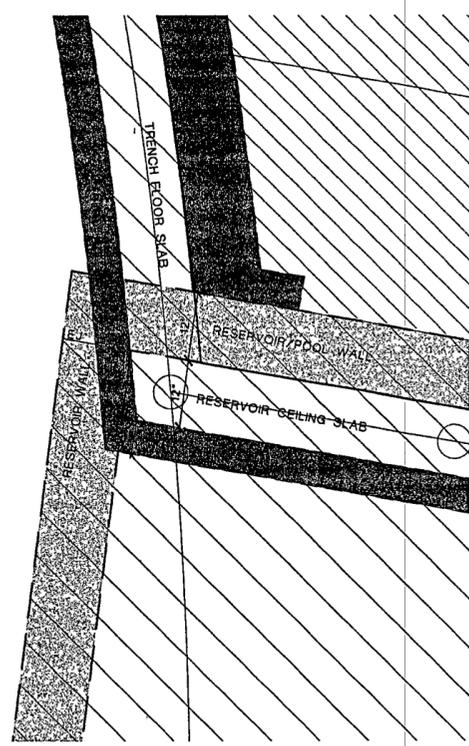

3 RESERVOIR AND TRENCH INTERSECTION PLAN  
SCALE 1"=1'-0"

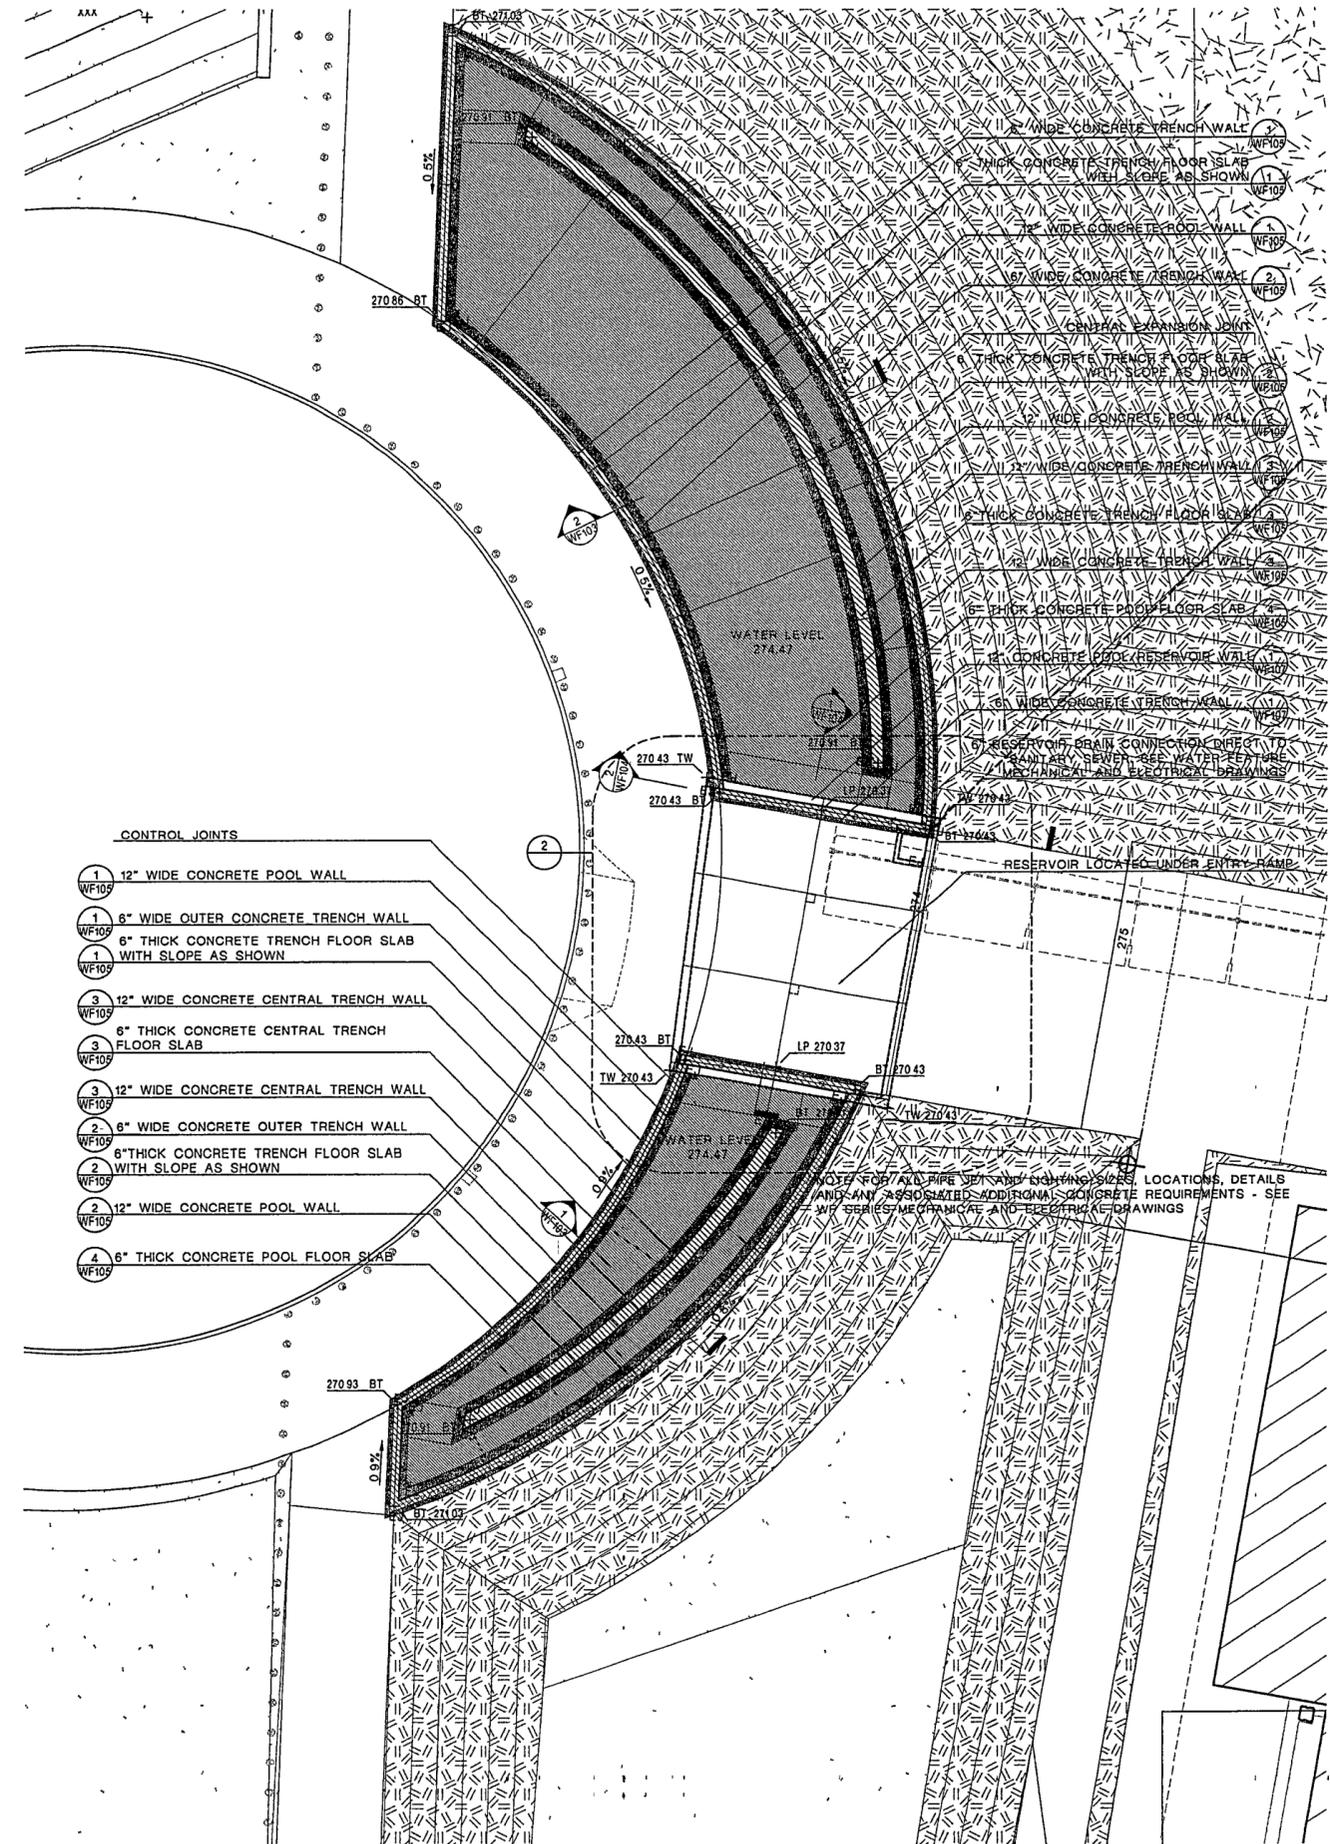

1 WATER FEATURE CONCRETE LAYOUT AND GRADING PLAN  
SCALE 1/8"=1'-0"

NOTE FOR ALL PIPE JET AND LIGHTING SIZES, LOCATIONS, DETAILS AND ANY ASSOCIATED/ADDITIONAL CONCRETE REQUIREMENTS - SEE WF SERIES MECHANICAL AND ELECTRICAL DRAWINGS

**WILLIAM J. CLINTON  
PRESIDENTIAL  
CENTER & PARK**

LITTLE ROCK, ARKANSAS  
Architect  
POLSHEK PARTNERSHIP LLP  
320 West 13th Street  
New York, New York 10014  
212 807 7171

Landscape Architect  
HARCREEVES ASSOCIATES  
118 Magazine Street  
Cambridge, Massachusetts 02139  
617 881 0070  
617 881 0064

Coordinating Landscape Architect  
LANDSCAPE ARCHITECTURE, INC.  
2300 Coltondale Lane, Suite 202  
Little Rock, Arkansas 72202  
501 374 5810

Civil Engineer  
McLELLAND CONSULTING ENGINEERS  
900 W Markham Street  
Little Rock, Arkansas 72201  
501 371 0272


Electrical Engineer  
CROMWELL ARCHITECTS ENGINEERS  
101 South Spring Street  
Little Rock, Arkansas 72201  
501 372-2900

Marine + Structural Engineers  
MOFFATT & NICHOL ENGINEERS  
1618 East Millbrook Road, Suite 160  
Raleigh, North Carolina 27609  
919 781-4828


Fountain  
DAN EUSER WATERARCHITECTURE INC  
58 Mackenzie Drive West  
Richmond Hill, Ontario L4C 3S2  
CANADA  
905 884-4176

Playground Design  
PLAY SITE ARCHITECTURE  
7 Fairway Road  
Acton, Massachusetts 01720  
978 253 1090

Signage Design  
POULIN + MORRIS  
286 Spring Street, Sixth Floor  
New York, New York 10013  
212 875 1332

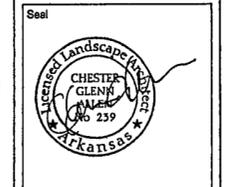


Issue	Date
03 100% Site Package 2 CD	09/27/02
02 90% Site Package 2 CD	08/16/02
01 80% Site Package 2 CD	08/28/02

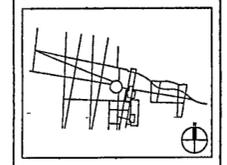

Job No. PPA 8908  
HA CPC0101  
Scale 1/8" = 1'-0"  
Date SEPTEMBER 27, 2002  
Title SITE PACKAGE 2  
100% CONSTRUCTION DOCUMENTS  
WATER FEATURE  
CONCRETE  
LAYOUT PLAN

 Sheet No. **WF102**



FOR OFFICIAL USE ONLY