

**WILLIAM J CLINTON
PRESIDENTIAL
CENTER**

LITTLE ROCK, ARKANSAS

Architect
POLSHKE PARTNERSHIP LLP
320 West 13th Street
New York, New York 10014
212 807 7171

Coordinating Architects
POLK STANLEY YEARY ARCHITECTS LTD
700 South Schiller Street
Little Rock, Arkansas 72201
501 378 0878

WITSELL EVANS RASCO
801 West Third Street
Little Rock, Arkansas 72201
501 374 5300

WOODS GARADINE ARCHITECTS
2200 South Main Street
Little Rock, Arkansas 72206
501 374 4060

Landscape Architects
HARGREAVES ASSOCIATES
118 Magazine Street
Cambridge, Massachusetts 02139
617 861 0070

LANDSCAPE ARCHITECTURE, Inc.
2300 Cottondale Lane Suite 202
Little Rock, Arkansas 72202
501 374 9810

Structural Engineer
LESLIE E. ROBERTSON ASSOC. RLLP
30 Broad Street, 47th Floor
New York, New York 10004
212 750 9000


MEP Engineers
FLACK + KURTZ, Inc.
475 Fifth Avenue
New York, New York 10017
212 532 0600

CROMWELL ARCHITECTS ENGINEERS
101 South Spring Street
Little Rock, Arkansas 72201
501 372 2900

Curtilwall Consultant
R. A. HEINTGES ARCHITECTS
128 Fifth Avenue, 9th Floor
New York, New York 10011
212 652-2968




100% Construction Documents	09/27/02
90% Progress Printing	08/30/02
100% Struct/CD Progress	07/01/02
Bridge Bldg Substructure	06/14/02
100% Steel & Concrete CD	05/15/02
& Architectural CD Progress	
100% Design Development	03/01/02
Issue	Date

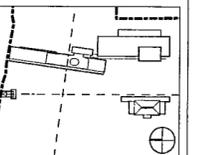

Job No. 9908
Scale 1/80
Date September 27, 2002
Title

SITE PLAN
Sheet No. **A002**

FOR SITE INFORMATION REFER TO HARGREAVES ASSOCIATES CONSTRUCTION DOCUMENTS PACKAGE ISSUED SEPTEMBER 27 2002
FOR PROJECT SURVEY REFER TO DRAWINGS 1902-1905 BY HARGREAVES ASSOCIATES' CONSTRUCTION DOCUMENTS PACKAGE ISSUED SEPTEMBER 27 2002
FOR UTILITY RELOCATION REFER TO MCLELLAND CONSULTING ENGINEERS DUCT BANK CONSTRUCTION DRAWINGS ISSUED DECEMBER 2001 REVISED JANUARY 10, 2002
FOR BUILDING LOCATION WORKPOINTS REFER TO SLAB PLAN 5100B-1 AND 510B-1

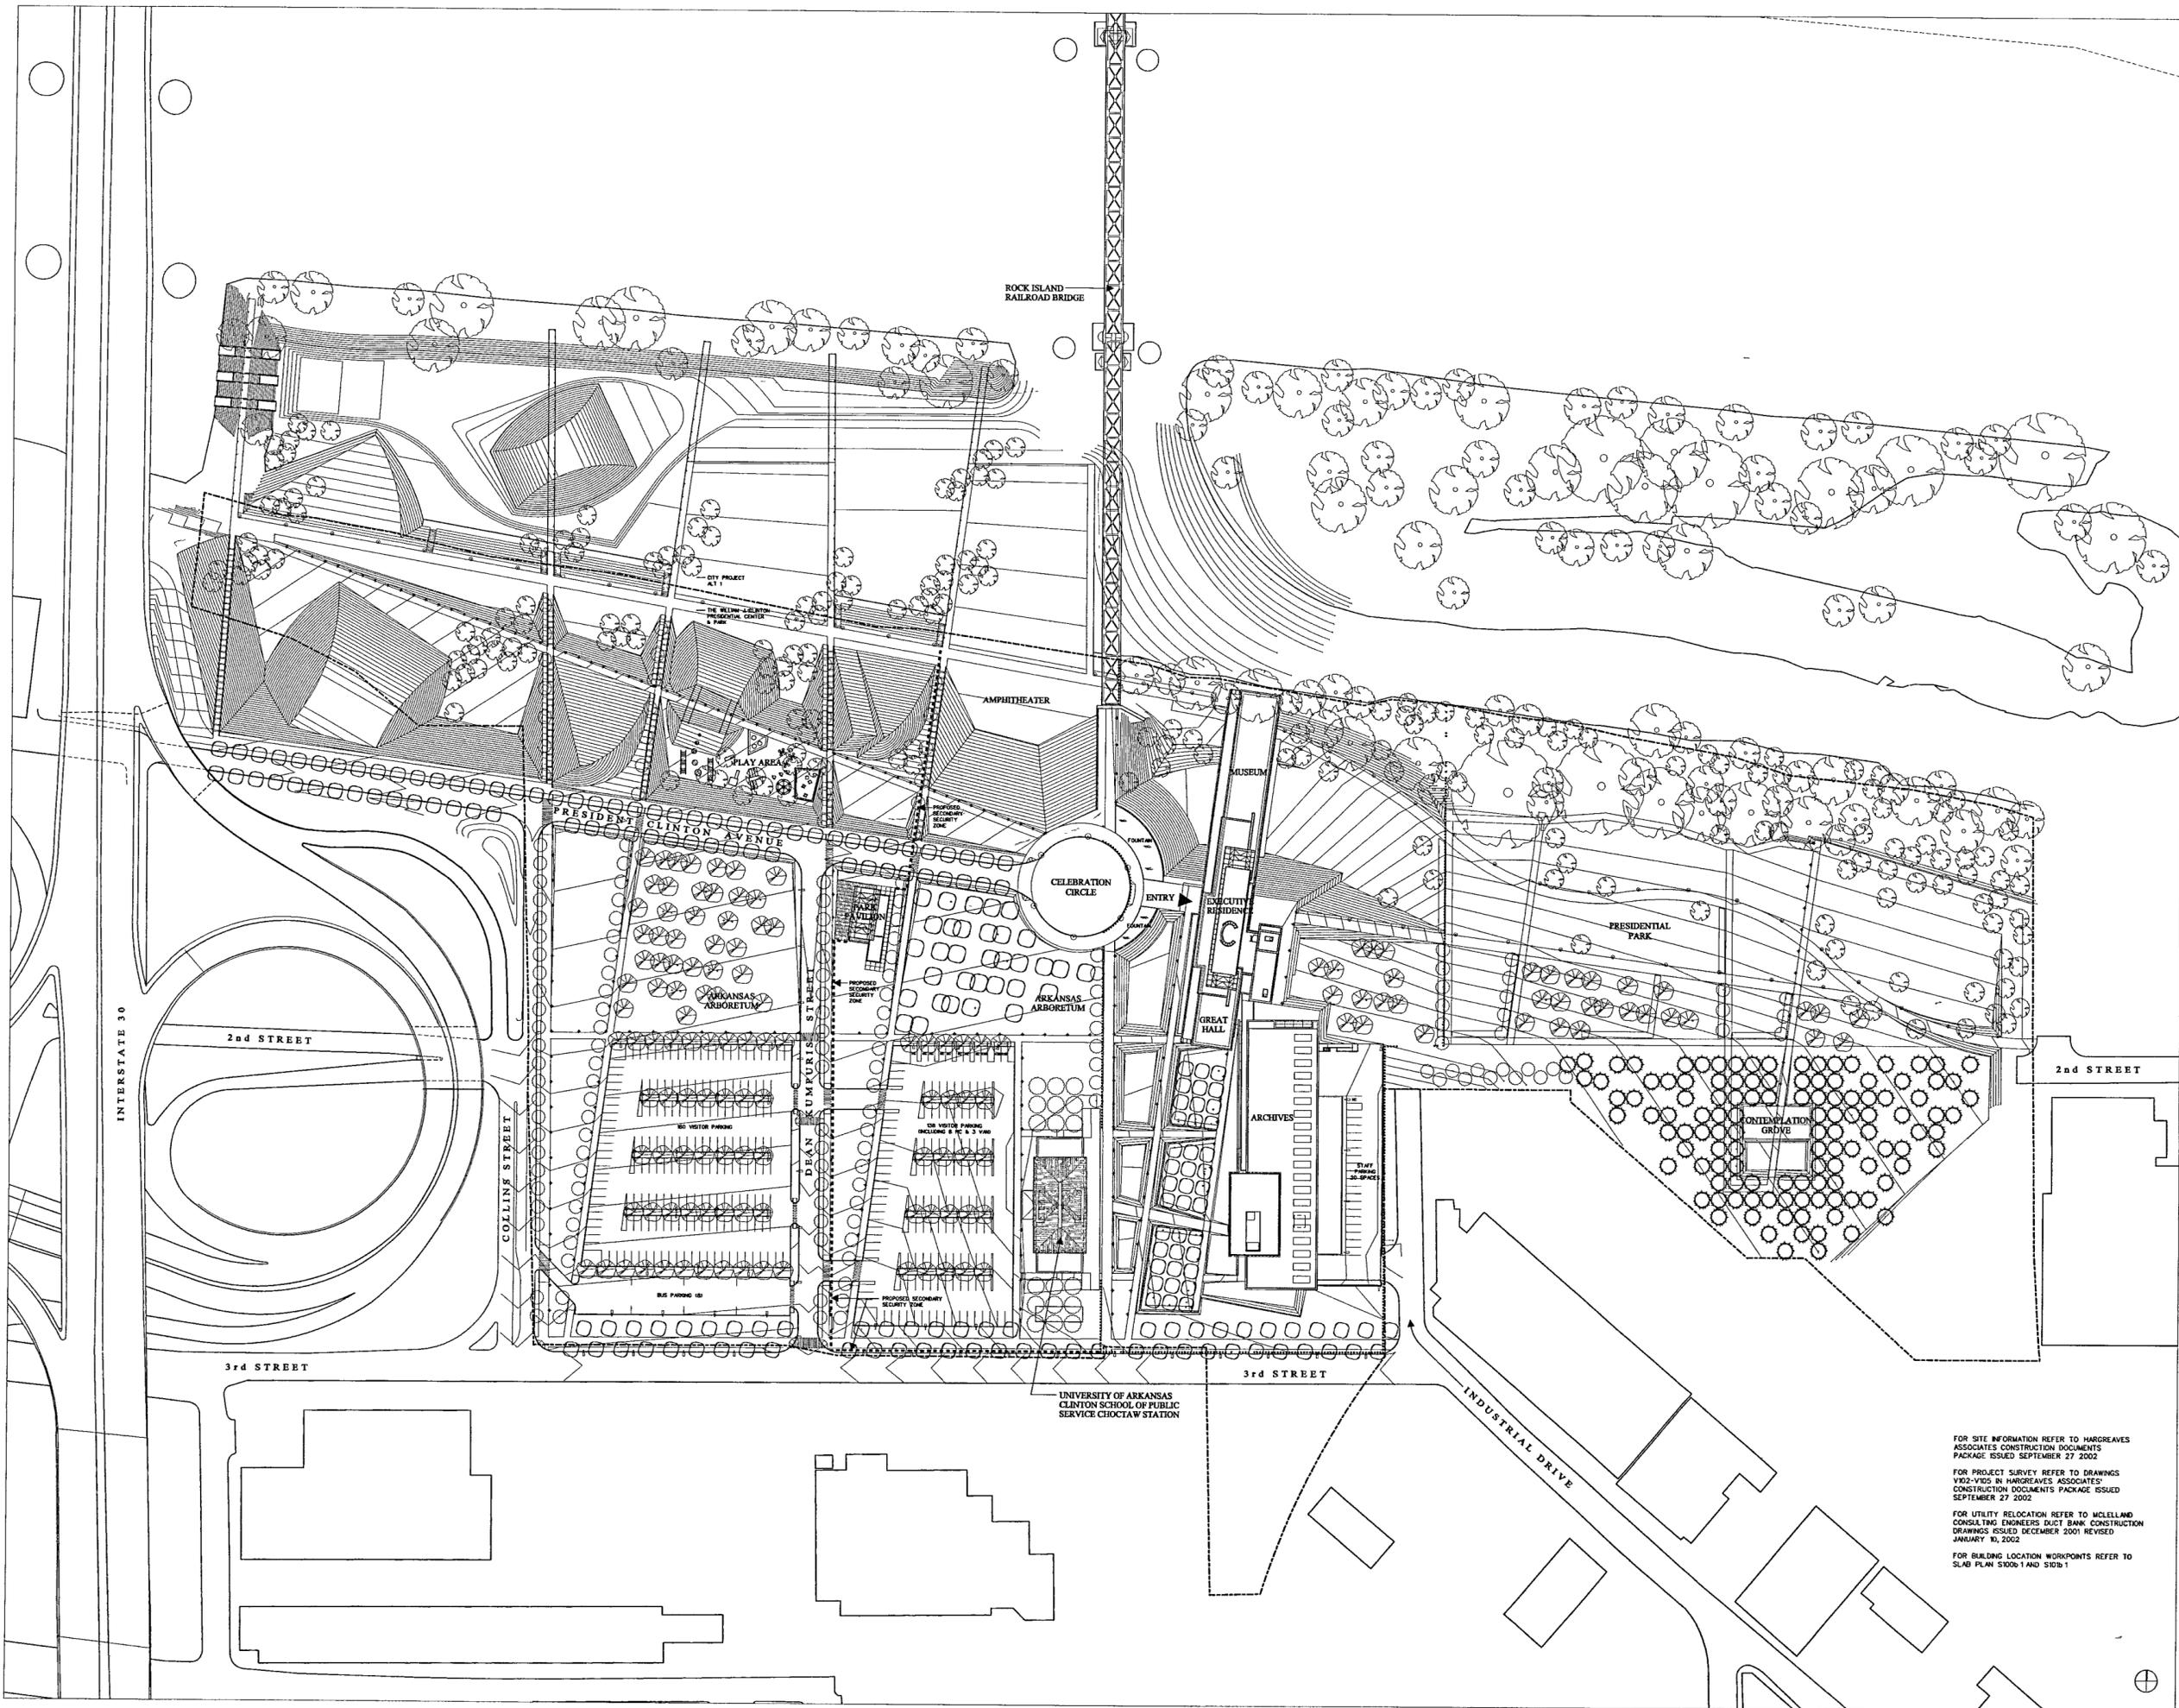

FOR OFFICIAL USE ONLY