

**WILLIAM J CLINTON
PRESIDENTIAL
CENTER**

LITTLE ROCK, ARKANSAS

Architect
POLSHEK PARTNERSHIP LLP
320 West 13th Street
New York, New York 10014
212 807 7171

Coordinating Architects
POLK STANLEY YEARY ARCHITECTS Ltd
700 South Schiller Street
Little Rock, Arkansas 72201
501 378 0878

WITSELL EVANS RASCO
901 West Third Street
Little Rock, Arkansas 72201
501 374 5300

WOODS CARADINE ARCHITECTS
2200 South Main Street
Little Rock, Arkansas 72206
501 374 4060

Landscape Architects
HARGREAVES ASSOCIATES
118 Magazine Street
Cambridge, Massachusetts 02139
617 661 0070


LANDSCAPE ARCHITECTURE Inc
2300 Cottondale Lane Suite 202
Little Rock, Arkansas 72202
501 374 5510

Structural Engineer
LESLIE E ROBERTSON ASSOC RLLP
30 Broad Street, 4th Floor
New York, New York 10004
212 750 9000


MEP Engineers
FLACK + KURTZ Inc
475 Fifth Avenue
New York, New York 10017
212 532 9800

CRONMELL ARCHITECTS ENGINEERS
101 South Spring Street
Little Rock, Arkansas 72201
501 372 2900

Curtainwall Consultant
R. A HEINTGES ARCHITECTS
126 Fifth Avenue, 8th Floor
New York, New York 10011
212 652 2966

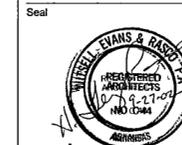

100% Construction Documents	09/27/02
90% Progress Printing	08/30/02
100% Struct/CD Progress	07/01/02
Bridge Bldg Substructure	06/14/02
100% Steel & Concrete CD	05/15/02
& Architectural CD Progress	
100% Design Development	03/01/02
Issue	Date

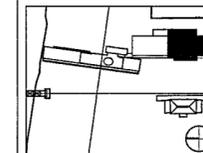

Job No 9908
Scale 1/8" = 1'-0"
Date September 27, 2002

**BASEMENT LEVEL
PARTIAL REFLECTED
CEILING PLAN**

Sheet No

A600d

FOR OFFICIAL USE ONLY

NOTE:


- THESE DRAWINGS SUPPLEMENT INFORMATION ON THE M.E.P. AND SECURITY DRAWINGS AND ARE TO BE USED FOR DIMENSIONAL LOCATION OF ALL M.E.P. AND SECURITY SYSTEMS. ALL M.E.P. AND SECURITY SYSTEMS SCOPE AND CONTENTS SHALL BE FOR M.E.P. AND SECURITY DRAWINGS.
- SEE M.E.P. AND SECURITY DRAWINGS FOR ELECTRICAL, MECHANICAL, FIRE PROTECTION AND SECURITY DEVICE LOCATIONS IN THE FOLLOWING ROOMS: JANITORIES, CLOSETS, ELECTRICAL CLOSETS, TELEPHONE AND DATA CLOSETS, AV STORAGE CLOSETS, STORAGE AND GENERAL STORAGE ROOMS.
- NOTIFY THE ARCHITECT IN THE EVENT OF ANY DISCREPANCIES BETWEEN THE MECHANICAL, ELECTRICAL, FIRE PROTECTION AND SECURITY DRAWINGS AND THE REFLECTED CEILING PLANS. THE ARCHITECTURAL CEILING PLANS SHALL COVER ALL LOCATIONS AND DIMENSIONS OF ALL EXPOSED TO VIEW ITEMS. DO NOT PROCEED UNTIL DISCREPANCIES HAVE BEEN RESOLVED.
- FOR CEILING TYPE AND LOCATION OF FINISH REFER TO FINISH SCHEDULE.
- FOR CEILING HEIGHTS IN STAIRS, SEE STAIR DETAILS.
- START POINT OF CEILING GRID SHALL BE CENTER OF TILE AT CENTER OF ROOM U.O.N.
- WHEN ADDITIONAL CEILING TILE EXCEEDS 3 X3 PROVIDE 2" X 4" ADDITIONAL CEILING TILE TO BE FIELD CUT.
- ALL CEILING MOUNTED DEVICES INCLUDING EXIT SIGNS NOT ADJACENT TO DOORS, SMOKE DETECTORS, LIGHT FIXTURES SHALL BE CENTERED ON CEILING TILE U.O.N.
- ALL FIRE STORES SHALL BE LOCATED 8 1/2" FROM THE ADJACENT DOOR FRAME TO THE CENTERLINE OF THE STORE. U.O.N. OR CENTER OF THE REFLECTED CEILING PLANS OR THE INTERIOR ELEVATIONS.
- STAIR AND RAMP MOUNTED FIXTURES SHALL BE INSTALLED AT HEIGHT BOTTOM OF FIXTURE AS INDICATED IN THE SPECIFICATIONS.

KEY:

EXPOSED AND SEALED SLAB	PLASTER FINISH
PTD GRID	2 X2' CLO. TILES
PERFORATED WOOD ACoustICAL PANEL W/ DATT INSULATION	NOT WASHABLE SURFACE IN ALL KITCHEN/PANTRY AREAS
PARTED ALUMINUM PANEL SYSTEM	PERFORATED METAL ACoustICAL PANEL OR AIR REGISTER WHERE NOTED
EXPOSED AND SEALED WAFFLE SLAB	RISED WOOD ACoustICAL PANEL
ORNAMENTAL GLASS AND METAL CANOPY	ARCHITECTURAL ACoustICAL PANELS
STAINLESS STEEL FINISH	FIELD FINISHED MINERAL FIBER ACoustICAL PANEL OVER GYP. SO. CEILING ASSEMBLY

RCP DEVICE KEY:

○	FLOOR/CEILING OUTLET
□	SPEAKER/STROBE
⊠	GLASS BREAK DETECTOR
⊙	CEL. MTD MOTION DETECTOR
⊙	WALL MTD MOTION DETECTOR
⊙	CEL. MTD SECURITY SPEAKER
⊙	WALL MTD SECURITY SPEAKER
⊙	CEL. MTD AV SPEAKER
⊙	WALL MTD AV SPEAKER
⊙	SECURITY CAMERA
⊙	CLG MTD SMOKE/HEAT DETECTOR
⊙	CLG MTD EXIT
⊙	WALL MTD EXIT
⊙	CLG MTD SPRINKLER HEAD
⊙	WALL MTD SPRINKLER HEAD
⊙	RETURN OUTLET CLG. DIFFUSER
⊙	SUPPLY OUTLET CLG. DIFFUSER
⊙	LINEAR SUPPLY DIFFUSER
⊙	WIRELESS SIGNAL ANTENNA TRANSMITTER
⊙	TELEVISION OUTLET
⊙	CIRCULAR DIFFUSER

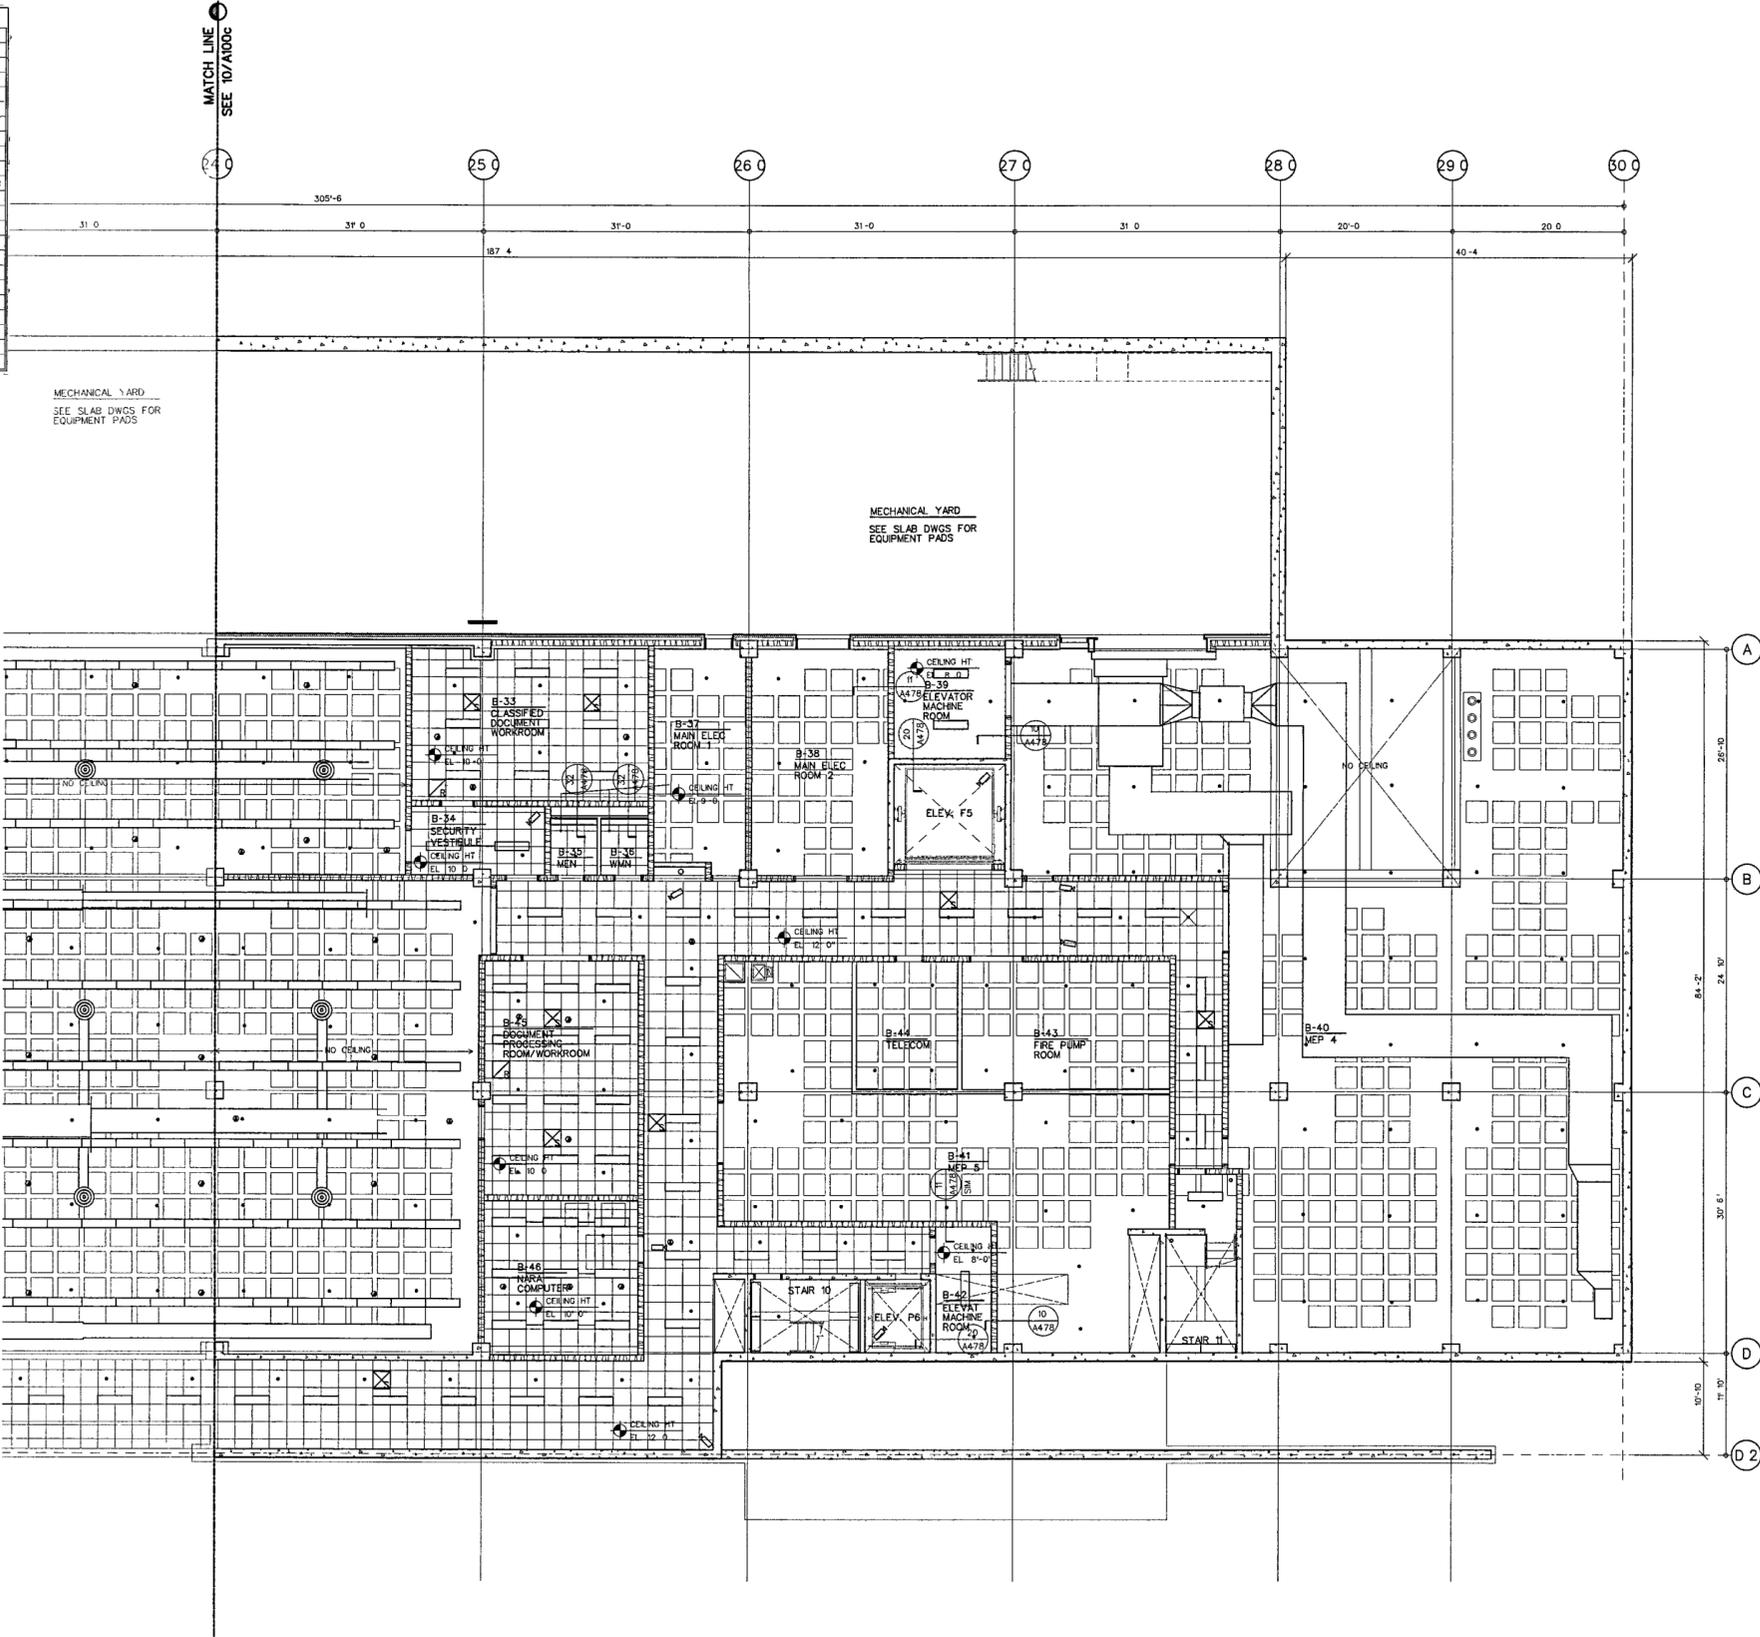

BASEMENT LEVEL PARTIAL REFLECTED CEILING PLAN D

SCALE 1/8" = 1'-0"

RCP-008 DWG 10