


REFLECTED CEILING PLAN AT STAIR 2 LANDING 20  
SCALE 1/8" = 1'-0" RCP-00B DGN

KEY		RCP DEVICE KEY	
[Symbol]	EXPOSED AND SEALED SLAB	[Symbol]	PLASTER FINISH
[Symbol]	PTD GWB	[Symbol]	2 X 2 CLG TILES NOTE WASHABLE SURFACE IN ALL KITCHEN/PANTRY AREAS
[Symbol]	PERFORATED WOOD ACOUSTICAL PANEL W/ BATT INSULATION	[Symbol]	PERFORATED METAL ACOUSTICAL PANEL OR AIR REGISTER WHERE NOTED
[Symbol]	PAINTED ALUMINUM PANEL SYSTEM	[Symbol]	RISED WOOD ACOUSTICAL PANEL
[Symbol]	EXPOSED AND SEALED WAFFLE SLAB	[Symbol]	ARCHITECTURAL ACOUSTICAL PANELS
[Symbol]	ORNAMENTAL GLASS AND METAL CANOPY	[Symbol]	FIELD FINISHED MINERAL FIBER ACOUSTICAL PANEL OVER GYB CEILING ASSEMBLY
[Symbol]	STAINLESS STEEL FINISH	[Symbol]	FLOOR/CEILING OUTLET
		[Symbol]	SPEAKER/STROBE
		[Symbol]	GLASS BREAK DETECTOR
		[Symbol]	CEL. MTD MOTION DETECTOR
		[Symbol]	WALL MTD MOTION DETECTOR
		[Symbol]	CEL. MTD SECURITY SPEAKER
		[Symbol]	WALL MTD SECURITY SPEAKER
		[Symbol]	CEL. MTD AV SPEAKER
		[Symbol]	WALL MTD AV SPEAKER
		[Symbol]	SECURITY CAMERA
		[Symbol]	CLG MTD SMOKE/HEAT DETECTOR
		[Symbol]	CLG MTD EXIT
		[Symbol]	WALL MTD EXIT
		[Symbol]	CLG MTD SPRINKLER HEAD
		[Symbol]	WALL MTD SPRINKLER HEAD
		[Symbol]	RETURN OUTLET CLG DIFFUSER
		[Symbol]	SUPPLY OUTLET CLG DIFFUSER
		[Symbol]	LINEAR SUPPLY DIFFUSER
		[Symbol]	WIRELESS ALARM ANTENNA/TRANSMITTER
		[Symbol]	TELEVISION OUTLET

NOTE  
1. THESE DRAWINGS SUPPLEMENT INFORMATION ON THE M.E.P./P AND SECURITY DRAWINGS AND ARE TO BE USED FOR DIMENSIONAL LOCATION OF ALL M.E.P./P AND SECURITY SYSTEMS. ALL M.E.P./P AND SECURITY SYSTEMS SCOPE AND CONTENTS SHALL BE PER M.E.P. AND SECURITY DRAWINGS.  
2. SEE M.E.P. AND SECURITY DRAWINGS FOR ELECTRICAL, MECHANICAL, FIRE PROTECTION AND SECURITY DEVICE LOCATIONS IN THE FOLLOWING ROOMS: JANITOR'S CLOSETS, ELECTRICAL CLOSETS, TELEPHONE AND DATA CLOSETS, AV STORAGE CLOSETS, KITCHENS AND GENERAL STORAGE ROOMS.  
3. NOTIFY THE ARCHITECT IN THE EVENT OF ANY DISCREPANCIES BETWEEN THE MECHANICAL, ELECTRICAL, PLUMBING, FIRE PROTECTION AND SECURITY DRAWINGS AND THE REFLECTED CEILING PLAN. THE ARCHITECTURAL CEILING PLANS SHALL GOVERN ALL LOCATIONS AND DIMENSIONS OF ALL EXPOSED-TO-VIEW ITEMS. DO NOT PROCEED UNTIL DISCREPANCIES HAVE BEEN RESOLVED.  
4. FOR CEILING TYPE AND LOCATION OF FINISH REFER TO FINISH SCHEDULE.  
5. FOR CEILING HEIGHTS IN STAIRS SEE STAIR DETAILS.  
6. START POINT OF CEILING GRID SHALL BE CENTER OF TILE AT CENTER OF ROOM U.O.N.  
7. WHEN ACOUSTICAL CEILING TILE EXCEEDS 2 X 2 PROVIDE 2 X 4 ACOUSTICAL CEILING TILE TO BE FIELD CUT.  
8. ALL CEILING MOUNTED DEVICES (INCLUDING EXIT SIGNS-NOT ADJACENT TO DOORS, SMOKE DETECTORS, LIGHT FIXTURES) SHALL BE CENTERED ON CEILING TILE U.O.N.  
9. ALL FIRE STROBES SHALL BE LOCATED 6 1/2" FROM THE ADJACENT DOOR FRAME TO THE CENTERLINE OF THE STROBE U.O.N. ON EITHER THE REFLECTED CEILING PLANS OR THE INTERIOR ELEVATIONS.  
10. STEM AND PENDANT MOUNTED FIXTURES SHALL BE INSTALLED AT HEIGHT (BOTTOM OF FIXTURE A.F.F.) INDICATED IN THE SPECIFICATIONS.

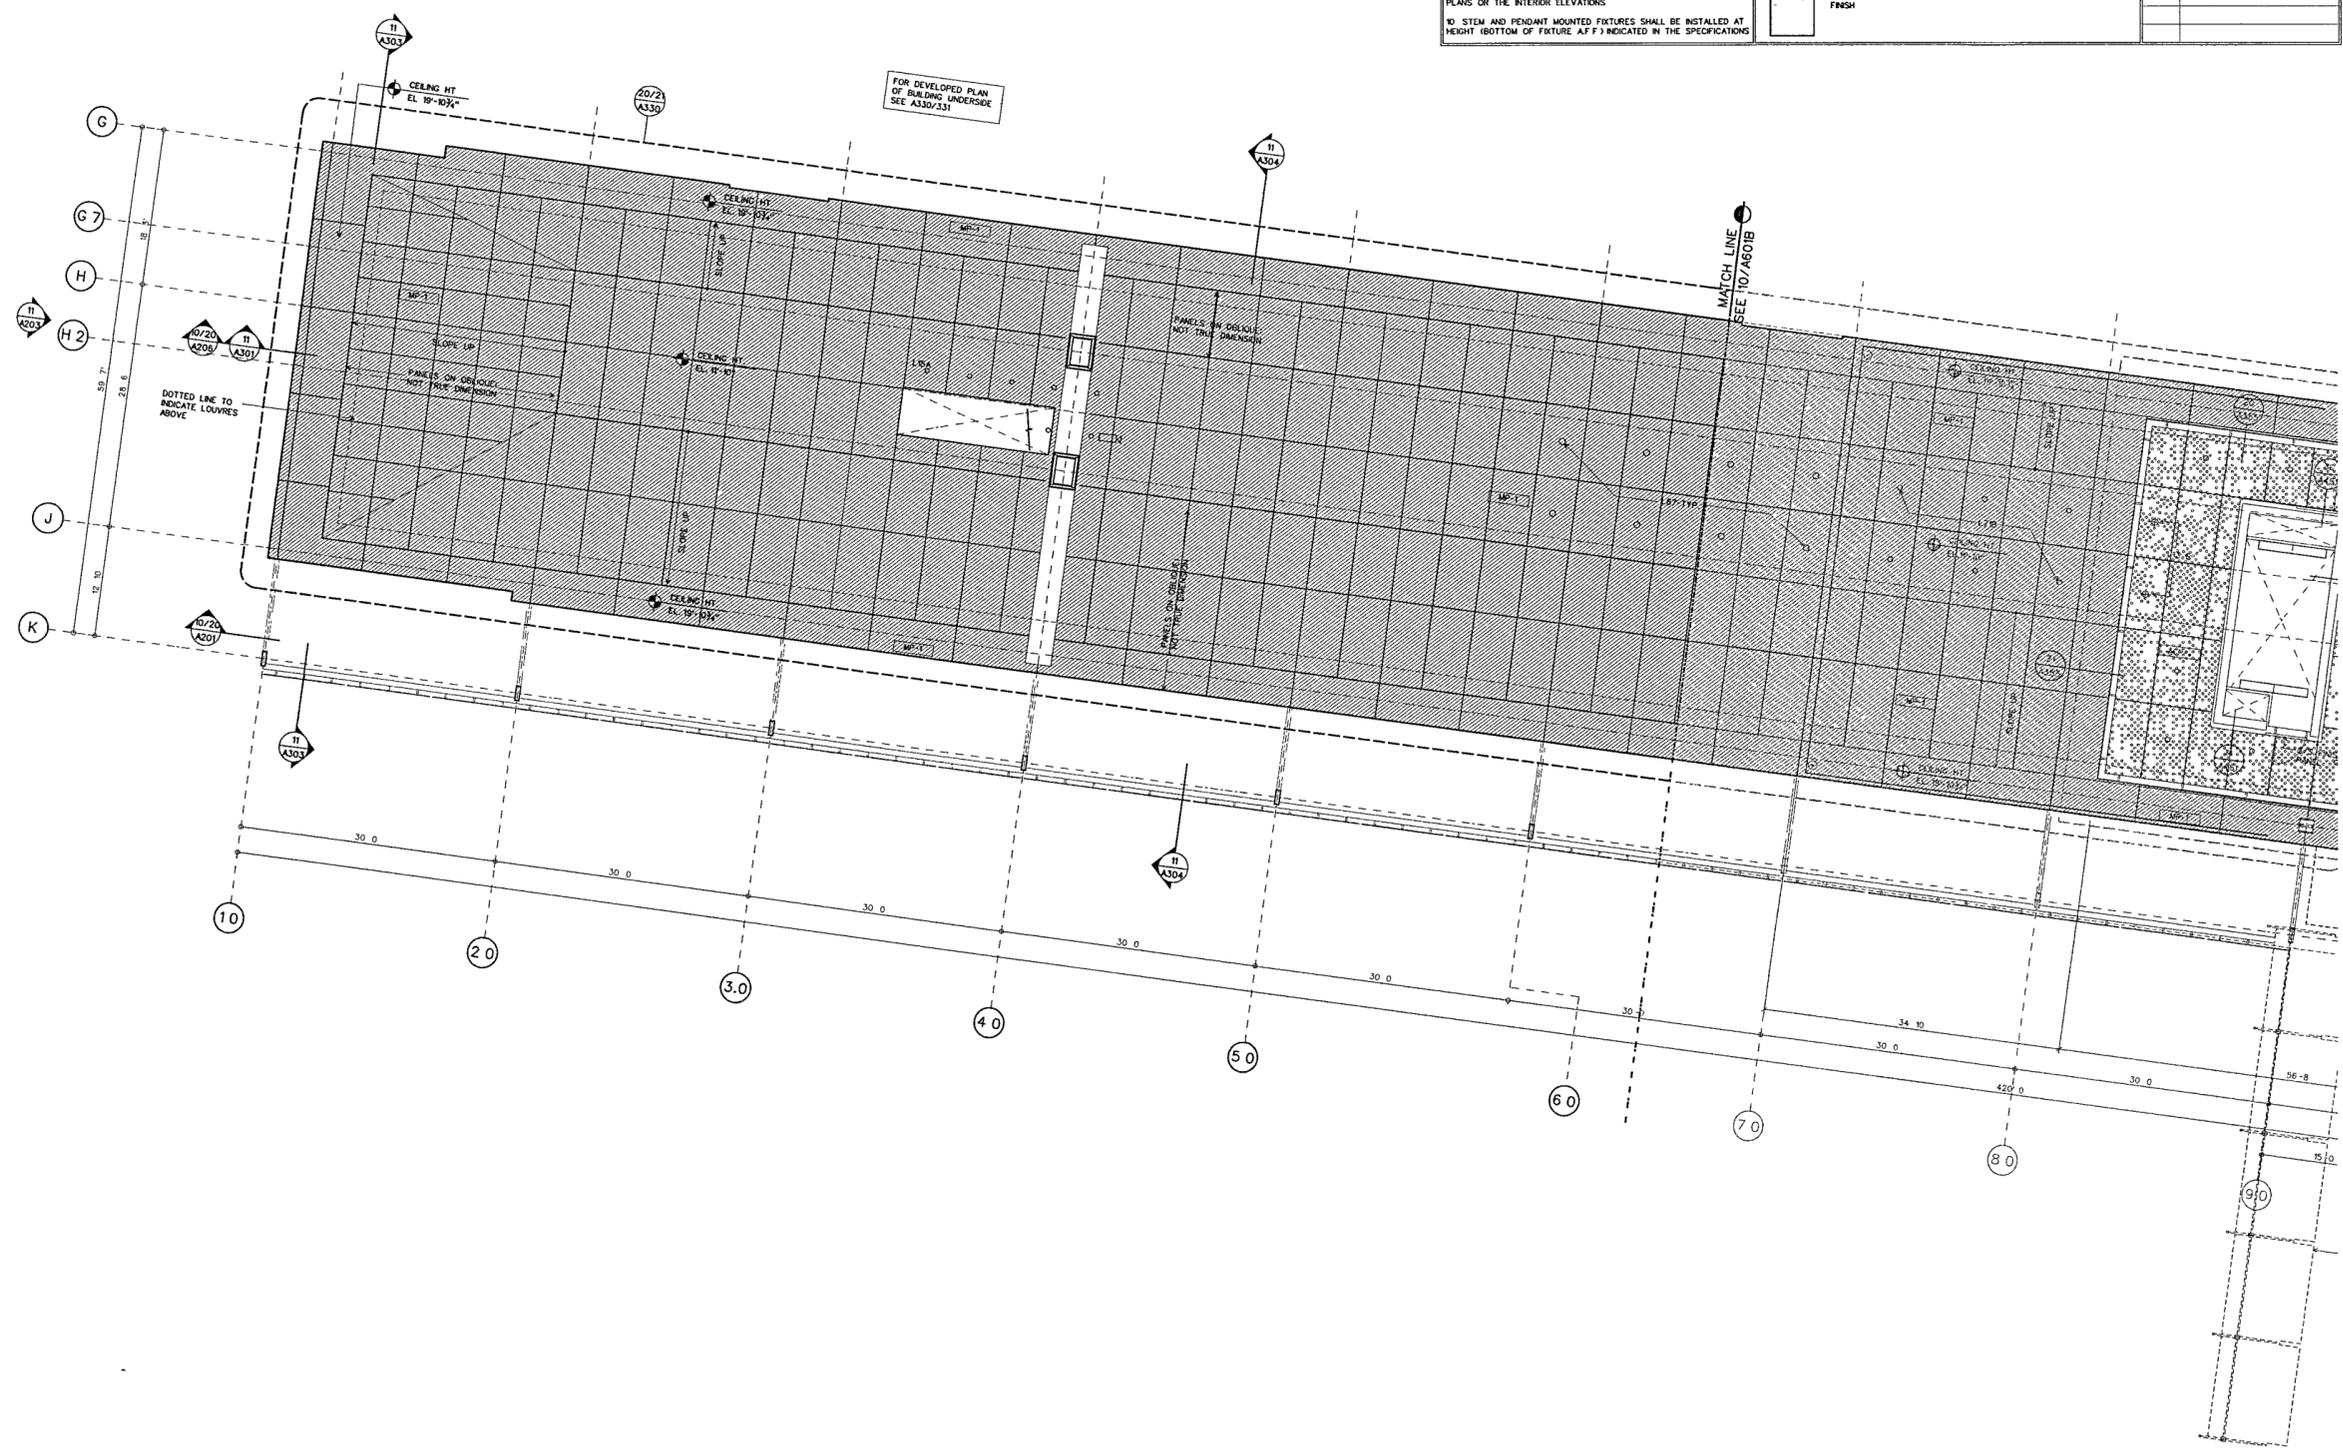

GROUND LEVEL REFLECTED CEILING PLAN A  
SCALE 1/8" = 1'-0"

RCP-01 DGN 10

**WILLIAM J CLINTON  
PRESIDENTIAL  
CENTER**

LITTLE ROCK, ARKANSAS  
Architect  
POLSHAK PARTNERSHIP LLP  
320 West 13th Street  
New York, New York 10014  
212 607 7171  
Coordinating Architects  
POLK STANLEY YEARY ARCHITECTS LTD  
700 South Schiller Street  
Little Rock, Arkansas 72201  
501 378 0878  
WITSELL EVANS RASCO  
901 West Third Street  
Little Rock, Arkansas 72201  
501.374.5300  
WOODS CARADINE ARCHITECTS  
2200 South Main Street  
Little Rock, Arkansas 72206  
501 374 4060


Landscape Architects  
HARGREAVES ASSOCIATES  
116 Magazine Street  
Cambridge, Massachusetts 02139  
617 661 0070  
LANDSCAPE ARCHITECTURE Inc.  
2300 Cottondale Lane Suite 202  
Little Rock, Arkansas 72202  
501 374 5610

Structural Engineer  
LESLIE E. ROBERTSON ASSOC RLLP  
30 Broad Street, 47th Floor  
New York, New York 10004  
212 750 9000


MEP Engineers  
FLACK + KURTZ Inc.  
475 Fifth Avenue  
New York, New York 10017  
212.532.9600

CROMMELL ARCHITECTS ENGINEERS  
101 South Spring Street  
Little Rock, Arkansas 72201  
501 372 2900

Curtainwall Consultant  
R. A. HEINTGES ARCHITECTS  
126 Fifth Avenue 9th Floor  
New York, New York 10011  
212 652-2966

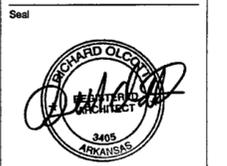

Issue	Date
100% Construction Documents	09/27/02
90% Progress Printing	08/30/02
100% Struct./CD Progress	07/01/02
Bridge Bldg Substructure	06/14/02
100% Steel & Concrete CD	05/15/02
& Architectural CD Progress	
100% Design Development	03/01/02

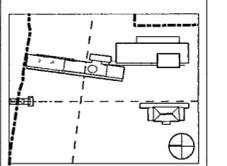

Job No 9908  
Scale 1/8" = 1'-0"  
Date September 27, 2002  
Title  
**GROUND LEVEL  
PARTIAL REFLECTED  
CEILING PLAN**

Sheet No  
**A601a**

FOR OFFICIAL USE ONLY