

**WILLIAM J CLINTON  
PRESIDENTIAL  
CENTER**

LITTLE ROCK, ARKANSAS

Architect  
POLSHEK PARTNERSHIP LLP  
320 West 13th Street  
New York, New York 10014  
212.807.7171

Coordinating Architects  
POLK STANLEY YEARY ARCHITECTS LP  
700 South Schiller Street  
Little Rock, Arkansas 72201  
501.378.0878

WITSELL EVANS RASCO  
901 West Third Street  
Little Rock, Arkansas 72201  
501.374.5300

WOODS CARADINE ARCHITECTS  
2200 South Main Street  
Little Rock, Arkansas 72206  
501.374.4060

Landscape Architects  
HARGREAVES ASSOCIATES  
118 Magazine Street  
Cambridge, Massachusetts 02139  
617.651.0070


LANDSCAPE ARCHITECTURE Inc  
2300 Cottondale Lane Suite 202  
Little Rock, Arkansas 72202  
501.374.5610

Structural Engineer  
LESLIE E. ROBERTSON ASSOC., RLLP  
30 Broad Street 4th Floor  
New York, New York 10004  
212.759.9000


MEP Engineers  
FLACK + KURTZ Inc  
475 Fifth Avenue  
New York, New York 10017  
212.532.9600

CROMWELL ARCHITECTS ENGINEERS  
101 South Spring Street  
Little Rock, Arkansas 72201  
501.372.2900

Curtainwall Consultant  
R. A. HEINTGES ARCHITECTS  
126 Fifth Avenue 9th Floor  
New York, New York 10011  
212.652.2966

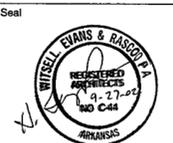

100% Construction Documents	08/27/02
90% Progress Printing	08/30/02
100% Struct./CD Progress	07/11/02
Bridge Bldg Substructure	06/14/02
100% Steel & Concrete CD	05/15/02
& Architectural CD Progress	
100% Design Development	03/01/02
Issue	Date

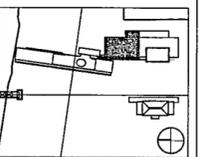

Job No 9908  
Scale 1/8" = 1'-0"  
Date September 27, 2002  
Title

**GROUND LEVEL  
PARTIAL REFLECTED  
CEILING PLAN**

Sheet No  
**A601c**

FOR OFFICIAL USE ONLY

**NOTE**


1. THESE DRAWINGS SUPPLEMENT INFORMATION ON THE M.E.P. P. AND SECURITY DRAWINGS AND ARE TO BE USED FOR DIMENSIONAL LOCATION OF ALL M.E.P. P. AND SECURITY SYSTEMS. ALL M.E.P. P. AND SECURITY SYSTEMS SHALL BE PER M.E.P. P. AND SECURITY DRAWINGS.
2. SEE M.E.P. P. AND SECURITY DRAWINGS FOR ELECTRICAL, MECHANICAL, FIRE PROTECTION AND SECURITY DEVICE LOCATIONS IN THE FOLLOWING ROOMS: JANITOR'S CLOSETS, ELECTRICAL CLOSETS, TELEPHONE AND DATA CLOSETS, AV STORAGE CLOSETS, KITCHENS AND GENERAL STORAGE ROOMS.
3. NOTIFY THE ARCHITECT IN THE EVENT OF ANY DISCREPANCIES BETWEEN THE MECHANICAL, ELECTRICAL, PLUMBING, FIRE PROTECTION AND SECURITY DRAWINGS AND THE REFLECTED CEILING PLAN AND THE ARCHITECTURAL CEILING PLAN. ALL DISCREPANCIES SHALL BE NOTICED AND DIMENSIONS OF ALL EXPOSED TO NEW ITEMS DO NOT PROCEED UNTIL DISCREPANCIES HAVE BEEN RESOLVED.
4. FOR CEILING TYPE AND LOCATION OF FINISH, REFER TO FINISH SCHEDULE.
5. FOR CEILING HEIGHTS IN STAIRS, SEE STAIR DETAILS.
6. START POINT OF CEILING GRID SHALL BE CENTER OF TILE AT CENTER OF ROOM U.O.M.
7. WHEN ADDITIONAL CEILING TILE EXCEEDS 3' X 3' PROVIDE 1/2" X 1/2" ACoustICAL CEILING TILE TO BE FIELD CUT.
8. ALL CEILING MOUNTED DEVICES INCLUDING EXISTING NOT MOUNTED TO HOOKS/BRACKETS DETECTORS LIGHT FIXTURES SHALL BE CENTERED ON CEILING T.E.U.M.
9. ALL THE STROBES SHALL BE LOCATED 6" FROM THE MOUNTING DOOR FRAME TO THE CENTERLINE OF THE STROBE IS IN EITHER THE REFLECTED CEILING PLANE OR THE MIRROR ELEVATIONS.
10. STEEL AND PENDANT MOUNTED FIXTURES SHALL BE NOTICED AT HEIGHT (BOTTOM OF FIXTURE A.F.E.) INDICATED IN THE SPECIFICATIONS.

**KEY**

EXPOSED AND SEALED SLAB	PLASTER FINISH
PTD CURB	2" X 2" G.I. TILES
PERFORATED WOOD ACoustICAL PANEL W/ BATT INSULATION	PERFORATED METAL ACoustICAL PANEL ON AIR REGISTER WHERE NOTED
PAINTED ALUMINUM PANEL SYSTEM	NEEDS WOOD ACoustICAL PANEL
EXPOSED AND SEALED WAFFLE SLAB	ARCHITECTURAL ACoustICAL PANELS
ORNAMENTAL GLASS AND METAL CANOPY	FIELD FINISHED AERIAL FEEDER ACoustICAL PANEL OVER GIP OR CEILING ASSEMBLY
STAINLESS STEEL FINISH	

**RCP DEVICE KEY**

○	FLOOR/CEILING OUTLET
⊠	SPEAKER/STROBE
⊞	GLASS BREAK DETECTOR
⊚	CEL. MTD. MOTION DETECTOR
⊙	WALL MTD. MOTION DETECTOR
⊛	CEL. MTD. SECURITY SPEAKER
⊜	WALL MTD. SECURITY SPEAKER
⊝	CEL. MTD. AV SPEAKER
⊞	WALL MTD. AV SPEAKER
⊟	SECURITY CAMERA
⊠	CEL. MTD. SMOKE/HEAT DETECTOR
⊡	CEL. MTD. EXIT
⊢	WALL MTD. EXIT
⊣	CEL. MTD. SPRINKLER HEAD
⊤	WALL MTD. SPRINKLER HEAD
⊥	RETURN OUTLET CLG. DIFFUSER
⊦	SUPPLY OUTLET CLG. DIFFUSER
⊧	LINEAR SUPPLY DIFFUSER
⊨	WIRELESS PLAIN ANTENNA/TRANSMITTER
⊩	TELEVISION OUTLET
⊪	CIRCULAR DIFFUSER

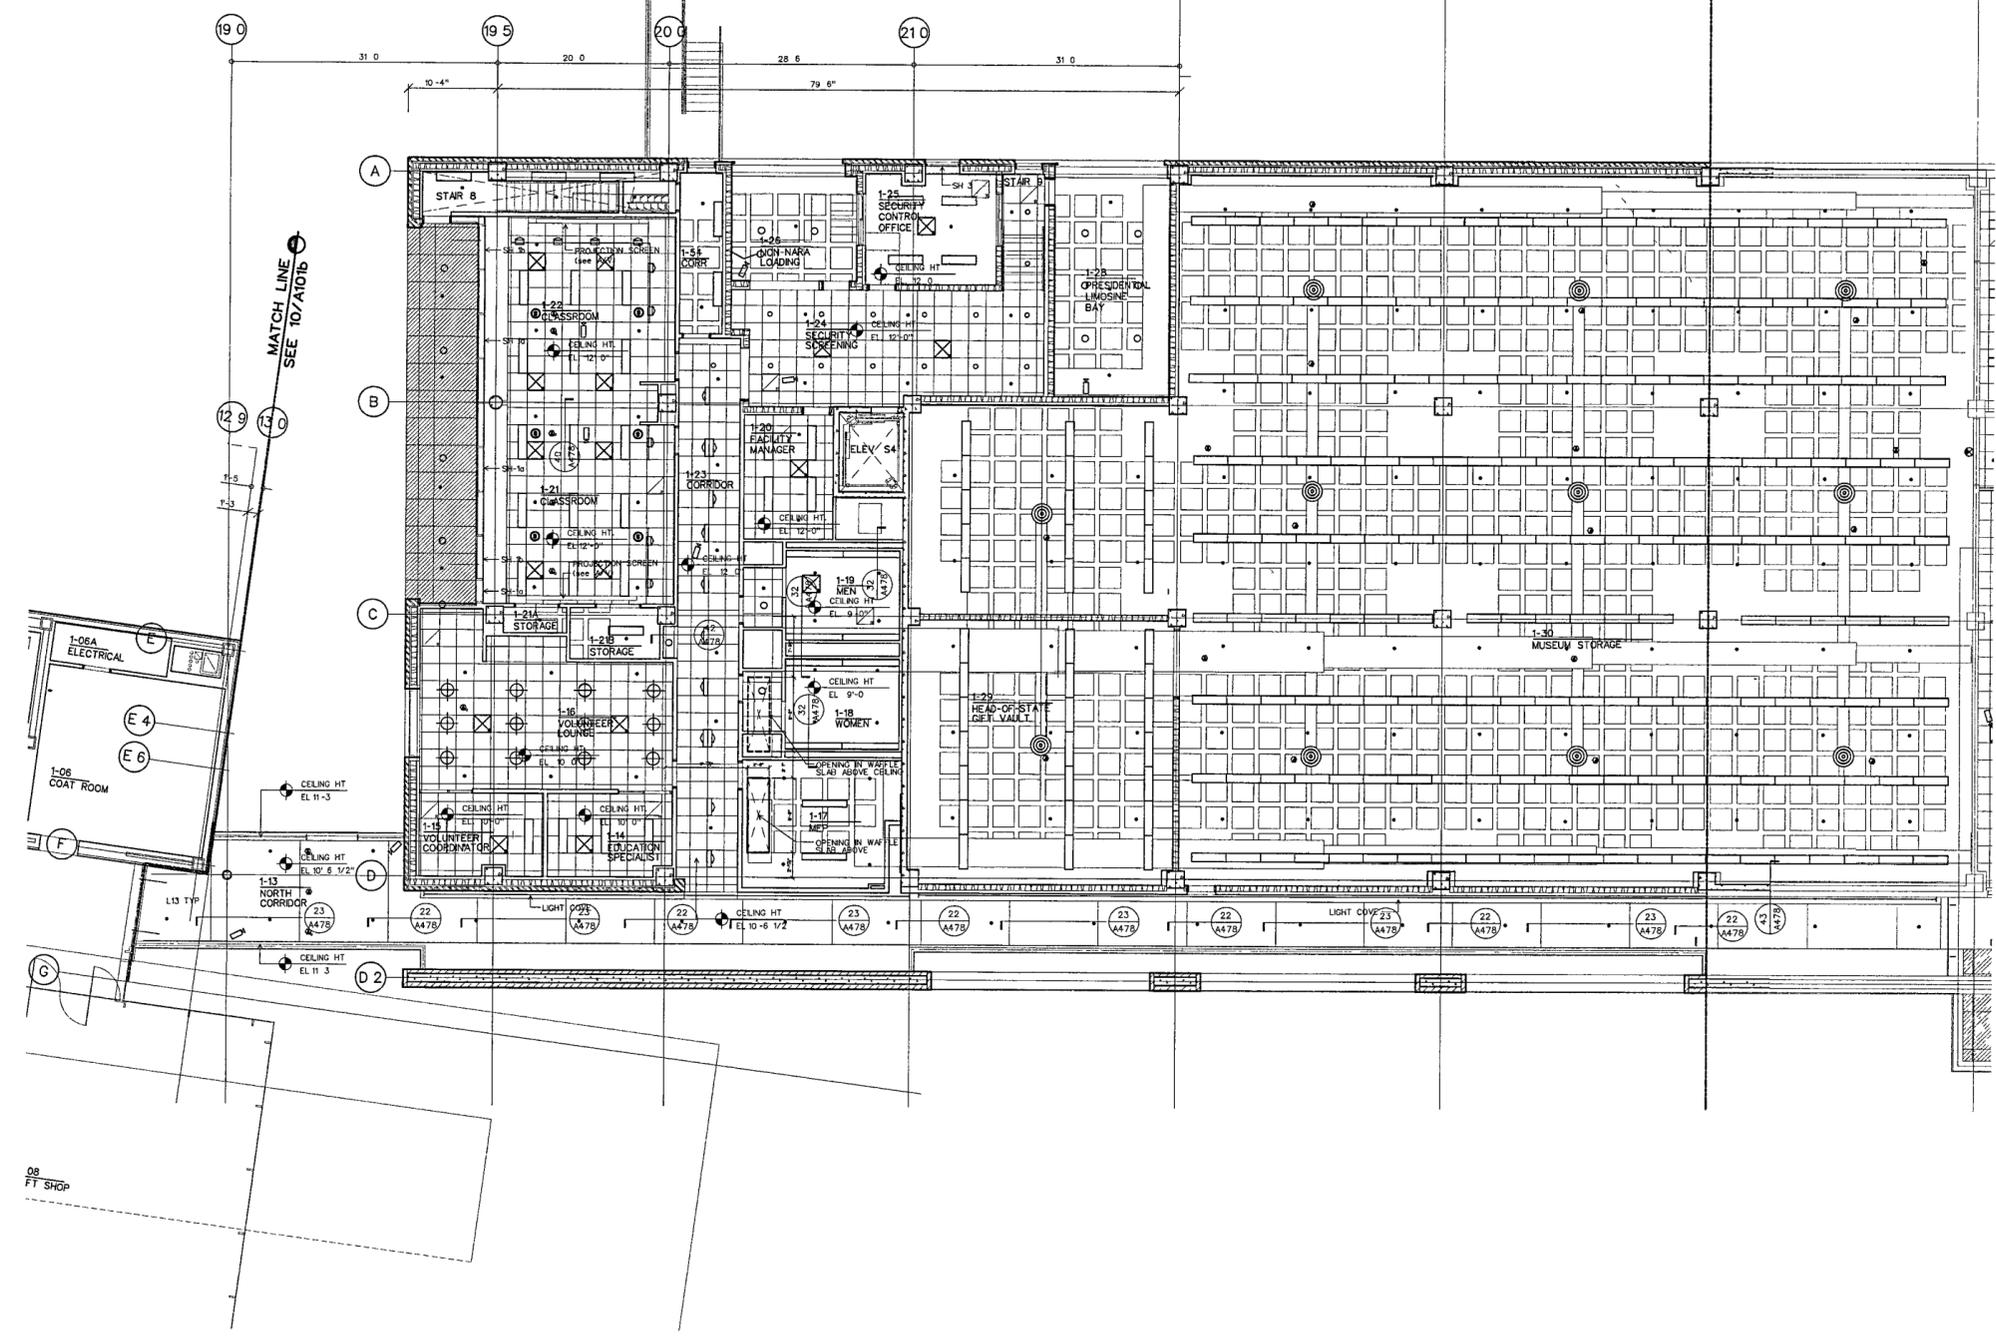

GROUND FLOOR PARTIAL REFLECTED CEILING PLAN C  
SCALE 1/8" = 1'-0"

RCP-01.dwg 10