


NOTE	KEY	RCP DEVICE KEY
1. THESE DRAWINGS SUPPLEMENT INFORMATION ON THE M.E.P. AND SECURITY DRAWINGS AND ARE TO BE USED FOR DIMENSIONAL LOCATION OF ALL M.E.P. AND SECURITY SYSTEMS. ALL M.E.P. AND SECURITY SYSTEMS SCHEMATIC AND CONTENTS SHALL BE PER M.E.P. AND SECURITY DRAWINGS.	EXPOSED AND SEALED SLAB	FLOOR/CEILING OUTLET
2. SEE M.E.P. AND SECURITY DRAWINGS FOR ELECTRICAL, MECHANICAL, FIRE PROTECTION AND SECURITY DEVICE LOCATIONS IN THE FOLLOWING ROOMS: JANITORY CLOSETS, ELECTRICAL CLOSETS, TELEPHONE AND DATA CLOSETS, AV STORAGE CLOSETS, STORAGE AND GENERAL STORAGE ROOMS.	PTD. GWS	SPEAKER/SPEAKER
3. NOTIFY THE ARCHITECT IN THE EVENT OF ANY DISCREPANCIES BETWEEN THE MECHANICAL, ELECTRICAL, PLUMBING, FIRE PROTECTION AND SECURITY DRAWINGS AND THE REFLECTED CEILING PLANS. THE ARCHITECTURAL, CEILING AND SOUL, COVER ALL LOCATIONS AND DIMENSIONS OF ALL EXPOSED TO VIEW ITEMS. DO NOT PROCEED UNTIL DISCREPANCIES HAVE BEEN RESOLVED.	PERFORATED WOOD ACoustICAL PANEL W/ BATT INSULATION	GLASS BREAK DETECTOR
4. FOR CEILING TYPE AND LOCATION OF FINISH REFER TO FINISH SCHEDULE.	PERFORATED METAL ACoustICAL PANEL	CEL. MTD MOTION DETECTOR
5. FOR CEILING HEIGHTS IN STAIRS SEE STAIR DETAILS.	PAINTED ALUMINUM PANEL SYSTEM	WALL MTD MOTION DETECTOR
6. START POINT OF CEILING GRID SHALL BE CENTER OF THE AT CENTER OF ROOM U.O.N.	EXPOSED AND SEALED WATTLE SLAB	CEL. MTD SECURITY SPEAKER
7. WHEN ACoustICAL CEILING TILE EXCEEDS 2 X2 PROVIDE 2 X 4 ACoustICAL CEILING TILE TO BE TIED OUT.	ORNAMENTAL GLASS AND METAL CANOPY	WALL MTD AV SPEAKER
8. ALL CEILING MOUNTED DEVICES INCLUDING EXIT SIGNS NOT ADJACENT TO ROOMS, SMOKE DETECTORS, LIGHT FIXTURES SHALL BE CENTERED ON CEILING TILE U.O.N.	STAINLESS STEEL FINISH	WALL MTD AV SPEAKER
9. ALL FIRE STROBES SHALL BE LOCATED 6" FROM THE ADJACENT DOOR FRAME TO THE CENTERLINE OF THE STROBE U.O.N. ON EITHER THE REFLECTED CEILING PLANS OR THE INTERIOR ELEVATIONS.		SECURITY CAMERA
10. STEIN AND PENDANT MOUNTED FIXTURES SHALL BE INSTALLED AT HEIGHT INDICATED BY THE SPECIFICATIONS.		CEL. MTD SMOKE/HEAT DETECTOR
		CEL. MTD EXIT
		WALL MTD EXIT
		CEL. MTD SPRINKLER HEAD
		WALL MTD SPRINKLER HEAD
		RETURN OUTLET CLG. DIFFUSER
		SUPPLY OUTLET CLG. DIFFUSER
		LINEAR SUPPLY DIFFUSER
		WIRELESS PHONE ANTENNA/TRANSMITTER
		TELEVISION OUTLET
		CIRCULAR DIFFUSER

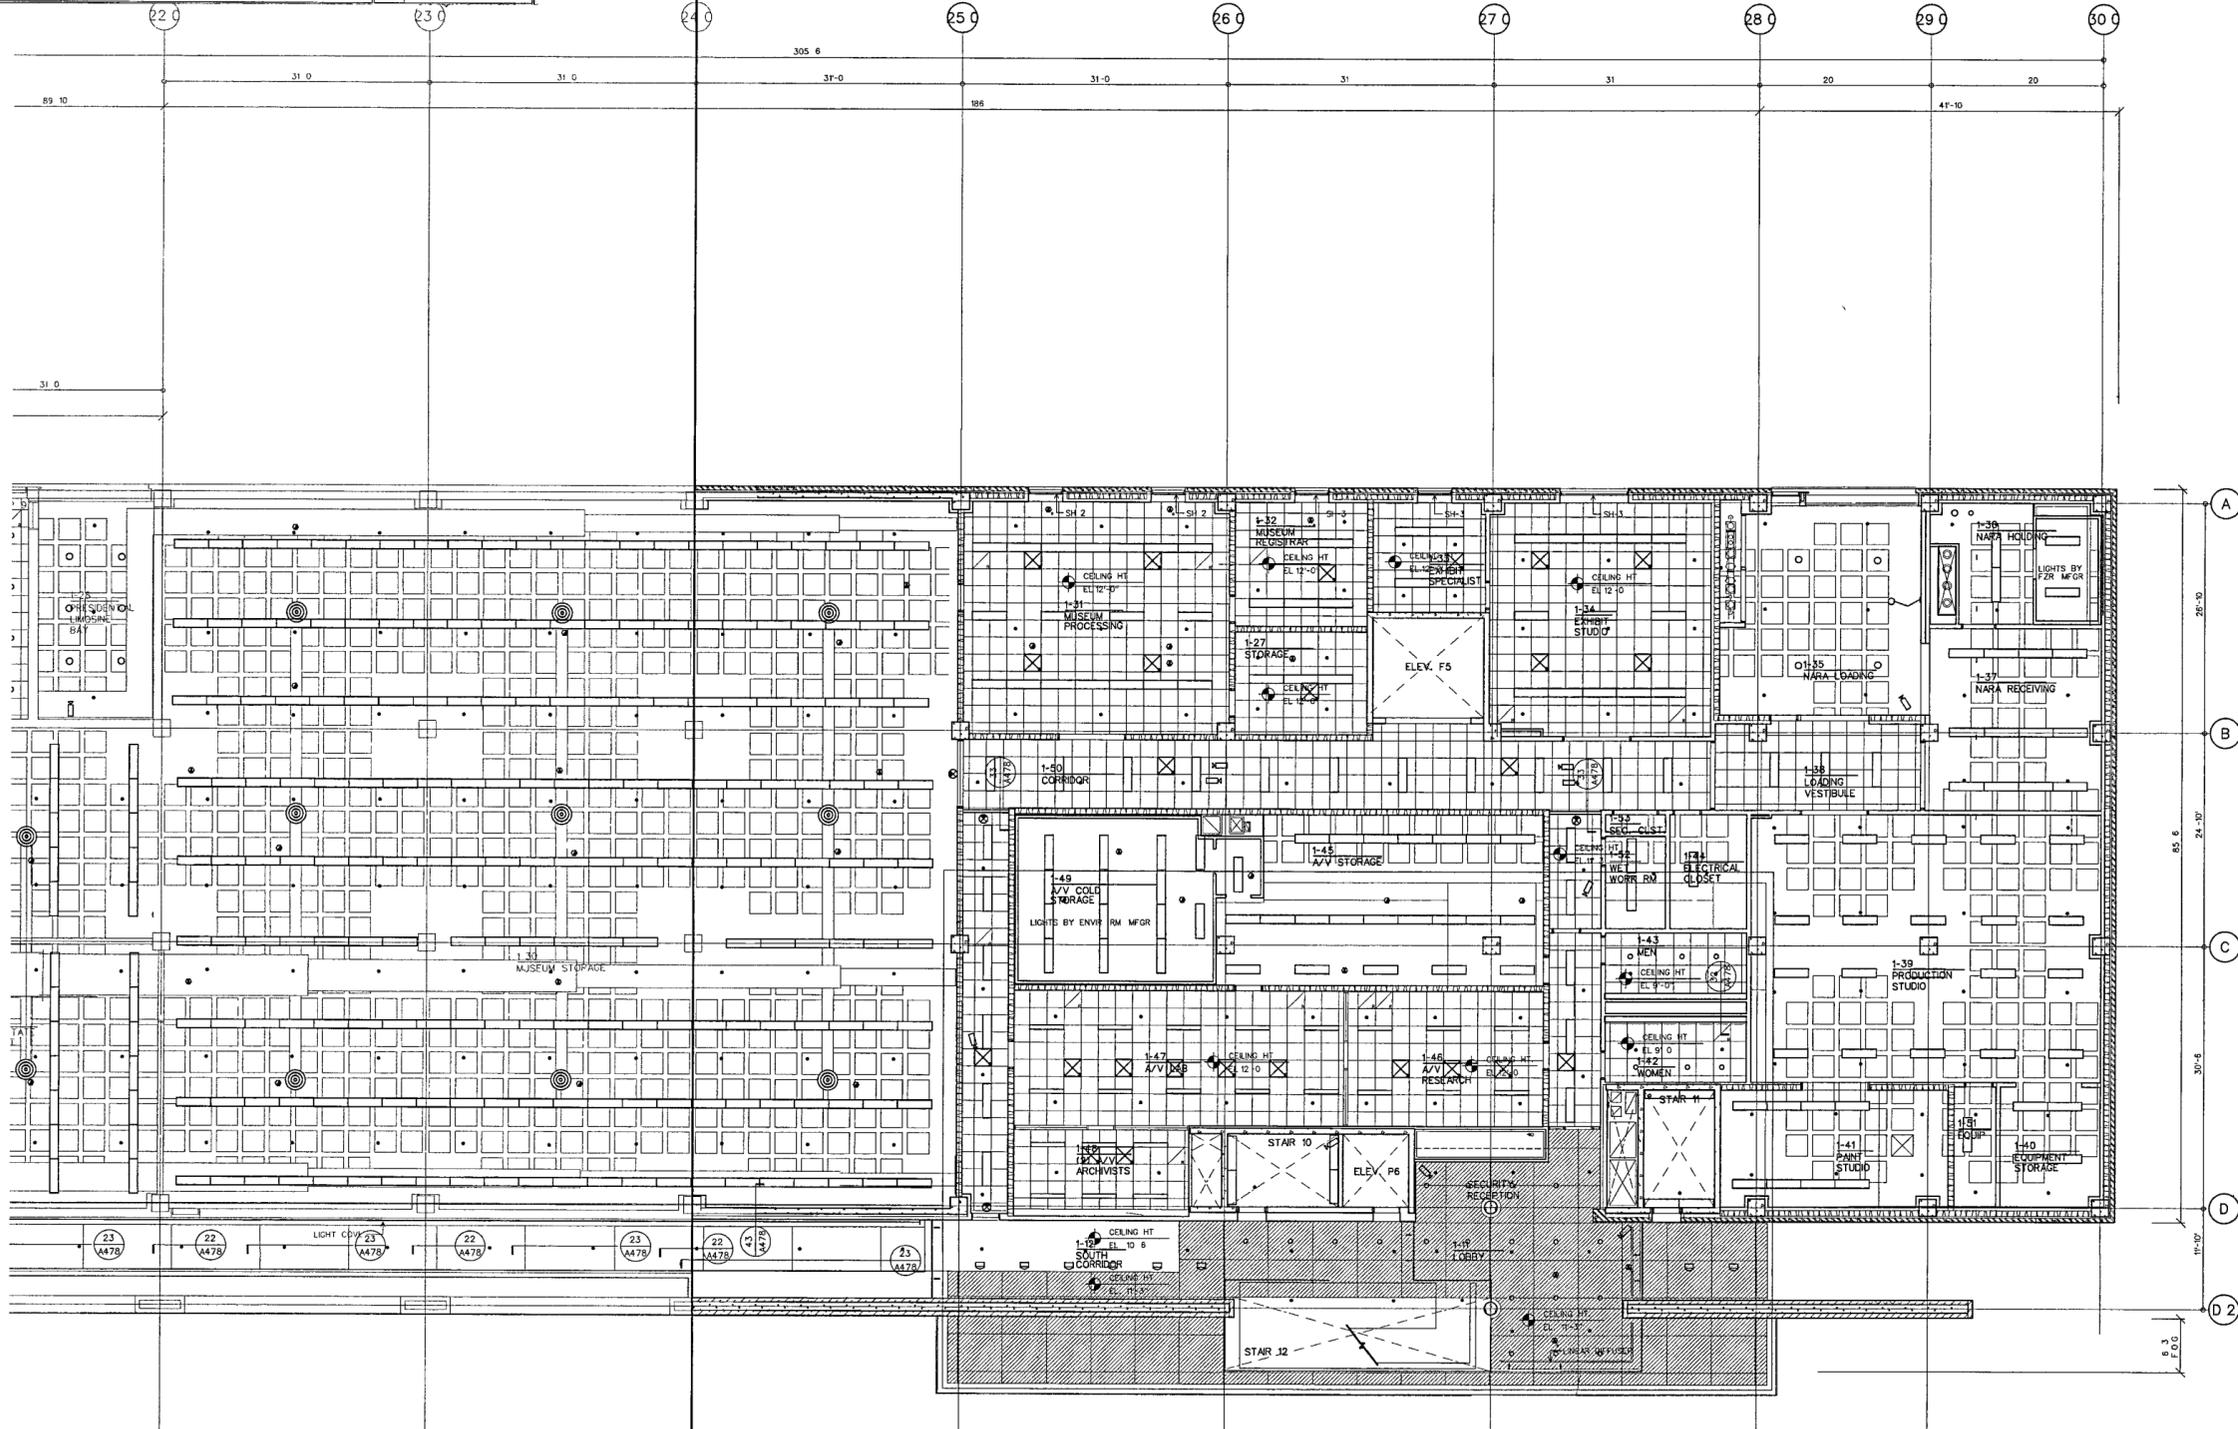

MATCH LINE SEE 107A101C

GROUND LEVEL PARTIAL REFLECTED CEILING PLAN D
SCALE 1/8" = 1'-0"

**WILLIAM J CLINTON
PRESIDENTIAL
CENTER**

LITTLE ROCK ARKANSAS

Architect
POLSHEK PARTNERSHIP LLP
320 West 13th Street
New York, New York 10014
212 807 7171

Coordinating Architects
POLK STANLEY YEARY ARCHITECTS LTD
700 South Scholar Street
Little Rock, Arkansas 72201
501 378 0878

WITSELL EVANS RASCO
901 West Third Street
Little Rock, Arkansas 72201
501 374 5300

WOODS CARADINE ARCHITECTS
2200 South Main Street
Little Rock, Arkansas 72206
501 374 4060

Landscape Architects
HARGREAVES ASSOCIATES
119 Magazine Street
Cambridge Massachusetts 02139
617 661 0070


LANDSCAPE ARCHITECTURE Inc.
2300 Cottondale Lane Suite 202
Little Rock, Arkansas 72202
501 374 5610

Structural Engineer
LESLIE E. ROBERTSON ASSOC. RLLP
30 Broad Street 47th Floor
New York, New York 10004
212 750 9000


MEP Engineers
FLACK + KURTZ Inc
475 Fifth Avenue
New York, New York 10017
212 532 6600

CROMWELL ARCHITECTS ENGINEERS
101 South Spring Street
Little Rock Arkansas 72201
501 372 2900

Curtainwall Consultant
R. A. HEINTGES ARCHITECTS
126 Fifth Avenue 9th Floor
New York, New York 10011
212 652 2966

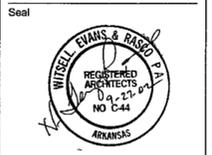

100% Construction Documents	09/27/02
90% Progress Printing	08/30/02
100% Struct./CD Progress	07/01/02
Bridge Bldg Substructure	09/14/02
100% Steel & Concrete CD	05/15/02
& Architectural CD Progress	
100% Design Development	03/01/02
Issue	Date

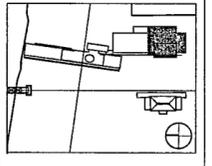

Job No 9908
Scale 1/8" = 1'-0"
Date September 27 2002
Title

**GROUND LEVEL
PARTIAL REFLECTED
CEILING PLAN**

Sheet No
A601d

FOR OFFICIAL USE ONLY