

**NOTE**


- 1 THESE DRAWINGS SUPPLEMENT INFORMATION ON THE M.E.P./P AND SECURITY DRAWINGS AND ARE TO BE USED FOR DIMENSIONAL LOCATION OF ALL M.E.P./P AND SECURITY SYSTEMS. ALL M.E.P./P AND SECURITY SYSTEMS SCOPE AND CONTENTS SHALL BE PER M.E.P. AND SECURITY DRAWINGS.
- 2 SEE M.E.P. AND SECURITY DRAWINGS FOR ELECTRICAL, MECHANICAL, FIRE PROTECTION AND SECURITY DEVICE LOCATIONS IN THE FOLLOWING ROOMS: JANITOR'S CLOSETS, ELECTRICAL CLOSETS, TELEPHONE AND DATA CLOSETS, AV STORAGE CLOSETS, KITCHENS AND GENERAL STORAGE ROOMS.
- 3 NOTIFY THE ARCHITECT IN THE EVENT OF ANY DISCREPANCIES BETWEEN THE MECHANICAL, ELECTRICAL, PLUMBING, FIRE PROTECTION, AND SECURITY DRAWINGS AND THE REFLECTED CEILING PLANS AND THE ARCHITECTURAL CEILING PLANS SHALL COVER ALL LOCATIONS AND DIMENSIONS OF ALL EXPOSED-TO-VIEW ITEMS. DO NOT PROCEED UNTIL DISCREPANCIES HAVE BEEN RESOLVED.
- 4 FOR CEILING TYPE AND LOCATION OF FINISH REFER TO FINISH SCHEDULE.
- 5 FOR CEILING HEIGHTS IN STAIRS, SEE STAIR DETAILS.
- 6 START POINT OF CEILING GRID SHALL BE CENTER OF TILE AT CENTER OF ROOM U.O.N.
- 7 WHEN ACOUSTICAL CEILING TILE EXCEEDS 2 X 2 PROVIDE 2 X 4 ACOUSTICAL CEILING TILE TO BE FIELD CUT.
- 8 ALL CEILING MOUNTED DEVICES (INCLUDING EXIT SIGNS NOT ADJACENT TO DOORS, SMOKE DETECTORS, LIGHT FIXTURES) SHALL BE CENTERED ON CEILING TILE U.O.N.
- 9 ALL FIRE STROKES SHALL BE LOCATED 6" FROM THE ADJACENT DOOR FRAME TO THE CENTERLINE OF THE STROBE U.O.N. ON EITHER THE REFLECTED CEILING PLANS OR THE INTERIOR ELEVATIONS.
- 10 STEM AND PENDANT MOUNTED FIXTURES SHALL BE INSTALLED AT HEIGHT (BOTTOM OF FIXTURE AFF) INDICATED IN THE SPECIFICATIONS.

**KEY**

	EXPOSED AND SEALED SLAB		PLASTER FINISH
	PTD GWB		2 X 2 CLG TILES NOTE WASHABLE SURFACE IN ALL KITCHEN/PANTRY AREAS
	PERFORATED WOOD ACOUSTICAL PANEL W/ BATT INSULATION		PERFORATED METAL ACOUSTICAL PANEL OR AIR REGISTER WHERE NOTED
	PAINTED ALUMINUM PANEL SYSTEM		RIBBED WOOD ACOUSTICAL PANEL
	EXPOSED AND SEALED WAFFLE SLAB		ARCHITECTURAL ACOUSTICAL PANELS
	ORNAMENTAL GLASS AND METAL CANOPY		FIELD FINISHED MINERAL FIBER ACOUSTICAL PANEL OVER GYP SO CEILING ASSEMBLY
	STAINLESS STEEL FINISH		

**RCP DEVICE KEY**

	FLOOR/CEILING OUTLET
	SPEAKER/STROBE
	GLASS BREAK DETECTOR
	CELL WTD MOTION DETECTOR
	WALL WTD MOTION DETECTOR
	CELL WTD SECURITY SPEAKER
	WALL WTD SECURITY SPEAKER
	CELL WTD AV SPEAKER
	WALL WTD AV SPEAKER
	SECURITY CAMERA
	CLG WTD SMOKE/HEAT DETECTOR
	CLG WTD EXIT
	WALL WTD EXIT
	CLG WTD SPRINKLER HEAD
	WALL WTD SPRINKLER HEAD
	RETURN OUTLET CLG DIFFUSER
	SUPPLY OUTLET CLG DIFFUSER
	LINEAR SUPPLY DIFFUSER
	WIRELESS ALARM ANTENNA/TRANSMITTER
	TELEVISION OUTLET

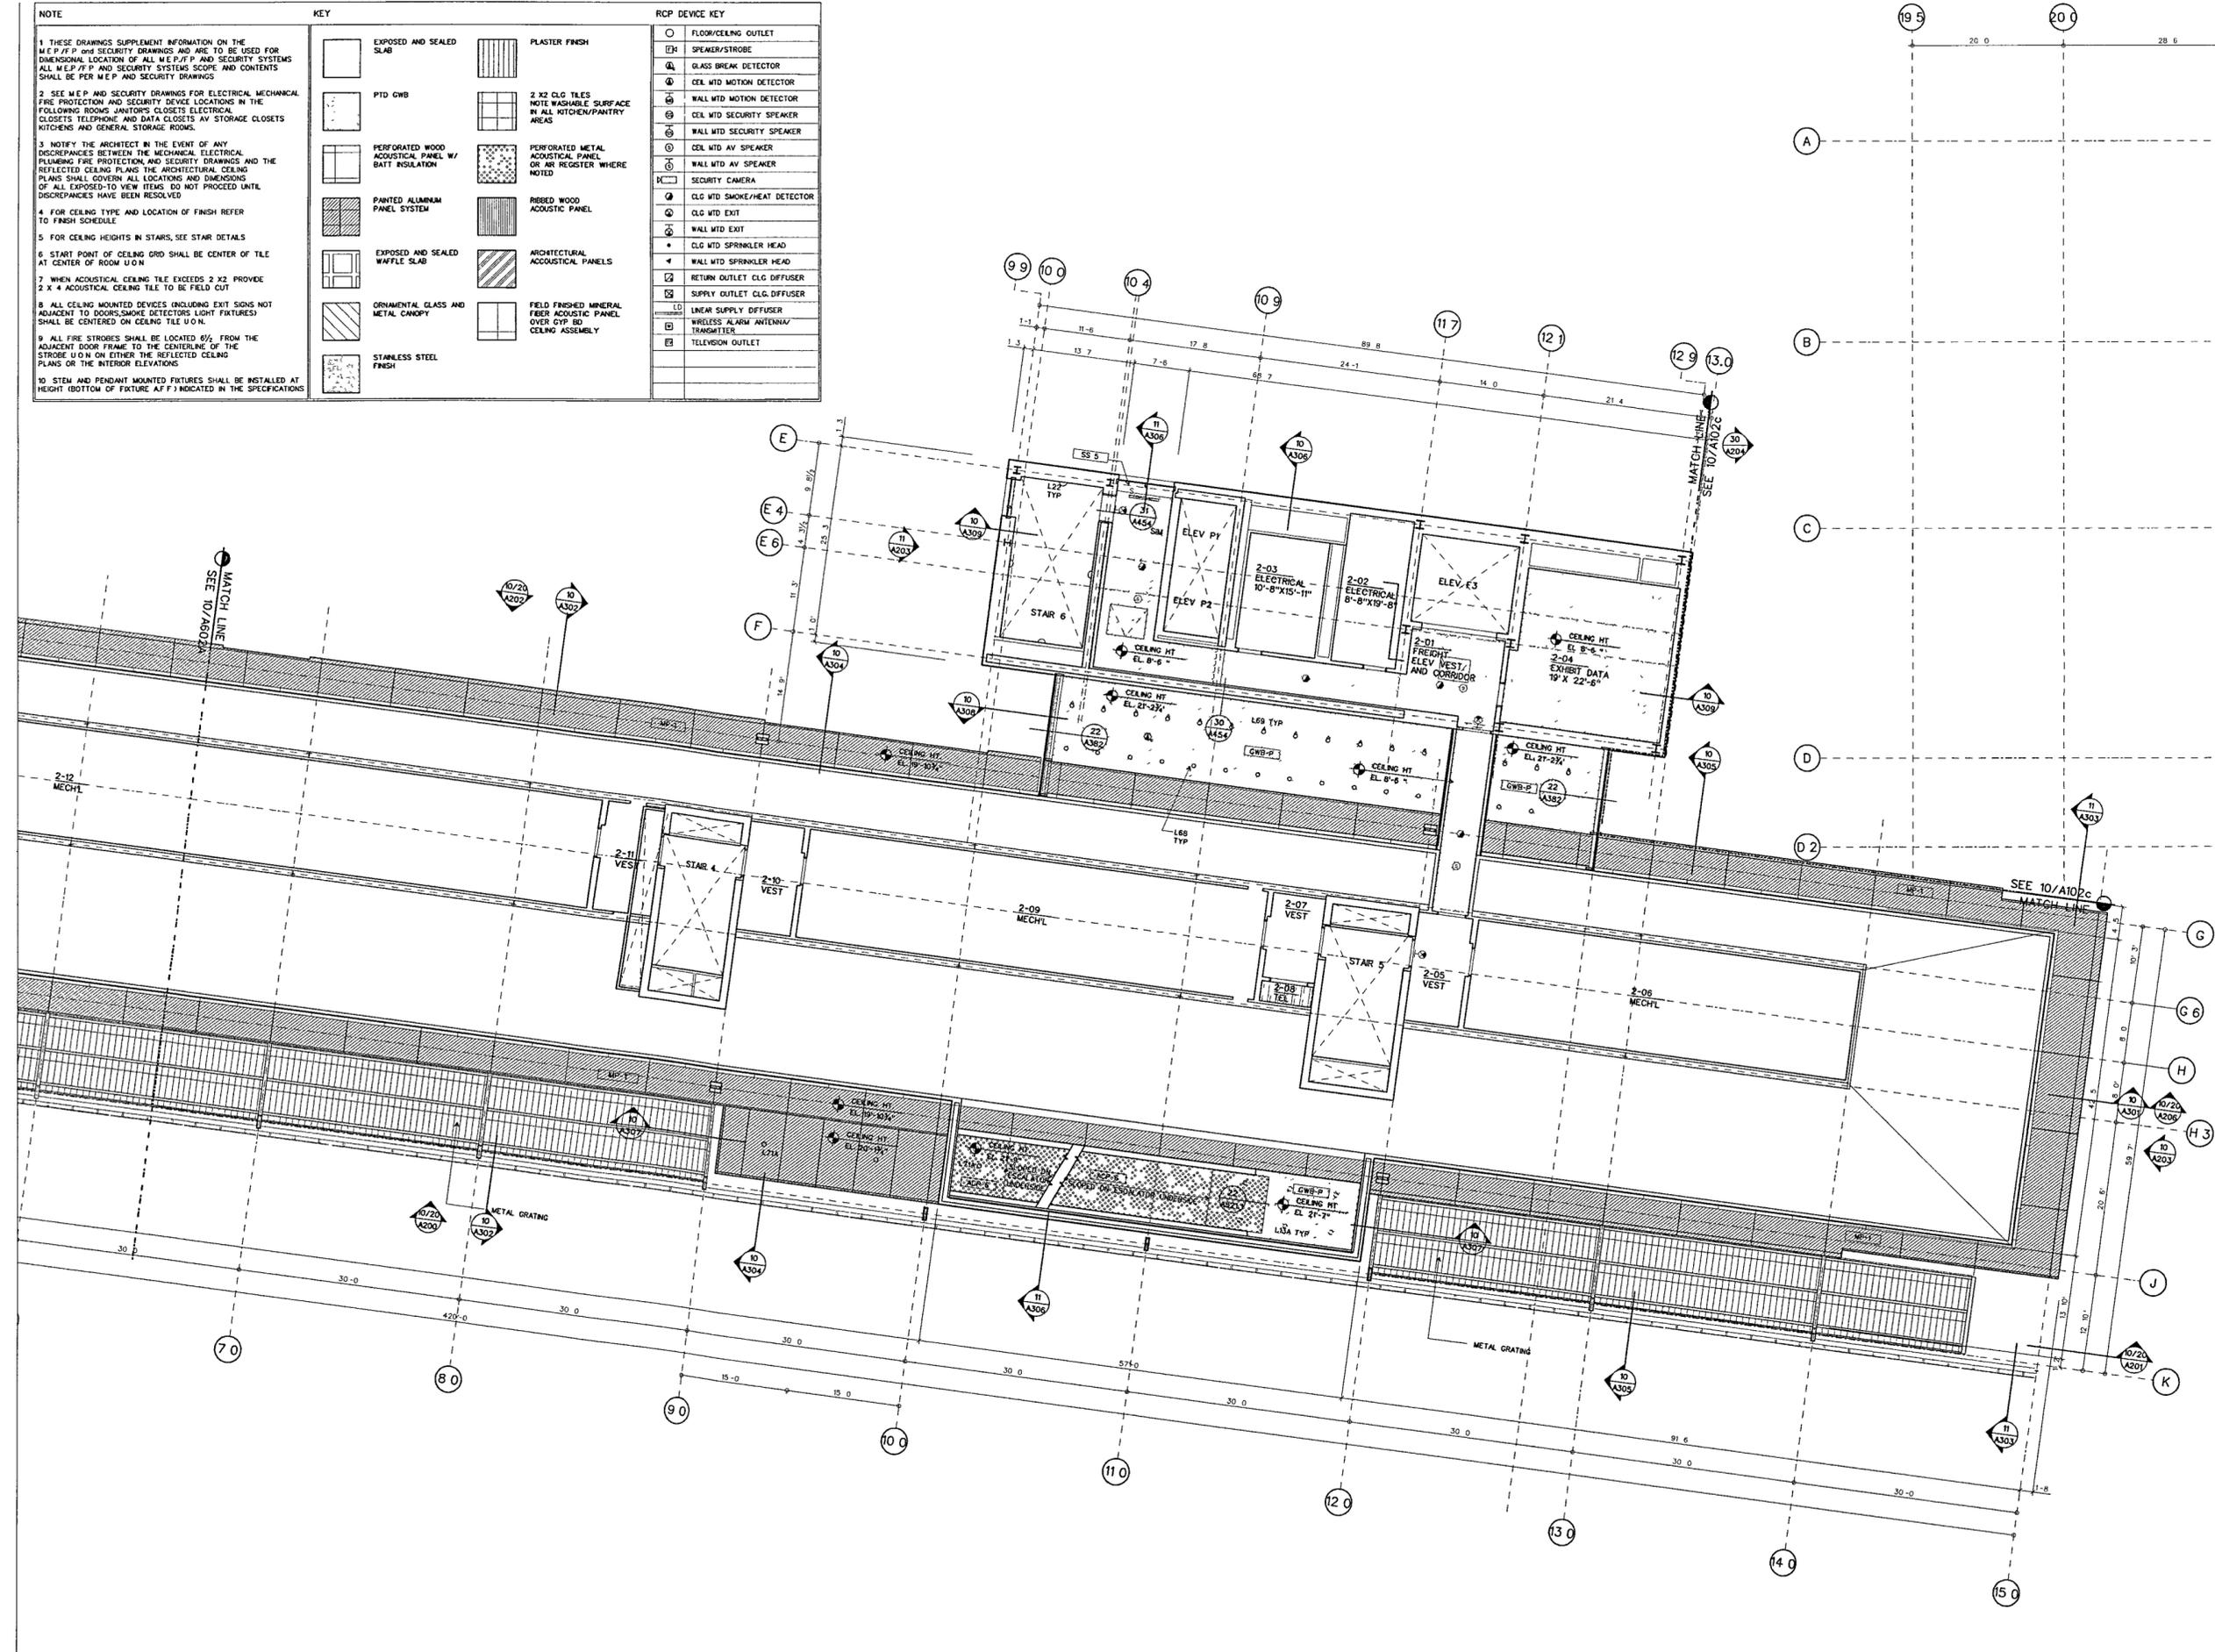

**WILLIAM J CLINTON  
PRESIDENTIAL  
CENTER**

LITTLE ROCK, ARKANSAS

Architect  
POLSKHEK PARTNERSHIP LLP  
320 West 13th Street  
New York, New York 10014  
212 507 7171

Coordinating Architects  
POLK STANLEY YEARY ARCHITECTS LLP  
700 South Schiller Street  
Little Rock, Arkansas 72201  
501 378 0878

WITSELL EVANS RASCO  
401 West Third Street  
Little Rock, Arkansas 72201  
501 374 5300

WOODS CARADINE ARCHITECTS  
2200 South Main Street  
Little Rock, Arkansas 72206  
501 374 4060

Landscape Architects  
HARGREAVES ASSOCIATES  
118 Magazine Street  
Cambridge, Massachusetts 02139  
617 681 0070

LANDSCAPE ARCHITECTURE, Inc.  
2300 Cottondale Lane Suite 202  
Little Rock, Arkansas 72202  
501 374 5810

Structural Engineer  
LESLIE E. ROBERTSON ASSOC., RLLP  
30 Broad Street, 47th Floor  
New York, New York 10004  
212 750 9000

MEP Engineers  
FLACK + KURTZ Inc.  
475 Fifth Avenue  
New York, New York 10017  
212 532 9600

CROMMELL ARCHITECTS ENGINEERS  
101 South Spring Street  
Little Rock, Arkansas 72201  
501 372 2900

Curianwall Consultant  
R. A. HEINTGES ARCHITECTS  
126 Fifth Avenue 9th Floor  
New York, New York 10011  
212 652-2968

Seal

100% Construction Documents	09/27/02
90% Progress Printing	08/30/02
100% Struct/CD Progress	07/01/02
100% Steel & Concrete CD	05/15/02
6 Architectural CD Progress	
100% Design Development	03/01/02
Issue	Date

Job No 9908  
Scale 1/8" = 1'-0"  
Date September 27, 2002  
Title  
**SECOND LEVEL  
PARTIAL REFLECTED  
CEILING PLAN**  
Sheet No  
**A602b**

SECOND LEVEL REFLECTED CEILING PLAN B  
SCALE 1/8" = 1'-0"