


DATE PLOTTED: 09/27/2002 11:26:39 AM

NOTE		KEY		RCP DEVICE KEY			
1. THESE DRAWINGS SUPPLEMENT INFORMATION ON THE M.E.P. AND SECURITY DRAWINGS AND ARE TO BE USED FOR DIMENSIONAL LOCATION OF ALL M.E.P. AND SECURITY SYSTEMS ALL M.E.P. AND SECURITY SYSTEMS SCOPE AND CONTENTS SHALL BE PER M.E.P. AND SECURITY DRAWINGS			EXPOSED AND SEALED SLAB		PLASTER FINISH		FLOOR/CEILING OUTLET
2. SEE M.E.P. AND SECURITY DRAWINGS FOR ELECTRICAL, MECHANICAL, FIRE PROTECTION AND SECURITY DEVICE LOCATIONS IN THE FOLLOWING ROOMS: JANITOR'S CLOSETS, ELECTRICAL CLOSETS, TELEPHONE AND DATA CLOSETS, AV STORAGE CLOSETS, KITCHENS AND GENERAL STORAGE ROOMS			PTD GWB		2 X 2 CLG TILES NOTE WASHABLE SURFACE IN ALL KITCHEN/PANTRY AREAS		GLASS BREAK DETECTOR
3. NOTIFY THE ARCHITECT IN THE EVENT OF ANY DISCREPANCIES BETWEEN THE MECHANICAL, ELECTRICAL, PLUMBING, FIRE PROTECTION AND SECURITY DRAWINGS AND THE REFLECTED CEILING PLANS AND THE ARCHITECTURAL CEILING PLANS SHALL GOVERN ALL LOCATIONS AND DIMENSIONS OF ALL EXPOSED TO-NEW ITEMS. DO NOT PROCEED UNTIL DISCREPANCIES HAVE BEEN RESOLVED.			PERFORATED WOOD ACOUSTICAL PANEL W/ BATT INSULATION		PERFORATED METAL ACOUSTICAL PANEL OR AIR REGISTER WHERE NOTED		CEILING MTD MOTION DETECTOR
4. FOR CEILING TYPE AND LOCATION OF FINISH REFER TO FINISH SCHEDULE			PAINTED ALUMINUM PANEL SYSTEM		RIBBED WOOD ACOUSTICAL PANEL		WALL MTD SECURITY SPEAKER
5. FOR CEILING HEIGHTS IN STAIRS SEE STAR DETAILS			EXPOSED AND SEALED WAFFLE SLAB		ARCHITECTURAL PANELS		CEILING MTD AV SPEAKER
6. START POINT OF CEILING GRID SHALL BE CENTER OF TILE AT CENTER OF ROOM U.O.N.			ORNAMENTAL GLASS AND METAL CANOPY		FIELD FINISHED MINERAL FIBER ACOUSTIC PANEL OVER GYP BD CEILING ASSEMBLY		WALL MTD AV SPEAKER
7. WHEN ACOUSTICAL CEILING TILE EXCEEDS 2 X 2 PROVIDE 2 X 4 ACOUSTICAL CEILING TILE TO BE FIELD CUT			STAINLESS STEEL FINISH				SECURITY CAMERA
8. ALL CEILING MOUNTED DEVICES (INCLUDING EXIT SIGNS-NOT ADJACENT TO DOORS, SMOKE DETECTORS LIGHT FIXTURES) SHALL BE CENTERED ON CEILING TILE U.O.N.							CEILING MTD SMOKE/HEAT DETECTOR
9. ALL FIRE STROBES SHALL BE LOCATED 6 1/4" FROM THE ADJACENT DOOR FRAME TO THE CENTERLINE OF THE STROBE U.O.N. ON EITHER THE REFLECTED CEILING PLANS OR THE INTERIOR ELEVATIONS							CEILING MTD EXIT
10. STEM AND PENDANT MOUNTED FIXTURES SHALL BE INSTALLED AT HEIGHT (BOTTOM OF FIXTURE AFF) INDICATED IN THE SPECIFICATIONS							WALL MTD EXIT
							CEILING MTD SPRINKLER HEAD
							WALL MTD SPRINKLER HEAD
							RETURN OUTLET CLG DIFFUSER
							SUPPLY OUTLET CLG DIFFUSER
							LINEAR SUPPLY DIFFUSER
							WIRELESS ALARM ANTENNA/TRANSMITTER
							TELEVISION OUTLET

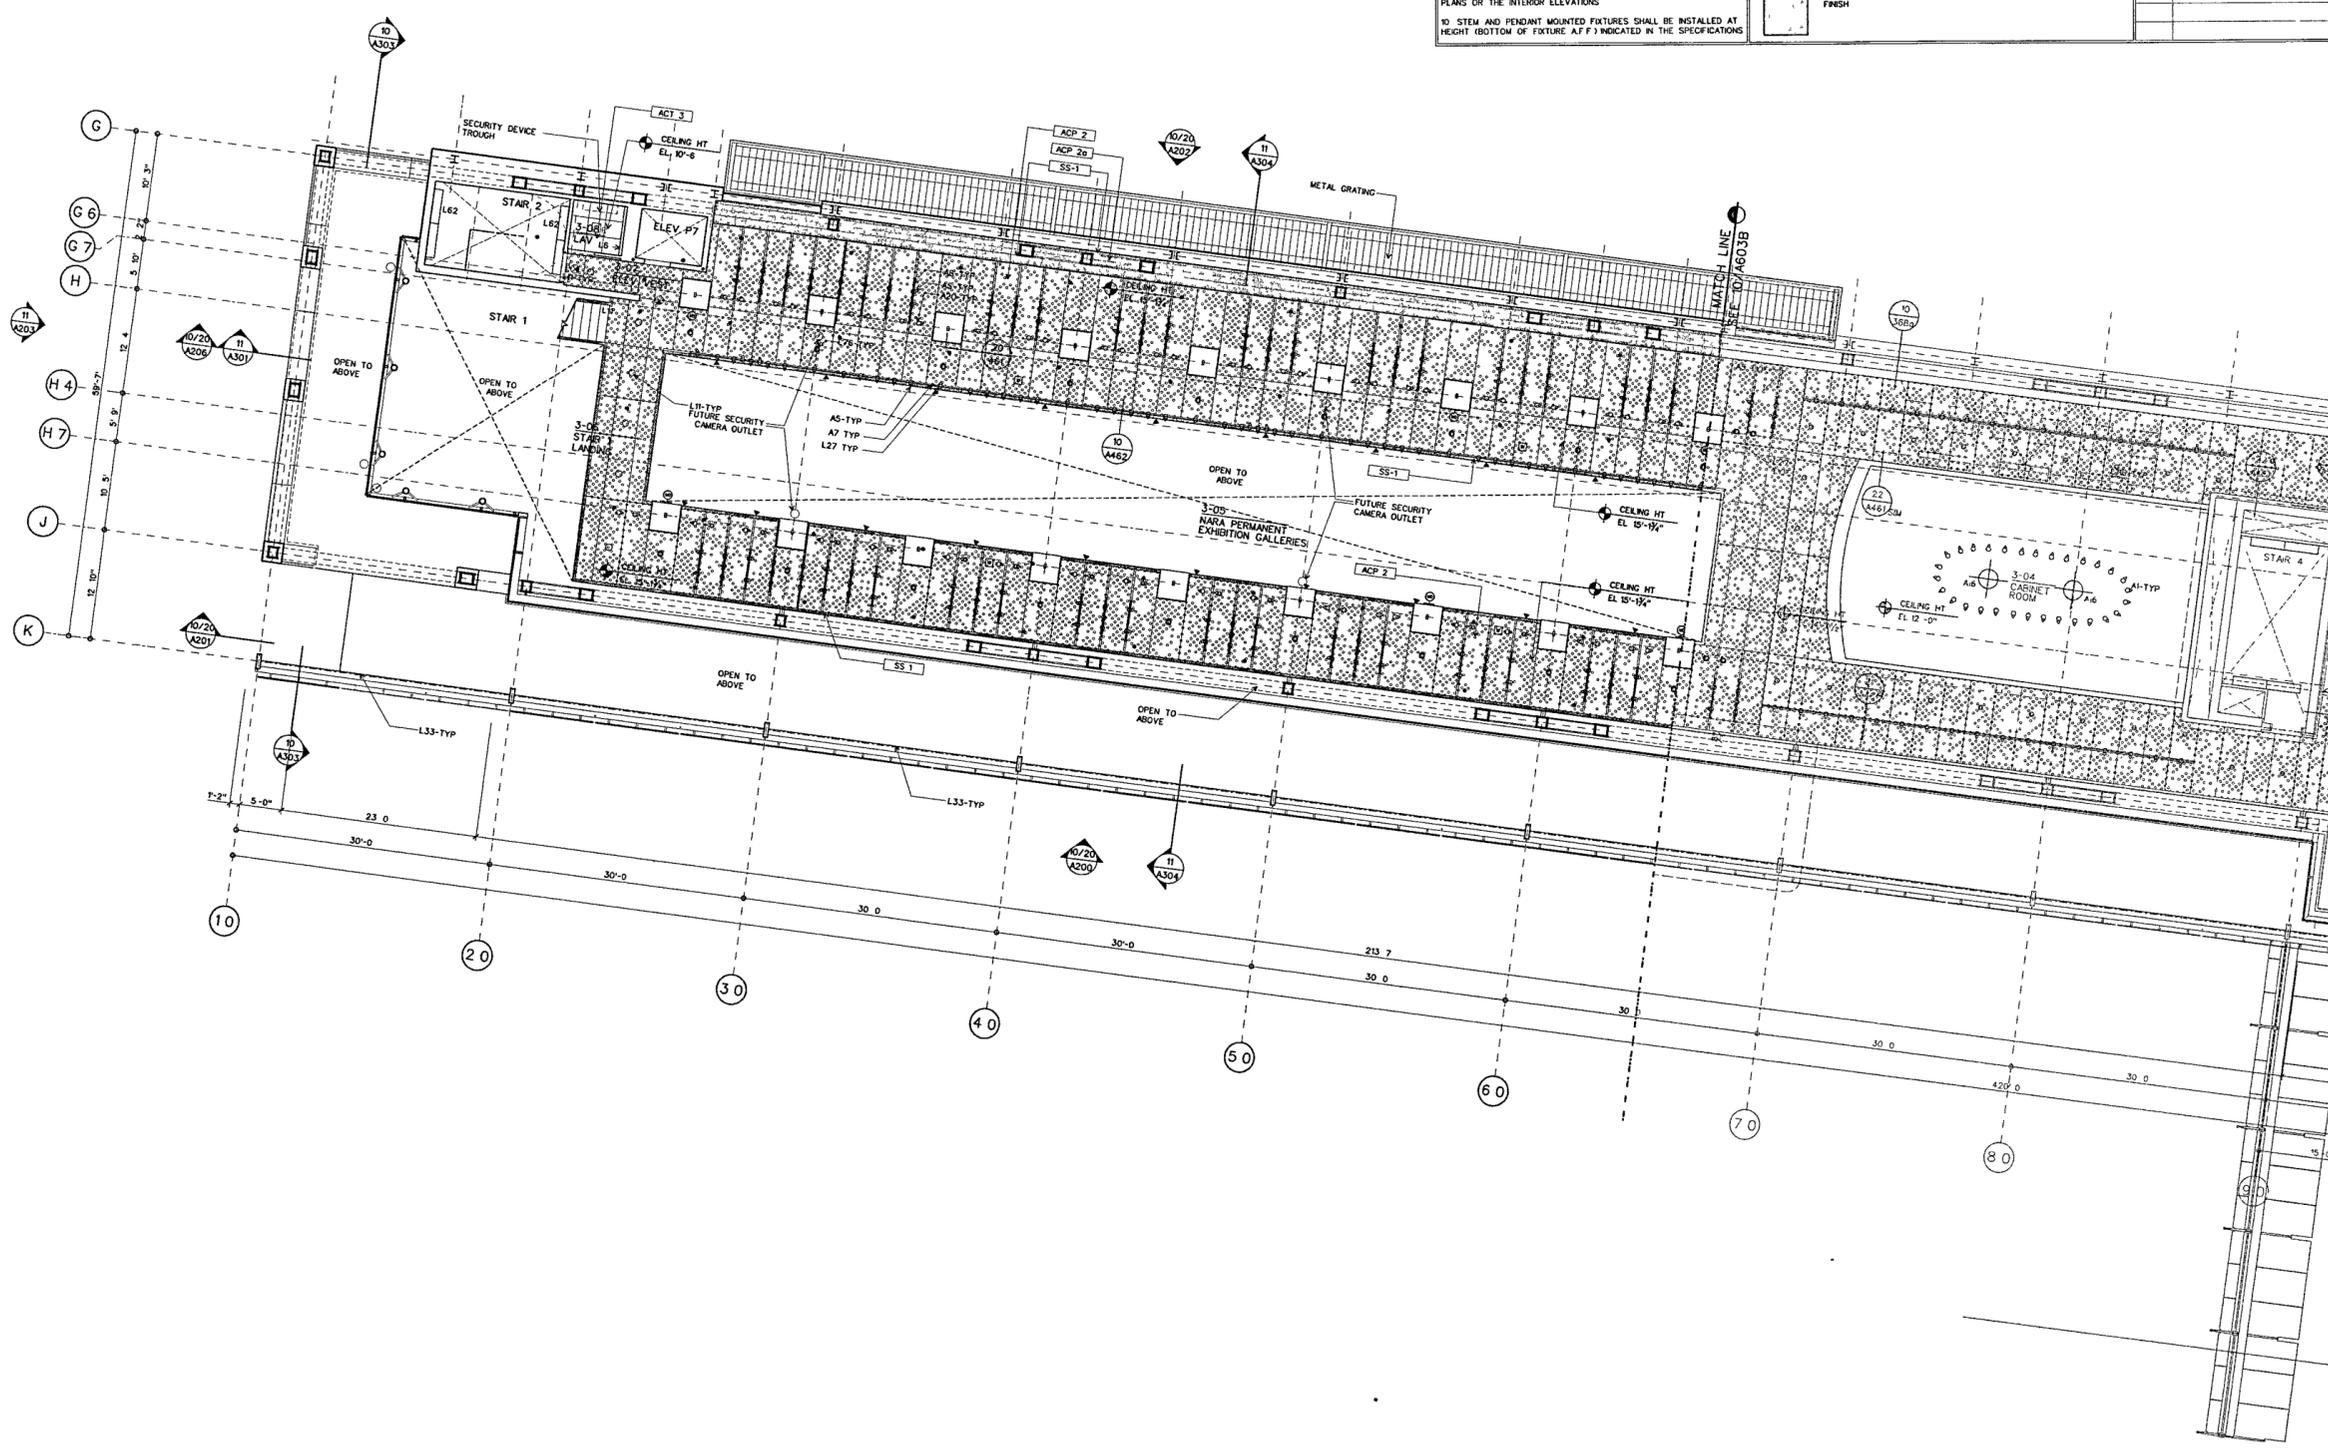

**WILLIAM J CLINTON
PRESIDENTIAL
CENTER**

LITTLE ROCK, ARKANSAS

Architect
POLSHKE PARTNERSHIP LLP
320 West 13th Street
New York, New York 10014
212.807.7171

Coordinating Architects
POLK STANLEY YEARY ARCHITECTS LLP
700 South Schuller Street
Little Rock, Arkansas 72201
501.378.0878

WITSELL EVANS RASCO
501 West Third Street
Little Rock, Arkansas 72201
501.374.5300

WOODS CARADINE ARCHITECTS
2200 South Main Street
Little Rock, Arkansas 72206
501.374.4060

Landscape Architects
HARGREAVES ASSOCIATES
118 Magazine Street
Cambridge, Massachusetts 02139
617.891.0070

LANDSCAPE ARCHITECTURE Inc.
2300 Cottondale Lane Suite 202
Little Rock, Arkansas 72202
501.374.9810

Structural Engineer
LESLIE E ROBERTSON ASSOC RLLP
30 Broad Street, 47th Floor
New York, New York 10004
212.750.9000

MEP Engineers
FLACK + KURTZ Inc.
475 Fifth Avenue
New York, New York 10017
212.532.9600

CRONMELL ARCHITECTS ENGINEERS
101 South Spring Street
Little Rock, Arkansas 72201
501.372.2900

Curianwall Consultant
R. A. HEINTGES ARCHITECTS
128 Fifth Avenue 9th Floor
New York, New York 10011
212.652-2966

Seal

100% Construction Documents	09/27/02
90% Progress Printing	08/30/02
100% Struct/CD Progress	07/01/02
100% Steel & Concrete CD	05/15/02
& Architectural CD Progress	
100% Design Development	03/01/02
Issue	Date

Job No 9908
Scale 1/8" = 1'-0"
Date September 27, 2002
Title MUSEUM LOWER LEVEL PARTIAL REFLECTED CEILING PLAN
Sheet No A603a

LOWER MUSEUM LEVEL REFLECTED CEILING PLAN A
SCALE 1/8" = 1'-0"

RCP-03 DGN 10

FOR OFFICIAL USE ONLY