


NOTE	KEY	RCP DEVICE KEY
1. THESE DRAWINGS SUPPLEMENT INFORMATION ON THE M.E.P./F.P. AND SECURITY DRAWINGS AND ARE TO BE USED FOR DIMENSIONAL LOCATION OF ALL M.E.P./F.P. AND SECURITY SYSTEMS. ALL M.E.P./F.P. AND SECURITY SYSTEMS SCOPE AND CONTENTS SHALL BE PER M.E.P. AND SECURITY DRAWINGS.	EXPOSED AND SEALED SLAB	FLOOR/CEILING OUTLET
2. SEE M.E.P. AND SECURITY DRAWINGS FOR ELECTRICAL, MECHANICAL, FIRE PROTECTION AND SECURITY DEVICE LOCATIONS IN THE FOLLOWING ROOMS: JANITORS CLOSETS ELECTRICAL CLOSETS TELEPHONE AND DATA CLOSETS AV STORAGE CLOSETS KITCHENS AND GENERAL STORAGE ROOMS.	PTD GWB	SPEAKER/STROBE
3. NOTIFY THE ARCHITECT IN THE EVENT OF ANY DISCREPANCIES BETWEEN THE MECHANICAL, ELECTRICAL, PLUMBING, FIRE PROTECTION AND SECURITY DRAWINGS AND THE REFLECTED CEILING PLANS. THE ARCHITECTURAL CEILING PLANS SHALL GOVERN ALL LOCATIONS AND DIMENSIONS OF ALL EXPOSED-TO-VIEW ITEMS. DO NOT PROCEED UNTIL DISCREPANCIES HAVE BEEN RESOLVED.	PERFORATED WOOD ACOUSTICAL PANEL W/ BATT INSULATION	GLASS BREAK DETECTOR
4. FOR CEILING TYPE AND LOCATION OF FINISH REFER TO FINISH SCHEDULE.	PAINTED ALUMINUM PANEL SYSTEM	CELL MTD MOTION DETECTOR
5. FOR CEILING HEIGHTS IN STAIRS SEE STAIR DETAILS.	EXPOSED AND SEALED WAFFLE SLAB	WALL MTD MOTION DETECTOR
6. START POINT OF CEILING GRID SHALL BE CENTER OF TILE AT CENTER OF ROOM U.O.N.	ORNAMENTAL GLASS AND METAL CANOPY	CELL MTD SECURITY SPEAKER
7. WHEN ACOUSTICAL CEILING TILE EXCEEDS 2 X 2 PROVIDE 2 X 4 ACOUSTICAL CEILING TILE TO BE FIELD CUT.	STAINLESS STEEL FINISH	WALL MTD SECURITY SPEAKER
8. ALL CEILING MOUNTED DEVICES (INCLUDING EXIT SIGNS-NOT ADJACENT TO DOORS SMOKE DETECTORS LIGHT FIXTURES) SHALL BE CENTERED ON CEILING TILE U.O.N.		CELL MTD AV SPEAKER
9. ALL FIRE STROBES SHALL BE LOCATED 6 1/2" FROM THE ADJACENT DOOR FRAME TO THE CENTERLINE OF THE STROBE U.O.N. ON EITHER THE REFLECTED CEILING PLANS OR THE INTERIOR ELEVATIONS.		WALL MTD AV SPEAKER
10. STEM AND PENDANT MOUNTED FIXTURES SHALL BE INSTALLED AT HEIGHT (BOTTOM OF FIXTURE AFF) INDICATED IN THE SPECIFICATIONS.		SECURITY CAMERA
	PLASTER FINISH	CLG MTD SMOKE/HEAT DETECTOR
	2 X 2 CLG TILE NOTE: WASHABLE SURFACE IN ALL KITCHEN/PANTRY AREAS	CLG MTD EXIT
	PERFORATED METAL ACOUSTICAL PANEL OR AIR REGISTER WHERE NOTED	WALL MTD EXIT
	RIBBED WOOD ACOUSTICAL PANEL	CLG MTD SPRINKLER HEAD
	ARCHITECTURAL ACOUSTICAL PANELS	WALL MTD SPRINKLER HEAD
	FIELD FINISHED MINERAL FIBER ACOUSTICAL PANEL OVER GYP BO. CEILING ASSEMBLY	RETURN OUTLET CLG DIFFUSER
		SUPPLY OUTLET CLG DIFFUSER
		LINEAR SUPPLY DIFFUSER
		WIRELESS ALARM ANTENNA/TRANSMITTER
		TELEVISION OUTLET

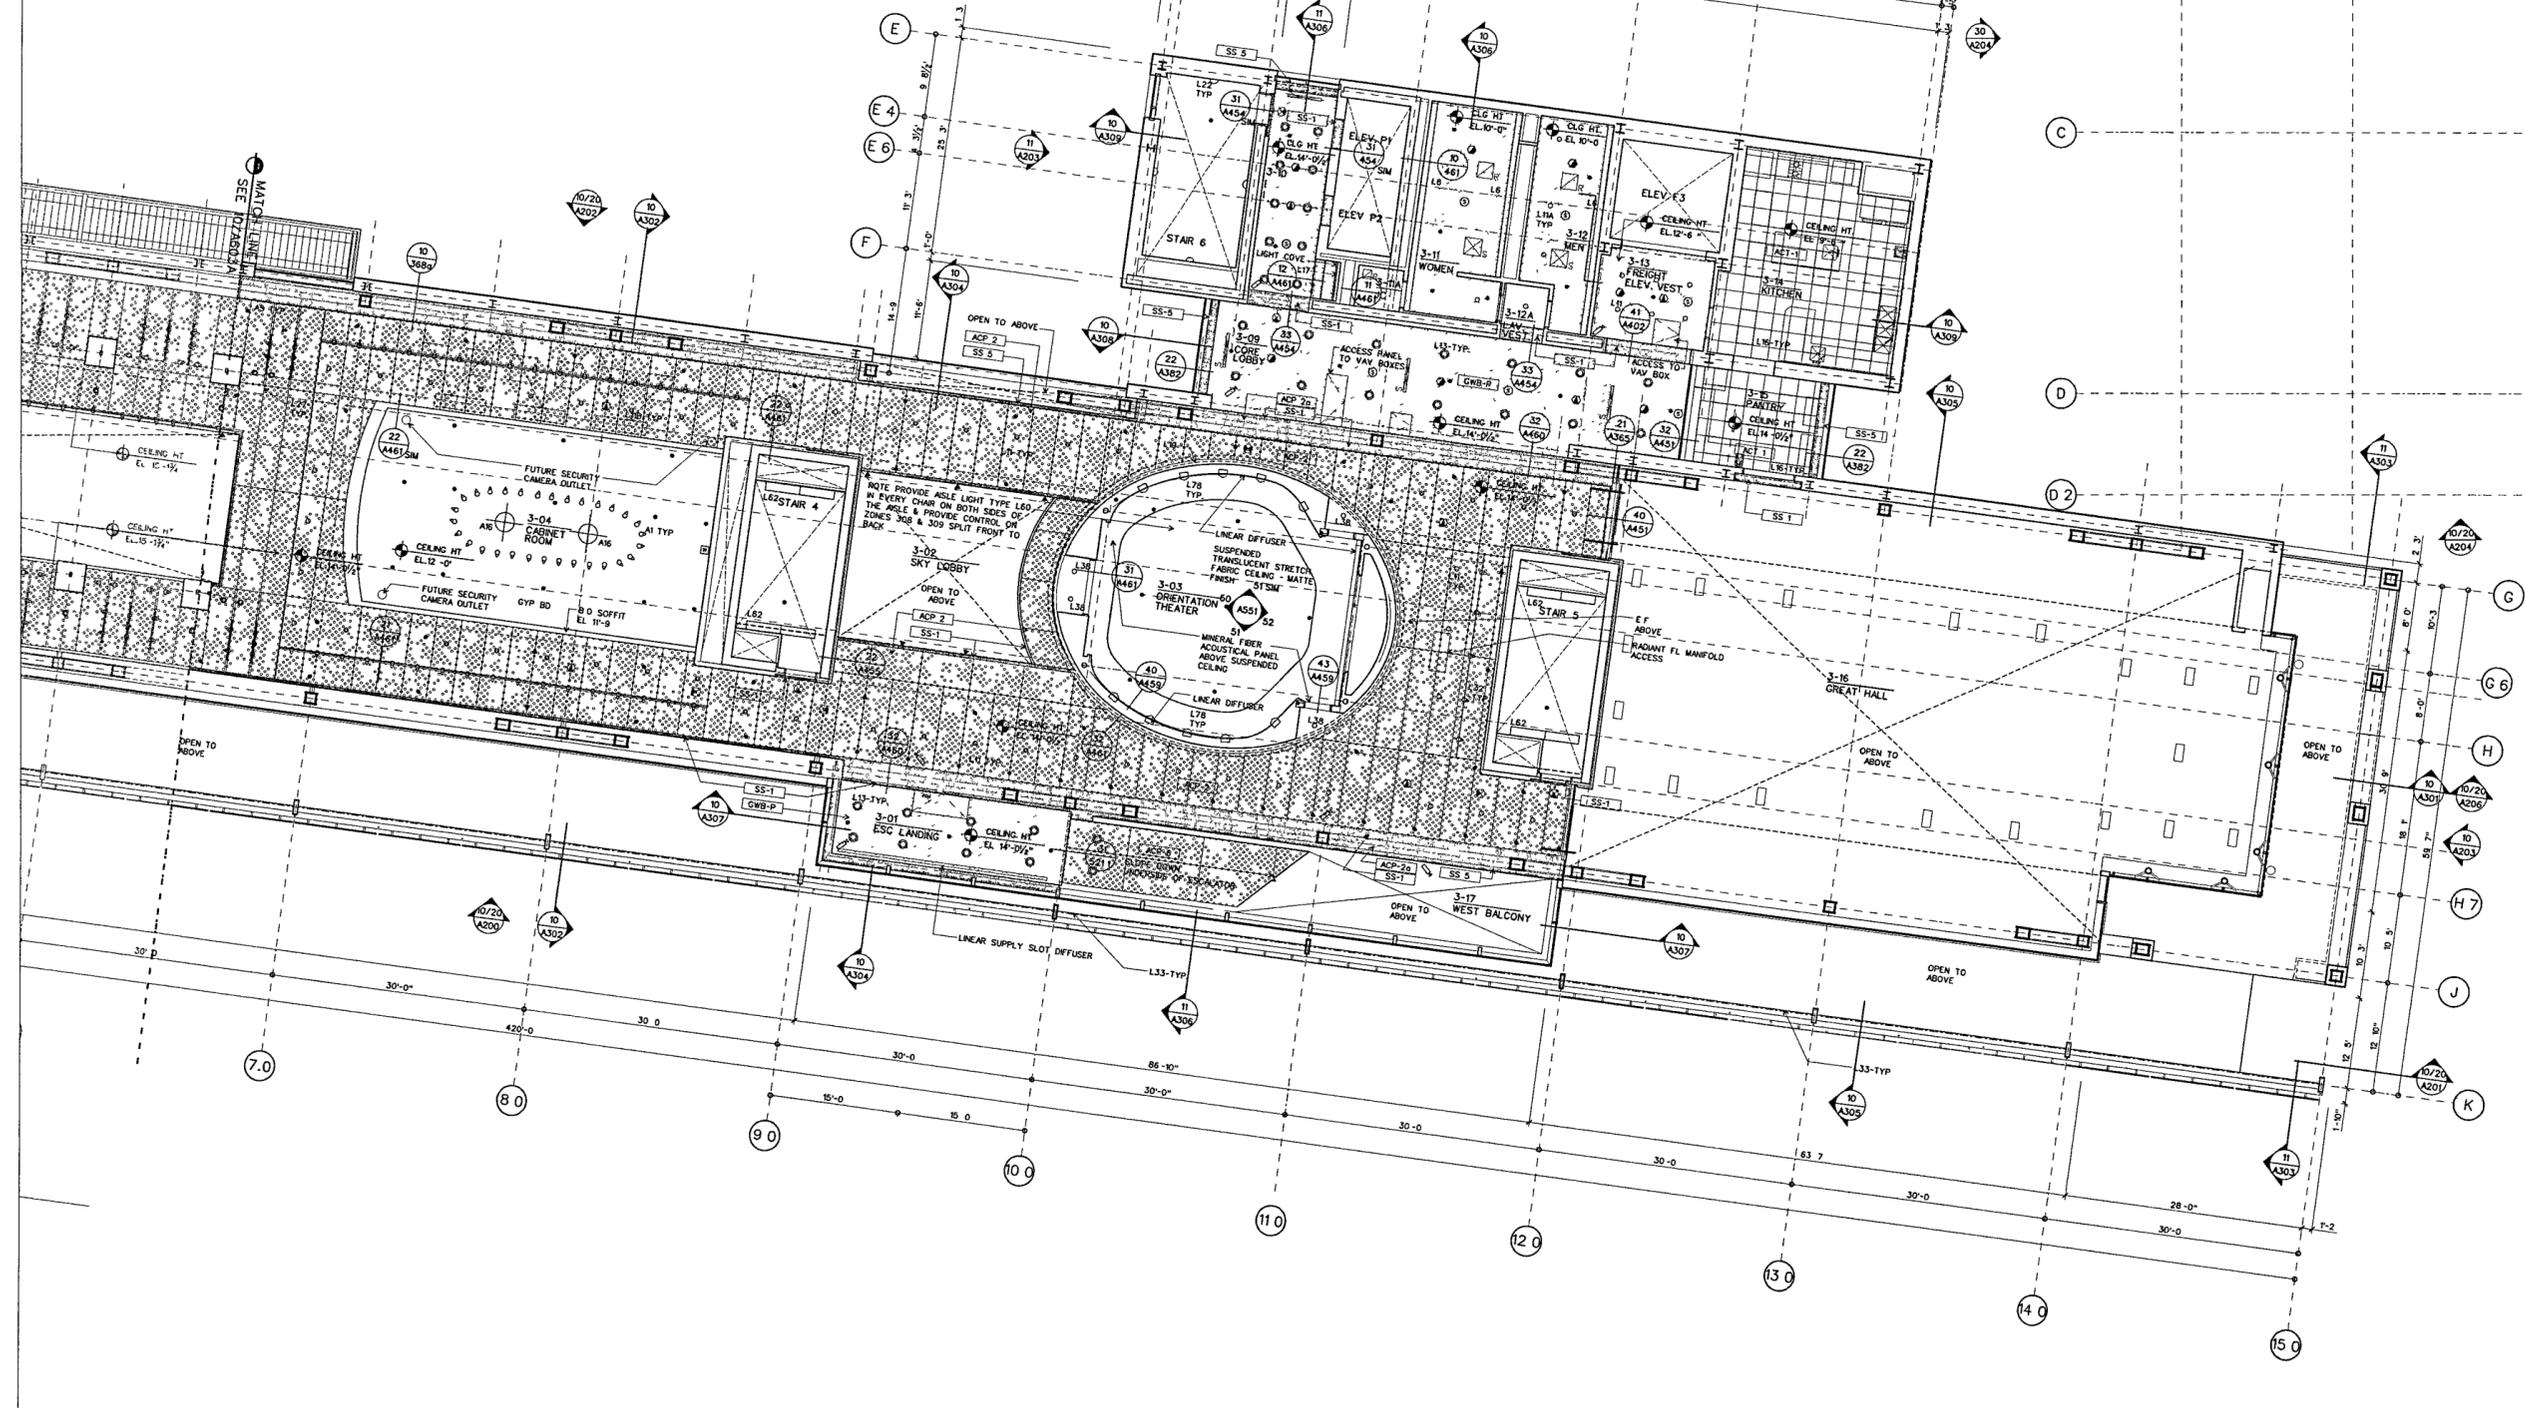

LOWER MUSEUM LEVEL REFLECTED CEILING PLAN B
SCALE 1/8" = 1'-0"

**WILLIAM J CLINTON
PRESIDENTIAL
CENTER**

LITTLE ROCK, ARKANSAS

Architect
POLISHEK PARTNERSHIP LLP
320 West 13th Street
New York, New York 10014
212.807.7171

Coordinating Architects
POLK STANLEY YEARY ARCHITECTS LLP
700 South Schiller Street
Little Rock, Arkansas 72201
501.378.0878

WITSELL EVANS RASCO
901 West Third Street
Little Rock, Arkansas 72201
501.374.5300

WOODS CARADINE ARCHITECTS
2200 South Main Street
Little Rock, Arkansas 72206
501.374.4060

Landscape Architects
HARGREAVES ASSOCIATES
118 Magazine Street
Cambridge, Massachusetts 02139
617.661.0070

LANDSCAPE ARCHITECTURE Inc.
2300 Cottonwood Lane Suite 202
Little Rock, Arkansas 72202
501.374.5610

Structural Engineer
LESLIE E. ROBERTSON ASSOC., RLLP
30 Broad Street, 47th Floor
New York, New York 10004
212.750.9000

MEP Engineers
FLACK + KURTZ Inc
475 Fifth Avenue
New York, New York 10017
212.532.9600

CROMMELL ARCHITECTS ENGINEERS
101 South Spring Street
Little Rock, Arkansas 72201
501.372.2900

Curtainwall Consultant
R. A. HEINTGES ARCHITECTS
128 Fifth Avenue, 9th Floor
New York, New York 10011
212.652.2966

Seal

100% Construction Documents	08/27/02
90% Progress Printing	08/30/02
100% Struct./CD Progress	07/01/02
100% Steel & Concrete CD	05/15/02
& Architectural CD Progress	
100% Design Development	03/01/02
Issue	Date

Job No 9908
Scale 1/8" = 1'-0"
Date September 27, 2002
Title MUSEUM LOWER LEVEL PARTIAL REFLECTED CEILING PLAN
Sheet No A603b

RCP-03 DGN 10

FOR OFFICIAL USE ONLY