

WILLIAM J. CLINTON
PRESIDENTIAL
CENTER

LITTLE ROCK, ARKANSAS

Architect
POLSHEK PARTNERSHIP LLP
320 West 15th Street
New York, New York 10014
212 807 7171

Coordinating Architects
POLK STANLEY YEARY ARCHITECTS Ltd
700 South Schiller Street
Little Rock, Arkansas 72201
501 378 0878

WITSELL EVANS RASCO
801 West Third Street
Little Rock, Arkansas 72201
501 374 5300

WOODS CARADINE ARCHITECTS
2200 South Main Street
Little Rock, Arkansas 72206
501 374 4060

Landscape Architects
HARGREAVES ASSOCIATES
118 Magazine Street
Cambridge Massachusetts 02139
617 651 0070

LANDSCAPE ARCHITECTURE, Inc.
2300 Cotterdale Lane Suite 202
Little Rock, Arkansas 72202
501 374 5810

Structural Engineer
LESLIE E. ROBERTSON ASSOC., RLLP
30 Broad Street, 4th Floor
New York, New York 10004
212 750 9000


MEP Engineers
FLACK + KURTZ Inc
475 Fifth Avenue
New York, New York 10017
212 532 9500

CROMWELL ARCHITECTS ENGINEERS
101 South Spring Street
Little Rock, Arkansas 72201
501 372 2900

Curtainwall Consultant
R. A. HEINTGES ARCHITECTS
126 Fifth Avenue, 9th Floor
New York, New York 10011
212 652 2966



Issue	Date
100% Construction Documents	09/27/02
90% Progress Printing	08/30/02
100% Struct./CD Progress	07/01/02
Bridge Bldg. Substructure	06/14/02
100% Steel & Concrete CD	05/15/02
Architectural CD Progress	
100% Design Development	03/01/02

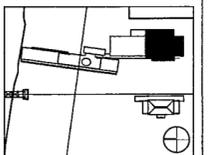


Job No 9908
Scale 1/8" = 1'-0"
Date September 27, 2002
Title

THIRD LEVEL
REFLECTED
CEILING PLAN

Sheet No
A603d

FOR OFFICIAL USE ONLY

NOTE	KEY	ROP DEVICE KEY
1. THESE DRAWINGS SUPPLEMENT INFORMATION ON THE M.E.P./P.P. AND SECURITY DRAWINGS AND ARE TO BE USED FOR DETERMINING LOCATION OF ALL M.E.P./P.P. AND SECURITY SYSTEMS. ALL M.E.P./P.P. AND SECURITY SYSTEMS SCOPE AND CONTENTS SHALL BE PER M.E.P. AND SECURITY DRAWINGS.	EXPOSED AND SEALED SLAB	FLOOR/CEILING OUTLET
2. SEE M.E.P. AND SECURITY DRAWINGS FOR ELECTRICAL, MECHANICAL, FIRE PROTECTION AND SECURITY DEVICE LOCATIONS IN THE FOLLOWING ROOMS: JANITORS CLOSETS, ELECTRICAL CLOSETS, TELEPHONE AND DATA CLOSETS, AV STORAGE CLOSETS, KITCHENS AND GENERAL STORAGE ROOMS.	PTD. GWB	SPEAKER/STROBE
3. NOTIFY THE ARCHITECT IN THE EVENT OF ANY DISCREPANCIES BETWEEN THE MECHANICAL, ELECTRICAL, PLUMBING, FIRE PROTECTION AND SECURITY DRAWINGS AND THE REFLECTED CEILING PLANS. THE ARCHITECTURAL CEILING PLANS SHALL GOVERN ALL LOCATIONS AND DIMENSIONS OF ALL EXPOSED TO VIEW ITEMS. DO NOT PROCEED UNTIL DISCREPANCIES HAVE BEEN RESOLVED.	PERFORATED WOOD ACOUSTICAL PANEL W/ DIRT INSULATION	GLASS BREAK DETECTOR
4. FOR CEILING TYPE AND LOCATION OF FINISH REFER TO FINISH SCHEDULE.	PAINTED ALUMINUM PANEL SYSTEM	CELL MTD MOTION DETECTOR
5. FOR CEILING HEIGHTS IN STAIRS SEE STAIR DETAILS.	EXPOSED AND SEALED WAFFLE SLAB	WALL MTD MOTION DETECTOR
6. START POINT OF CEILING GRID SHALL BE CENTER OF TILE AT CENTER OF ROOM U.O.V.	ORNAMENTAL GLASS AND METAL CANOPY	CELL MTD SECURITY SPEAKER
7. WHEN ACOUSTICAL CEILING TILE EXCEEDS 3 X2 PROVIDE 2" X 4" ADDITIONAL CEILING TILE TO BE FIELD CUT.	STAINLESS STEEL FINISH	CELL MTD AV SPEAKER
8. ALL CEILING MOUNTED DEVICES INCLUDING EXIT SIGNS NOT ADJACENT TO DOORS, SMOKE DETECTORS, LIGHT FIXTURES SHALL BE CENTERED ON CEILING TILE U.O.V.		WALL MTD AV SPEAKER
9. ALL FIRE STROBES SHALL BE LOCATED 6" FROM THE ADJACENT DOOR FRAME TO THE CENTERLINE OF THE STROBE U.O.V. ON EITHER THE REFLECTED CEILING PLANS OR THE INTERIOR ELEVATIONS.		SECURITY CAMERA
10. SITES AND PERMANENT MOUNTED FIXTURES SHALL BE INSTALLED AT HEIGHT BOTTOM OF FIXTURE AS IT IS INDICATED IN THE SPECIFICATIONS.		CELL MTD SMOKE/HEAT DETECTOR
		CELL MTD EXIT
		WALL MTD EXIT
		CELL MTD SPRINKLER HEAD
		WALL MTD SPRINKLER HEAD
		RETURN OUTLET C.L.G. DIFFUSER
		SUPPLY OUTLET C.L.G. DIFFUSER
		LINEAR SUPPLY DIFFUSER
		WIRELESS ALARM PERIMETER TRANSMITTER
		TELEVISION OUTLET
		CIRCULAR DIFFUSER

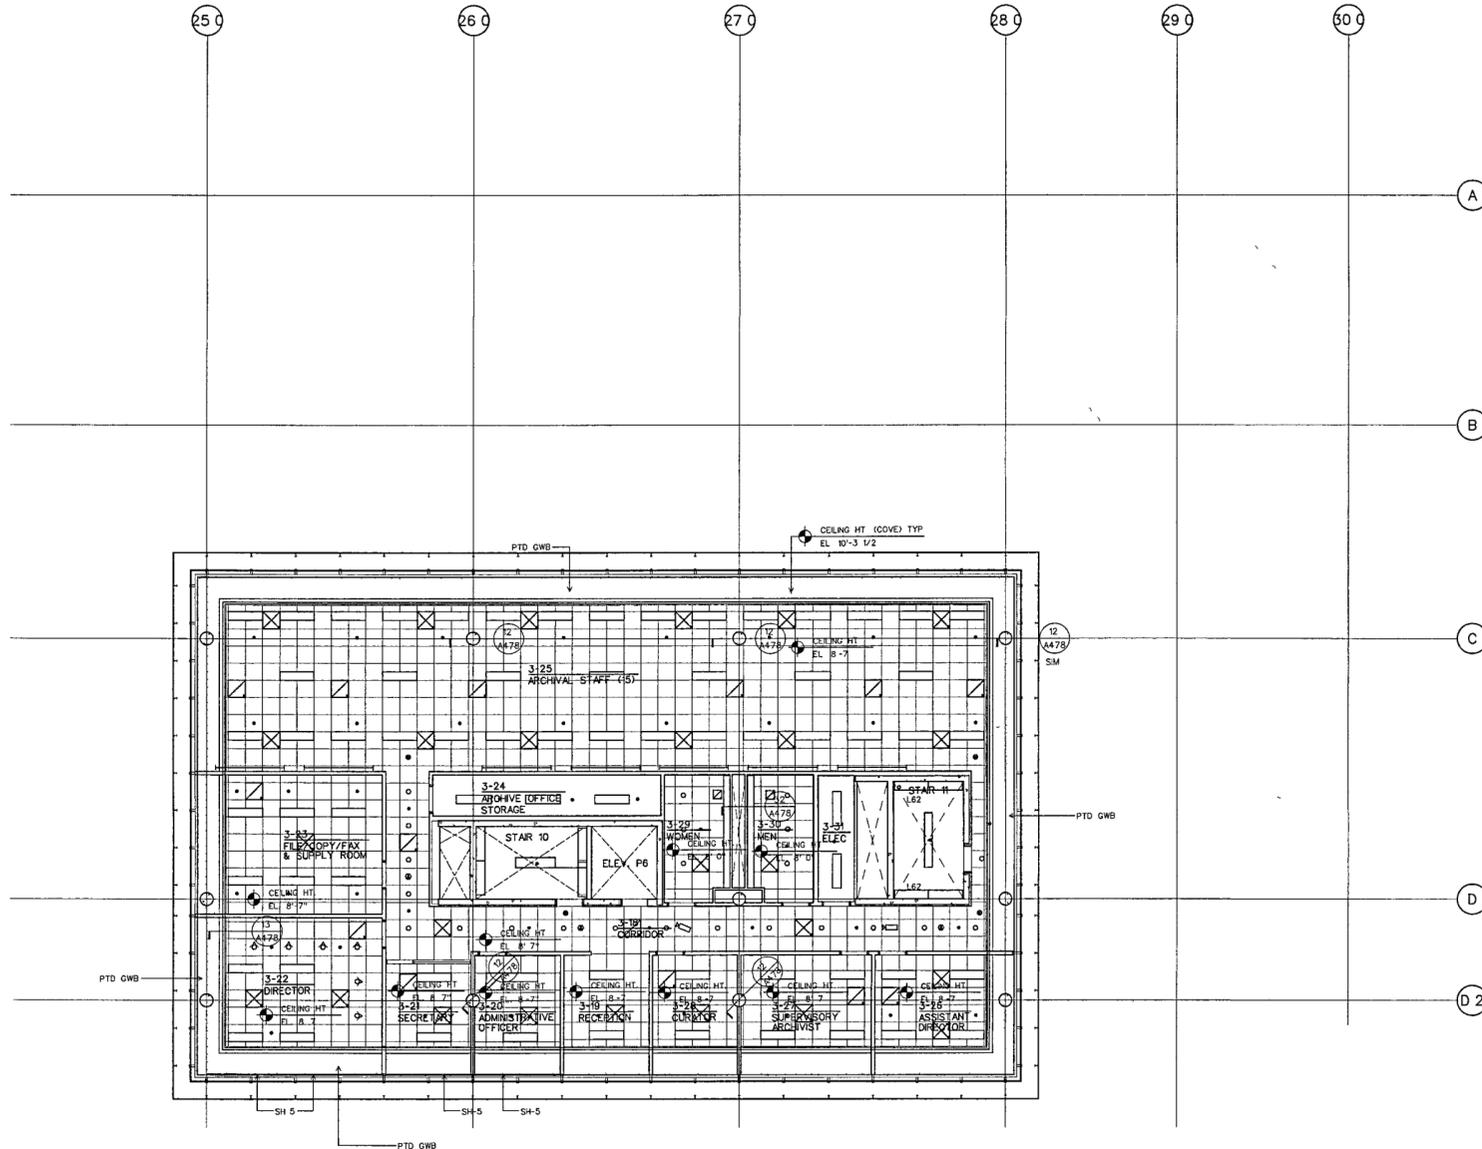

THIRD LEVEL REFLECTED CEILING PLAN D
SCALE 1/4" = 1'-0"

AFP-03.dwg 10