

**WILLIAM J CLINTON
PRESIDENTIAL
CENTER**

LITTLE ROCK ARKANSAS

Architect
POLSHEK PARTNERSHIP LLP
320 West 13th Street
New York, New York 10014
212 807 7171

Coordinating Architects
POLK STANLEY YEARY ARCHITECTS LLP
700 South Schiller Street
Little Rock Arkansas 72201
501 378 0878

WITSELL EVANS RASCO
901 West Third Street
Little Rock Arkansas 72201
501 374 5300

WOODS CARADINE ARCHITECTS
2200 South Main Street
Little Rock Arkansas 72206
501 374 4060

Landscape Architects
HARGREAVES ASSOCIATES
118 Magazine Street
Cambridge Massachusetts 02139
617 661 0070

LANDSCAPE ARCHITECTURE Inc
400 West Capitol Avenue
Suite 1600 Regions Center
Little Rock Arkansas 72201
501 374 5610

Structural Engineer
LESLIE E. ROBERTSON ASSOC., RLLP
30 Broad Street 47th Floor
New York, New York 10004
212 750 9000


MEP Engineers
FLACK + KURTZ Inc
475 Fifth Avenue
New York, New York 10017
212 532 9600

CRONMELL ARCHITECTS ENGINEERS
101 South Spring Street
Little Rock Arkansas 72201
501 372 2900

Acoustic & Audio-Visual Consultants
CERAMI & ASSOCIATES
317 MADISON AVENUE
NEW YORK, NEW YORK 10017
212 370 1776

Seal

10% CONSTRUCTION DOCUMENTS	08/27/02
50% PROGRESS PRINT	08/30/02
100% PROGRESS PRINTING C&A	07/01/02
100% DD Issue C&A	03/01/02
Issue	Date

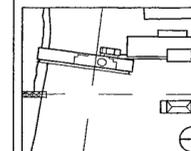

Job No C&A 14545


Scale 1/8" = 1'-0"

Date SEPTEMBER 27 2002


Title
GREAT HALL
AUDIOVISUAL
ELECTRICAL PLAN

Sheet No


AV-201

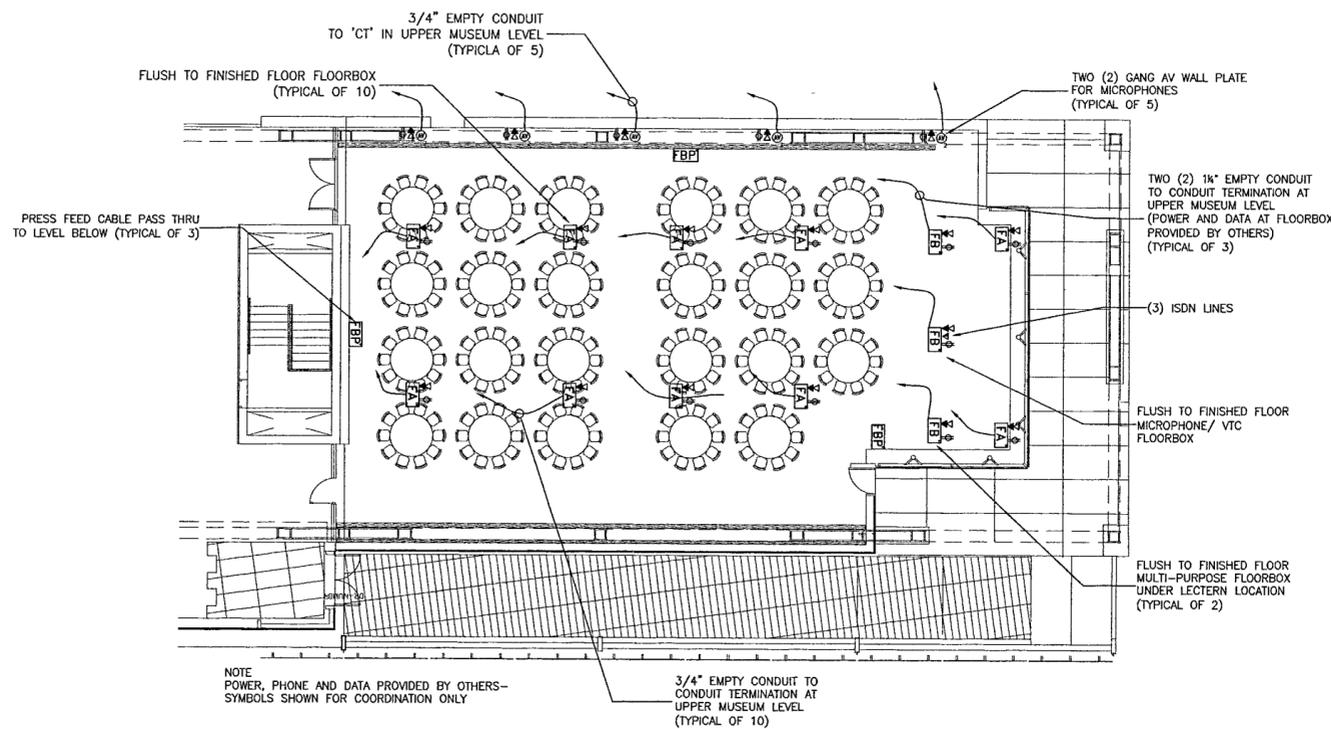


1 GREAT HALL
AUDIO-VISUAL ELECTRICAL PLAN
SCALE: 1/8"=1'-0"

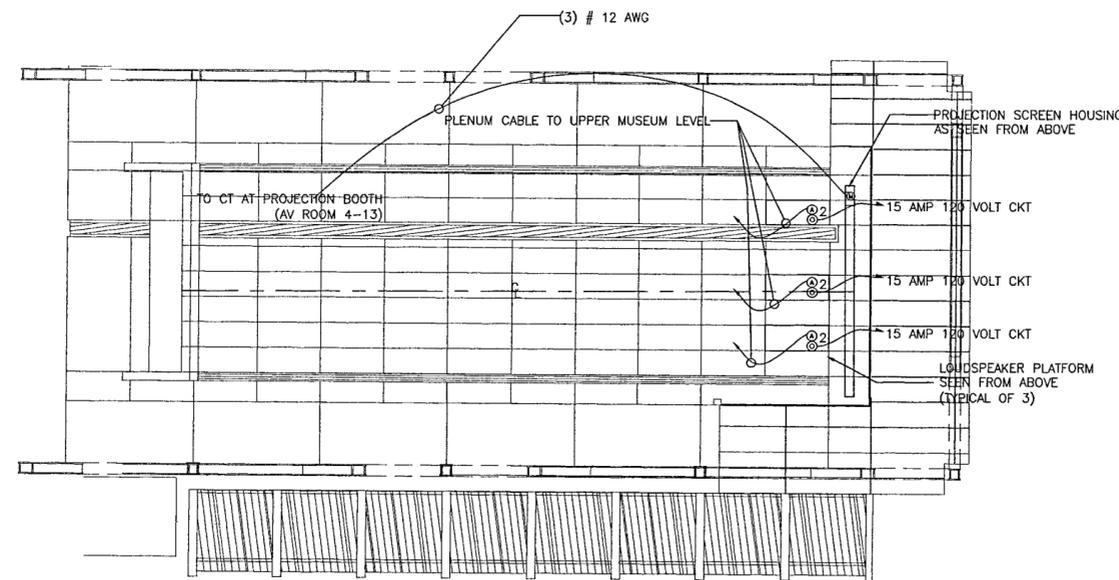


2 GREAT HALL
AUDIO-VISUAL ELECTRICAL RCP
SCALE: 1/8"=1'-0"

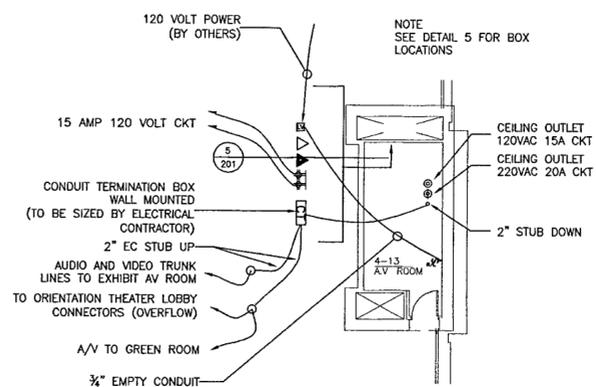

3 AV ROOM (4-13)
AUDIO-VISUAL ELECTRICAL PLAN
SCALE: 1/8"=1'-0"

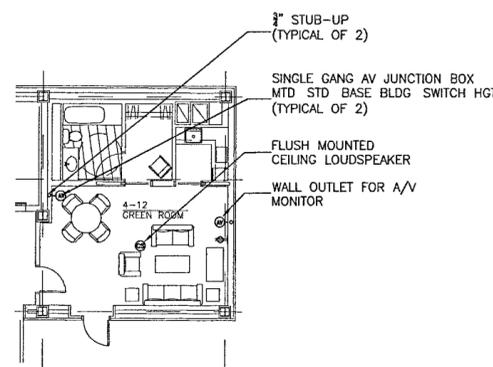

4 GREENROOM
AUDIO-VISUAL ELECTRICAL PLAN
SCALE: 1/8"=1'-0"

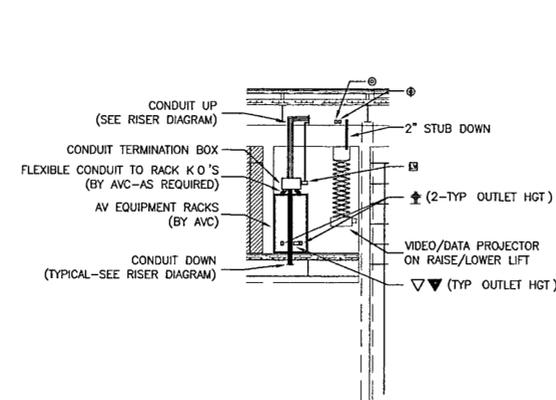

5 AV CONTROL ROOM
AUDIO-VISUAL ELECTRICAL DETAIL
SCALE: 1/8"=1'-0"

FOR OFFICIAL USE ONLY