

**WILLIAM J CLINTON
PRESIDENTIAL
CENTER**

LITTLE ROCK, ARKANSAS

Architect
POLSHEK PARTNERSHIP LLP
320 West 13th Street
New York, New York 10014
212 807 7171

Coordinating Architects
POLK STANLEY YEARY ARCHITECTS LP
700 South Schiller Street
Little Rock, Arkansas 72201
501 378 0878

WITSELL EVANS RASCO
901 West Third Street
Little Rock, Arkansas 72201
501 374 5300

WOODS CARADINE ARCHITECTS
2200 South Main Street
Little Rock, Arkansas 72206
501 374 4850

Landscape Architects
HARGREAVES ASSOCIATES
118 Magazine Street
Cambridge, Massachusetts 02139
617 661 0070

LANDSCAPE ARCHITECTURE Inc
400 West Capitol Avenue
Suite 1600 Regions Center
Little Rock, Arkansas 72201
501 374 5610

Structural Engineer
LESLIE E ROBERTSON ASSOC. RLLP
30 Broad Street, 47th Floor
New York, New York 10004
212 750 9000


MEP Engineers
FLACK + KURTZ Inc.
475 8th Avenue
New York, New York 10017
212 532 9600

CROMMELL ARCHITECTS ENGINEERS
101 South Spring Street
Little Rock, Arkansas 72201
501 372 2900

Acoustic & Audio-Visual Consultants
CERAMI & ASSOCIATES
317 MADISON AVENUE
NEW YORK, NEW YORK 10017
212 370 1776


Seal

100% CONSTRUCTION DOCUMENTS	09/27/02
90% PROGRESS PRINT	08/30/02
CD PROGRESS PRINTING C&A	07/01/02
100% DD Issue C&A	03/01/02
Issue	Date

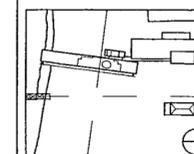


Job No. C&A 14545
Scale 1/4" = 1'-0"
Date SEPTEMBER 27, 2002
Title CONFERENCE ROOM
2ND LEVEL
AUDIOVISUAL
ELECTRICAL PLAN
Sheet No.



AV-202

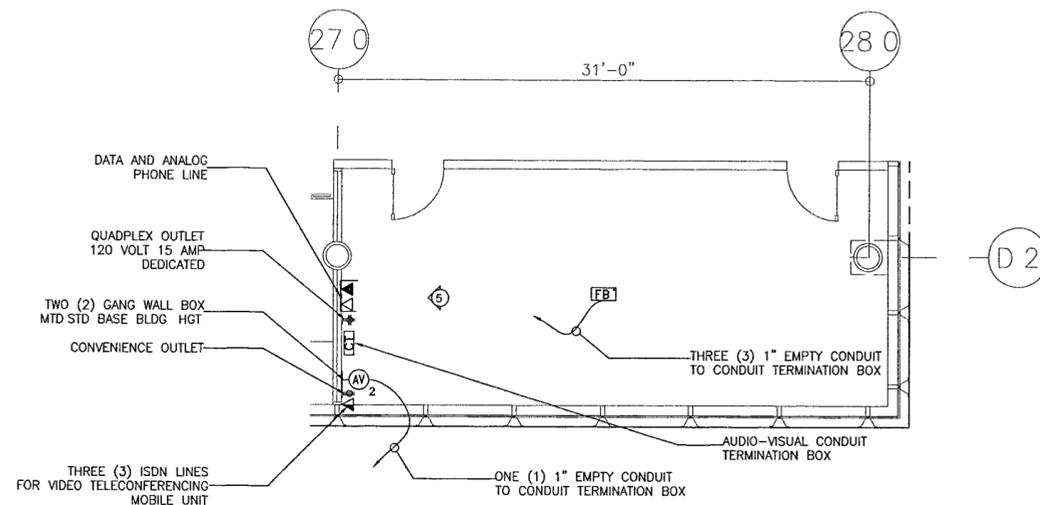


1 AUDIO-VISUAL ELECTRICAL PLAN CONFERENCE ROOM 2ND LEVEL
SCALE: 1/4"=1'-0"

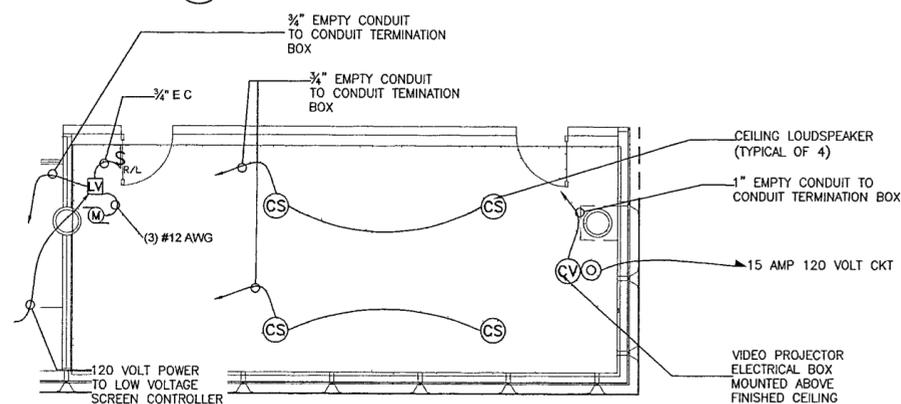

2 AUDIO-VISUAL ELECTRICAL RCP PLAN CONFERENCE ROOM 2ND LEVEL
SCALE: 1/4"=1'-0"

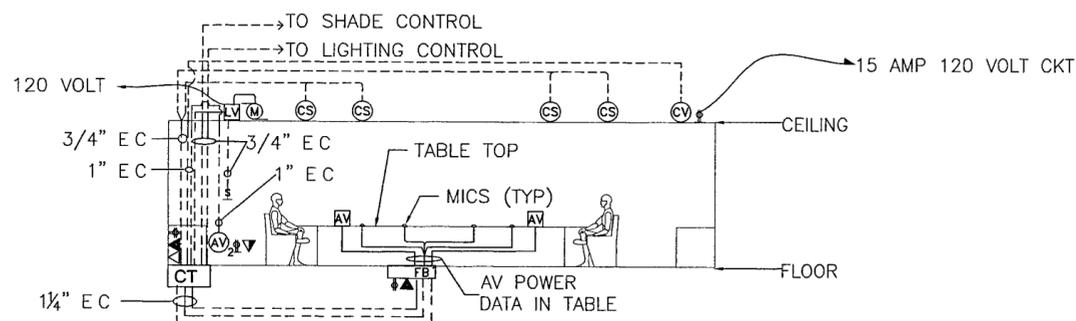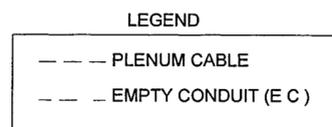

3 AUDIO-VISUAL CONDUIT/CABLE RISER
SCALE: N/A

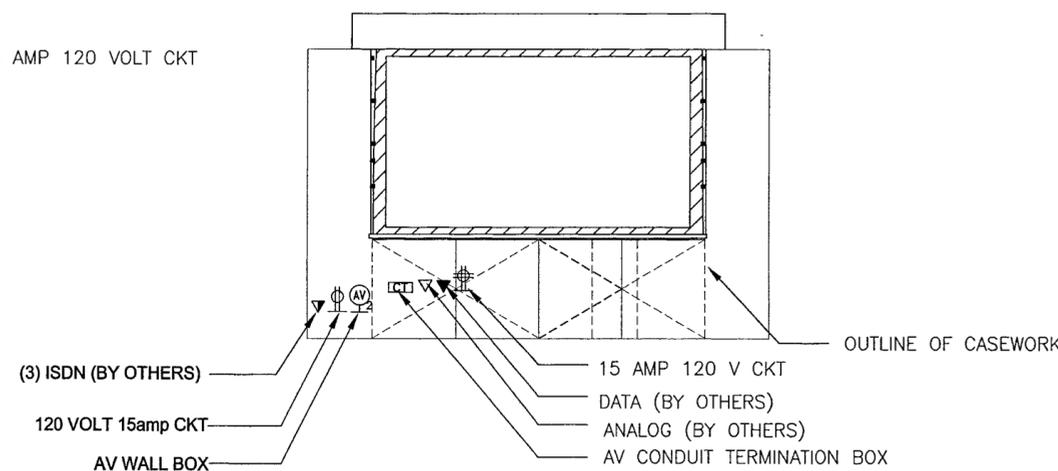

4 AUDIO-VISUAL ELECTRICAL ELEVATION
SCALE: 1/2"=1'-0"

FOR OFFICIAL USE ONLY

12.13.02