

**WILLIAM J CLINTON  
PRESIDENTIAL  
CENTER**

LITTLE ROCK ARKANSAS

**Architect**

POLSHEK PARTNERSHIP LLP  
320 West 13th Street  
New York, New York 10014  
212 807 7171

**Coordinating Architects**

POLK STANLEY YEARY ARCHITECTS LTD  
700 South Schiller Street  
Little Rock Arkansas 72201  
501 378 0878

WITSSELL EVANS RASCO  
901 West Third Street  
Little Rock Arkansas 72201  
501 374 5300

WOODS CARADINE ARCHITECTS  
2200 South Main Street  
Little Rock Arkansas 72206  
501 374 4050

**Landscape Architects**

HARGREAVES ASSOCIATES  
118 Magazine Street  
Cambridge Massachusetts 02138  
617 661 0270

LANDSCAPE ARCHITECTURE Inc  
400 West Capitol Avenue  
Suite 1500 Regency Center  
Little Rock Arkansas 72201  
501 374 5610

**Structural Engineer**

LESLIE E ROBERTSON ASSOC , RLLP  
30 Broad Street 47th Floor  
New York, New York 10004  
212 750 9000

**MEP Engineers**

FLACK + KURTZ Inc.  
475 Fifth Avenue  
New York, New York 10017  
212 532 9600


CROMWELL ARCHITECTS ENGINEERS  
101 South Spring Street  
Little Rock Arkansas 72201  
501 372 2900

**Acoustic & Audio-Visual Consultants**

CERAMI & ASSOCIATES  
317 MADISON AVENUE  
NEW YORK, NEW YORK 10017  
212 370 1776

Seal

Issue	Date
100% CONSTRUCTION DOCUMENTS	09/27/02
90% PROGRESS PRINT	08/30/02
CD PROGRESS PRINTING C&A	07/01/02
100% DD Issue C&A	03/01/02

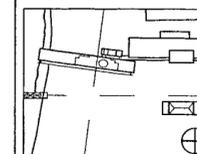

Job No C&A 14545


Scale 1/4" = 1'-0"

Date SEPTEMBER 27 2002

Title  
OVERFLOW AV CONNECTIONS  
AT ORIENTATION THEATER  
ELECTRICAL PLAN

Sheet No

**AV-203**

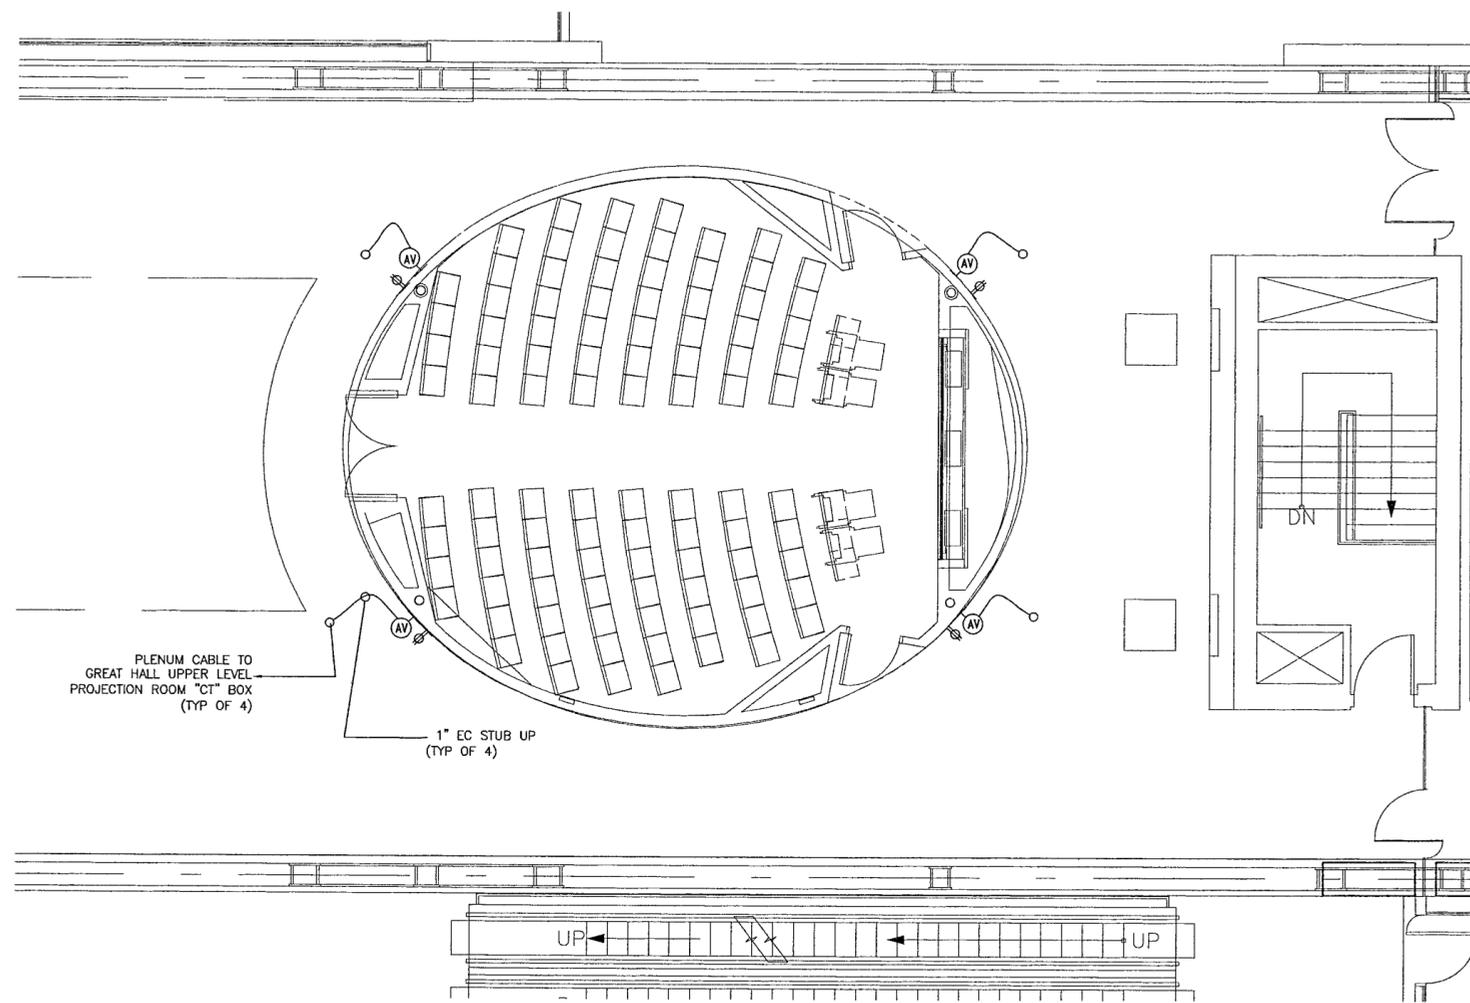

PLENUM CABLE TO  
GREAT HALL UPPER LEVEL  
PROJECTION ROOM "C1" BOX  
(TYP OF 4)

1" EC STUB UP  
(TYP OF 4)

1 AV ELECTRICAL PLAN  
OVERFLOW CONNECTORS AT ORIENTATION THEATER PERIMETER  
SCALE: 1/4" = 1'-0"

FOR OFFICIAL USE ONLY