

WILLIAM J CLINTON
PRESIDENTIAL
CENTER

LITTLE ROCK ARKANSAS

Architect
POLSHKE PARTNERSHIP LLP
320 West 13th Street
New York, New York 10014
212 807 7171

Coordinating Architects
POLK STANLEY YEARY ARCHITECTS LLP
700 South Schiller Street
Little Rock, Arkansas 72201
501 378 0870

WITSELL EVANS RASCO
901 West Third Street
Little Rock, Arkansas 72201
501 374 5300

WOODS CARADINE ARCHITECTS
2200 South Main Street
Little Rock, Arkansas 72206
501 374 4060

Landscape Architects
HARGREAVES ASSOCIATES
118 Magazine Street
Cambridge, Massachusetts 02139
617 661 0070

LANDSCAPE ARCHITECTURE Inc.
400 West Capitol Avenue
Suite 1600 Regions Center
Little Rock, Arkansas 72201
501 374 5610

Structural Engineer
LESLIE E ROBERTSON ASSOC , RLLP
30 Broad Street, 47th Floor
New York, New York 10004
212 750 9500


MEP Engineers
FLACK + KURTZ Inc.
475 Fifth Avenue
New York, New York 10017
212 532 9600

CROMWELL ARCHITECTS ENGINEERS
101 South Spring Street
Little Rock, Arkansas 72201
501 372 2900

Acoustic & Audio-Visual Consultants
CERAMI & ASSOCIATES
317 MADISON AVENUE
NEW YORK, NEW YORK 10017
212 370 1776

Seal

100% CONSTRUCTION DOCUMENT	09/27/02
90% PROGRESS PRINT	08/30/02
CD PROGRESS PRINTING C&A	07/01/02
100% DD Issue C&A	03/01/02
Issue	Date

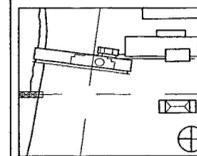


Job No C&A 14545

Scale 1/8" = 1'-0"


Date SEPTEMBER 27, 2002

Title
GROUND LEVEL
DIVISIBLE CLASSROOMS
AUDIOVISUAL
ELECTRICAL PLANS
Sheet No


AV-204

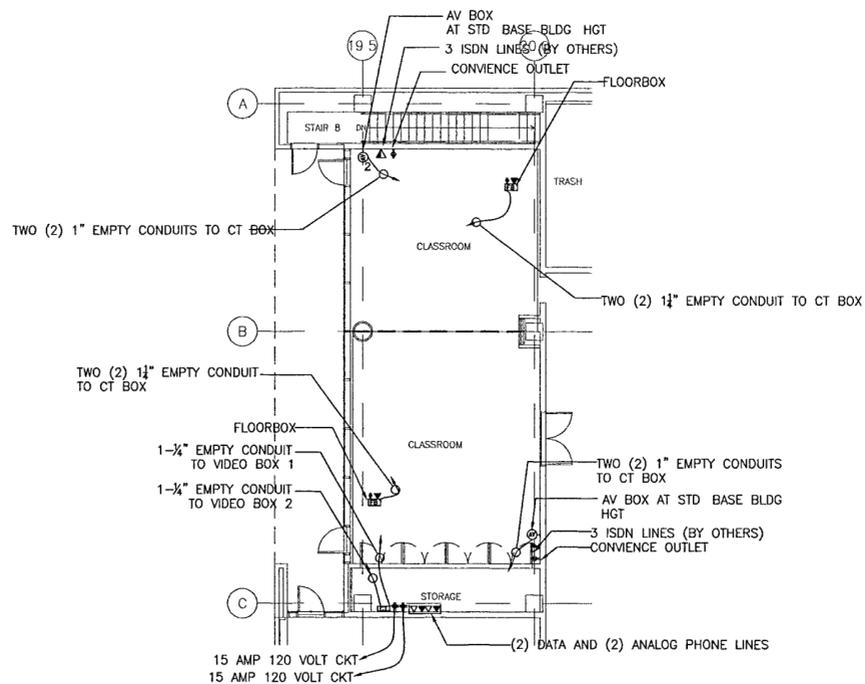

1 AUDIO-VISUAL ELECTRICAL PLAN
SCALE: 1/8" = 1'-0"

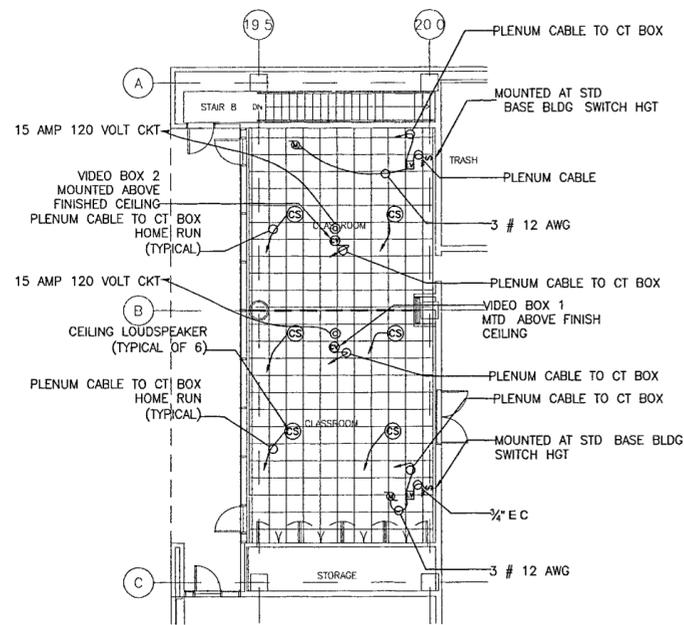

2 AUDIO-VISUAL ELECTRICAL RCP PLAN
SCALE: 1/8" = 1'-0"

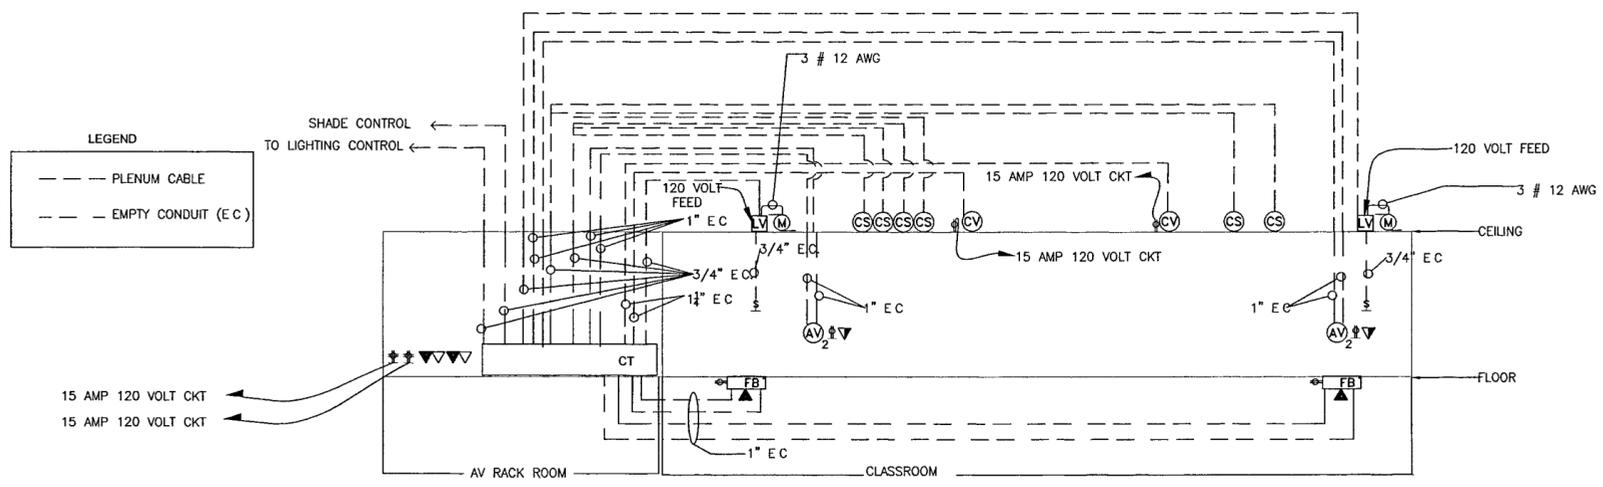

3 AUDIO-VISUAL CONDUIT/CABLE RISER
SCALE: 1/8" = 1'-0"

FOR OFFICIAL USE ONLY